



MEDITERRANEAN

DESERT MODERN

CATHEDRAL CITY ACCESSORY DWELLING UNIT - PLAN 1

PROJECT ADDRESS:

					TAFF INITIALS
APPLICANT:	OWNER:	*FOR BUILDING DEPARTM	ENT REVIEW, INIT	TIAL WHEN SECTION HAS	BEEN REVIEWED
ADDRESS:	ADDRESS:			ACHED 1 STORY 468 SF	AND
PHONE:	PHONE:	EITHER 65 SF MED		I 1 BEDROOMS, 1 BATH, DRCH OR 65 SF DESERT	AND
EMAIL:	EMAIL:	MODERN PORCH	SHOWN IN THE C	DRAWINGS AND SPECIFIC	ATIONS
CONTACT:	CONTACT:	2. ALL THE WORK	SHOWIN IN THE L	MAWINGS AND SECTIO	ATIONS
ADOLUTEOT				SQUARE	
ARCHITECT RR	RM DESIGN GROUP ADDRESS: 3765 S Higuera St, Suite 102	FLO	OOR		ITIONED?
	SAN LUIS OBISPO, CA 93401	PLAN 1 PLAN 1 PORCH		468 SF CONDIT	
	CONTACT: RANDY RUSSOM	I LAN IT OKCIT		03 31 0140014	DITIONED
	EMAIL: RWRUSSOM@RRMDESIGN.COM				
	PHONE: P:(805) 543-1794				
UTILITIES					
WATER AND SEWER SEI	RVICE				
ELECTRICAL SERVICE					
GAS SERVICE SEWER SERVICE		BUIDLING INFORMAT	ION:		
GARBAGE SERVICE					
CABLE SERVICE		NUMBER OF STORIES:		CCUPANCY GROUP:	R3_
		CONSTRUCTION TYPE:		RINKLERED: (SEE FIRE SI CTION ON THIS SHEET)	PRINKLER_
SUPPORT	TING DOCUMENTS	ZONING:		•	
	I II O DOGGINE I I I O	MAX HEIGHT ALLOWED:	<u> 16' - 0"</u> <u>M</u> A	XX HEIGHT PROPOSED:	11' - 5"
*FOR PLANNING STAFF O	ONLY HAS BEEN REVIEWED. STAFF INITIALS:	ADDITIONAL INFORMA			
		1. ANY PROPOSED ENERG		TEM (ESS) SHALL FOLLOV . RY SECTION 150.0(s) AND	
ENERGY COMPLIANCE		SEPARATE PERMIT TO B	E PULLED BY API	PLICANT.	
PREPARED BY:	CARSTAIRS ENERGY	2. VARIABLE CAPACITY HE			
DATE PREPAREI JOB NUMBER:	D: JUNE 12, 2024 24-061211	3. THIS PLAN IS INTENDED		3, AND RA3) (PER TITLE 2 (SLOPING LESS THAN 10"	
		LONGEST BUILDING DIM	ENSION), WITHOU	JT HIGHLY EXPANSIVE OF	R LIQUEFIABLE
ALL PLAN USERS MUST S TIME OF APPLICATION SL	SUBMIT A COMPLETED LIABILITY AGREEMENT FORM AT THE JBMITTAL.	WITH SLABS ON GRADE	CONSTRUCTION.	TIS SUPPORTED IN SHALI IF THE PROJECT SITE DE S DETERMINED BY THE B	EVIATES FROM AN
SIGNED USER LIC	CENSE AGREEMENT? YES NO			N PLANS AND DETAILS AF	
STAFF INITIALS:_		711 1 2107 1322.			
		SITE INFORMATION:	(Т	O BE PROVIDED BY APPI	LICANT OR OWNE
UTILITY, GRADING, AND D	DRAINAGE PLAN TO BE PROVIDED BY OTHERS.	APN:	LA	AND USE:	
DI 5405 DDC: "25 5 115 115	110TE DE 0/01 E E 0 D. I. E. I. E. D. O. E. I. I. E. D. O. E.	ZONING:	E	XISTING USE:	
TO ISSUANCE. THE OWN	ASTE RECYCLE FORM FILLED OUT AND SIGNED PRIOR ER/APPLICANT/CONTRACTOR/PERSON DOING THE	LOT SIZE:	_	ROPOSED USE:	
WORK IS REQUIRED TO F DEMOLITION DEBRIS.	RECYCLE 75% OF ALL PROJECT CONSTRUCTION AND	LOT COVERAGE	<u>S</u>	ETBACKS	

PROJECT DIRECTORY (TO BE PROVIDED BY OWNER / APPLICANT)

HERS QII REQUIRED

WASTE WATER:

HERS VCHP: HERS RATER WILL NEED TO FOLLOW THE VERIFICATION AND TESTING PROTOCOL FOR THE VARIABLE CAPACITY HEAT PUMP CREDIT REQUIREMENTS, INCLUDING BUT NOT LIMITED TO, VERIFIED REFRIGERANT CHARGE, VERIFIED MINIMUM HSPF AND EER/SEER, AND CAPACITY; DUCTLESS INDOOR UNITS AND THE COMPONENTS ARE WITHIN THE CONDITIONED ENVELOPE; AND AIRFLOW PROVIDED TO ALL HABITABLE SPACES (BEDROOMS AND LIVING SPACE).

SEPTIC (PERMITTED WHEN NO PUBLIC SEWER IS

SEPTIC DESIGN ARE REQUIRED)

DEEMED AVAILABLE - PERCOLATION REPORT AND

SEWER

THE FOLLOWING IS A SUMMARY OF THE FEATURES THAT MUST BE FIELD-VERIFIED BY A CERTIFIED HERS RATER AS A CONDITION FOR MEETING THE MODELED ENERGY PERFORMANCE OF THIS COMPUTER ANALYSIS. REGISTERED CF2RS AND CF3RS ARE REQUIRED TO BE COMPLETED IN THE HERS REGISTRY.

- QUALITY INSULATION INSTALLATION (QII) INDOOR AIR QUALITY VENTILATION
- KITCHEN RANGE HOOD
- VERIFIED REFRIGERANT CHARGE
- AIRFLOW IN HABITABLE ROOMS (SC3.1.4.1.7)
- VERIFIED HEAT PUMP RATED HEATING CAPACITY WALL-MOUNTED THERMOSTAT IN ZONES GREATER THAN 150 FT2 (SC3.4.5)
- DUCTLESS INDOOR UNITS LOCATED ENTIRELY IN CONDITIONED SPACE (SC3.1.4.1.8)

OWNER/APPLICANT SIGNATURE:

PROJECT INFORMATION STAFF INITIALS

HARDSCAPE/PAVING:

SETBACK RESTRICTIONS - FIRE RATINGS:

CHAPTER 2. FIRE RATED WALL DETAIL: 54/A-902

SEE DETAILS: 31/A-912, 32/A-912, 31/A-922, & 31/A-922

OWNER/APPLICANT HAS COMPLETED SPECIAL INSPECTION FORM

SEE SHEET S-103 FOR REQUIRED SPECIAL INSPECTIONS

FROM ANY ADJACENT BUILDING OR STRUCTURE?

DETAILS: 24/A-922, & 44/A-922

OWNER/APPLICANT SIGNATURE:

LANDSCAPE:

STRUCTURES:

S THE ADU 5' - 0" OR LESS TO ANY PROPERTY LINE AND/OR IS THE ADU 10' - 0" OR LESS

YES; IF YES, FIRE RATED WALL & PROJECTIONS REQUIRED PER 2022 CBC,

SPECIAL INSPECTIONS REQ'D

A REGISTERED DESIGN PROFESSIONAL SHALL COMPLETE THE CITY OF CATHEDRAL

PRIOR TO PERMIT ISSUANCE. IDENTIFY THE TYPE OF WORK REQUIRING SPECIAL

SPECIAL INSPECTION ELEMENT(S). FOR FURTHER INSTRUCTIONS SEE S-103.

CITY STATEMENT OF REQUIRED SPECIAL INSPECTIONS CERTIFICATE (FORM PLG-240)

INSPECTIONS IN THE PLANS AND THE INDIVIDUALS OR FIRMS RESPONSIBLE FOR THE

IF YES, FIREBLOCKING IS REQUIRED IN PROJECTIONS, RAKES AND EAVES.

ADDITIONALLY, 1-HOUR FIRE RATED PROJECTION NOTES ARE APPLICABLE ON

REAR: 4' - 0" (A.B. NO. 86)

SIDES: 4' - 0" (A.B. NO. 86)

REQUIRED:

PROPOSED:

PROJECT CHECKLIST

STAFF INITIALS *FOR BUILDING DEPARTMENT REVIEW, INITIAL WHEN SECTION HAS BEEN REVIEWED

VICINITY MAP (TO BE PROVIDED BY OWNER OR APPLICANT)

FIRE SPRINKLERS: (TO BE PROVIDED BY OWNER / APPLICANT)

DOES THE PRIMARY RESIDENCE HAVE NFPA 13D SPRINKLERS?

NO: THEREFORE, THE PROPOSED ADU IS NOT REQUIRED TO BE SPRINKLERED YES: THEREFORE, THE PROPOSED ADU IS REQUIRED TO BE SPRINKLERED

FIRE SPRINKLERS NOTES

WHEN SPRINKLERS ARE REQUIRED PER "PRE-APPROVED ADU PLANS APPLICATION

BUREAU AND APPROVED PRIOR TO INSTALLATION. PLANS AND INSTALLATION MUST BE BY A C16 LICENSED SPRINKLER CONTRACTOR. SECTION 903.3.1.3 NFPA 13D SPRINKLER SYSTEMS AUTOMATIC FIRE SPRINKLER SYSTEMS INSTALLED IN ONE- AND TWO-FAMILY DWELLINGS, GROUP R-3.

SECTION 903.2.8 GROUP R AN AUTOMATIC SPRINKLER SYSTEM INSTALLED IN ACCORDANCE WITH SECTION 903.3 SHALL BE PROVIDED THROUGHOUT ALL BUILDINGS WITH A GROUP R FIRE AREA.

SECTION 903.2.8.1 GROUP R-3 AN AUTOMATIC SPRINKLER SYSTEM INSTALLED IN ACCORDANCE WITH SECTION 903.3.1.3 SHALL BE PERMITTED IN GROUP R-3 OCCUPANCIES. LOCATION AND SIZE OF WATER SERVICE UNDERGROUND SHALL BE INSTALLED

AS SHOWN ON APPROVED FIRE SPRINKLER PLANS. A MINIMUM 1 INCH WATER A FIRE UNDERGROUND FLUSH CERTIFICATION SHALL BE REQUIRED AT FINAL

INSPECTION. A HYDRO INSPECTION OF THE FIRE SPRINKLER SYSTEM IS REQUIRED PRIOR TO FRAME INSPECTION. ONLY THE NEW PIPING SHALL BE TESTED.

SHEET INDEX

"DIG ALERT 811" PRIOR TO ANY EXCAVATION

CONSTRUCTION HOURS:

INFORMATION

OCTOBER 1ST THROUGH APRIL 30TH: MONDAY - FRIDAY: 7:00 A.M. TO 5:30 P.M. SATURDAY: 8:00 A.M. TO 5:00 P.M. SUNDAY: NONE **GOVERNMENT CODE HOLIDAYS: NONE**

MAY 1ST THROUGH SEPTEMBER 30TH: MONDAY - FRIDAY: 6:00 A.M. TO 7:00 P.M. SATURDAY: 8:00 A.M. TO 5:00 P.M. SUNDAY: NONE

GOVERNMENT CODE HOLIDAYS: NONE

USER LICENSE AGREEMENT

<u>OWNER/APPLICANT</u> TO SIGN & SUBMIT SEPERATE SUPPORTING DOCUMENT "USER LICENSE AGREEMENT" IN ADDITION TO SIGNING THIS USER AGREEMENT BELOW:

BY USING THESE PERMIT READY ACCESSORY DWELLING UNIT CONSTRUCTION DOCUMENTS, THE USER AGREES TO RELEASE, HOLD HARMLESS, AND INDEMNIFY THE CITY OF CATHEDRAL CITY, ITS ELECTED OFFICIALS AND EMPLOYEES, RRM. DESIGN GROUP, AND THE ARCHITECT OR ENGINEER WHO PREPARED THESE CONSTRUCTION DOCUMENTS FROM ANY AND ALL CLAIMS, LIABILITIES, SUITS AND DEMANDS ON ACCOUNT OF ANY INJURY, DAMAGE OR LOSS TO PERSONS OR PROPERTY, INCLUDING INJURY OR DEATH, OR ECONOMIC LOSSES, ARISING OUT OF THE USE OF THESE CONSTRUCTION DOCUMENTS.

THE PLANS ATTACHED HERE ARE APPROVED FOR ONLY USE IN CITY OF CATHEDRAL CITY. NO DEVIATIONS, ALTERATIONS, OR OPTIONS BEYOND THOSE SPECIFICALLY INDICATED IN THE PLANS ARE ALLOWED WITHOUT PRIOR APPROVAL BY THE ISSUING JURISDICTION AND CHIEF BUILDING OFFICIAL. ANY UNAPPROVED PLAN MODIFICATIONS MAY BE DEVELOPED THROUGH RRM DESIGN GROUP AND THE APPROVING JURISDICTION IF REQUIRED. THIS SET OF PLANS SHALL NOT BE USED FOR A PUBLIC HOUSING PROJECT.

SIGNATURE

TITLE SHEET GENERAL NOTES

SHEET INDEX, ABBREVIATIONS & SYMBOLS CAL GREEN RESIDENTIAL REQUIREMENTS CAL GREEN RESIDENTIAL REQUIREMENTS CALGREEN RESIDENTIAL MANDATORY REQUIREMENTS G-203

ENERGY COMPLIANCE - PLAN 1 T24-102 ENERGY COMPLIANCE - PLAN 1

ARCHITECTURAL SITE PLAN

A1-100 PLAN 1 RENDERINGS

A1-101 FINISH, MECHANICAL, & ELECTRICAL PLANS ROOF PLAN & REFLECTED CEILING PLAN - MEDITERRANEAN ROOF PLAN & REFLECTED CEILING PLAN - DESERT MODERN

BUILDING ELEVATIONS & SECTIONS - MEDITERRANEAN A1-202 **BUILDING ELEVATIONS & SECTIONS - DESERT MODERN**

ARCHITECTURAL DETAILS - COMMON A-902 ARCHITECTURAL DETAILS - COMMON A-903 ARCHITECTURAL DETAILS - COMMON A-911 ARCHITECTURAL DETAILS - MEDITERRANEAN

A-912 ARCHITECTURAL DETAILS - MEDITERRANEAN - ROOF A-921 ARCHITECTURAL DETAILS - DESERT MODERN ARCHITECTURAL DETAILS - DESERT MODERN - ROOF A-923 ARCHITECTURAL DETAILS - ADHERED MASONRY VENEER 01 A-924 ARCHITECTURAL DETAILS - ADHERED MASONRY VENEER 02 A-925 ARCHITECTURAL DETAILS - ADHERED MASONRY VENEER 03

> ARCHITECTURAL DETAILS - GENERAL AWNINGS 01 SHEET INDEX, ABBREVIATION & SYMBOLS

S-102 GENERAL NOTES S-103 GENERAL NOTES, SPECIAL INSPECTION & TESTS FOUNDATION PLAN & ROOF FRAMING PLAN

S-211 FOUNDATION PLAN & ROOF FRAMING PLAN S-301 TYPICAL CONCRETE DETAILS S-311 CONCRETE DETAILS TYPICAL WOOD DETAILS

TYPICAL WOOD DETAILS S-403 TYPICAL WOOD DETAILS TYPICAL ROOF DETAILS TYPICAL ROOF DETAILS S-422 Grand total: 39

A-931

S-402

DATE

OPTION SELECTIONS (ALL STYLES)

*OWNER/APPLICANT REQ. TO SELECT ONE OPTION FOR ALL OF THE FOLLOWING AND MARK THROUGH NON-APPLICABLE OPTIONS AND DETAILS THROUGHOUT SET:

(A) YES; WALL W/ DOOR #108 4/A1-101 (B) NO; OPEN FLOOR PLAN (STUDIO) <u> PTIONAL SLIDING DOOR @ BEDROOM</u> (A) YES; REPLACE W/ DOOR #106 4/A1-101 (B) NO; WINDOW #03 TO REMAIN <u>OPTIONAL SIDE DOOR @ BEDROOM</u> (A) YES; DOOR #107 3/A1-101 **(B)** NO

(B) NO; TUB TO REMAIN ALTERNATIVE KITCHEN MILLWORK / CABINETRY (A) EXTENDED UPPER AND LOWER CABINETS AS SHOWN (B) EXTENDED UPPER AND LOWER CABINETS WITH PANTRY

(C) ENTERTAINMENT CABINETRY WITH SPACE FOR TV

<u>OPTIONAL SHOWER IN LIEU OF TUB</u>

(A) YES; REPLACE TUB W/ SHOWER

(A) NORTHWEST ENERGY EFFICIENCY ALLIANCE (NEEA) RATED HEAT PUMP WATER HEATER; SPECIFIC BRAND/MODEL MUST BE INSTALLED (PER TITLE 24). (B) ALTERNATIVE WATER HEATER WITH STIPLII ATION THAT NEW T24 ENERGY RÉPORT IS PROVIDED, MER. & MODEL:

ELECTRICAL PANEL (SEE PLANS & SITE PLAN FOR LOCATION) (A) NEW ELEC. MAIN PANEL OF 200 AMP MIN. WITH 225 AMP MIN. BUSBAR RATING (B) A NEW ELEC. SUBPANEL CONNECTS TO THE ELEC. MAIN PANEL OF 220 AMP

ON THE PRIMARY HOME WITH A 225 AMP MIN. BUSBAR RATING (C) NEW ELEC. MAIN PANEL MIN. 400 AMP DUAL METER AT PRIMARY HOUSE WITH A NEW ELEC. SUB-PANEL AT ADU THAT CONNECTS TO THE MAIN PANEL

VALL & CEILING ALTERNATIVES TO TYPICAL GYP. FOR IMPROVED PERFORMANCE (NOTE: CLEARLY INDICATE SELECTION THICKNESS AND LOCATIONS IN THE PLANS.)

(A) IMPROVED ACOUSTIC / SOUND PERFORMANCE (B) IMPROVED MOISTURE / MOLD / MILDEW-RESISTANT PERFORMANCE

(C) BOTH (A) & (B)

(D) NONE

OPTION SELECTIONS (PER STYLE)

*OWNER OR APPLICANT TO SELECT (1) OF THE (3) FOLLOWING STYLES (BELOW) AND ONE OF EACH OF THE SUBSEQUENT OPTIONS THEREIN. FOR CLARITY, CROSS OUT OTHER STYLES AND STYLE OPTIONS THROUGHOUT THE ENTIRE DRAWING SET.

<u>MEDITERRANEAN</u>

1/A1-101 1) PRIMARY OPTION: SLIDERS WITH GRIDS PER ELEVATIONS 2) ALTERNATIVE: CASEMENT WINDOWS WITH GRIDS (SEE DESERT MODERN)

ROOFING MATERIAL 1/A1-121 (A) S-CLAY TILE ROOF; CLASS C MIN. (CRC R905.1, R905.3) (B) S-CLAY TILE ROOF; CLASS A REQUIRED PER CRC 337 (CRC R905.1, R905.3)

(C) OTHER: REQUIRES APPROVAL DECORATIVE GABLE VENTS 41/A-912

(A) YES; PER DETAIL:

(B) YES; ALTERNATIVE REQUIRES APPROVAL OWNER / APPLICANT TO PROVIDE DETAIL

XTERIOR EAVES, RAKES, & SOFFITS CONFIGURATION & MATERIAL SELECTION CRC R337 WUI COMPLIANCE OPT. PROVIDED FOR EACH OPTION; DETAILS: 31/A-912 1. ENCLOSED

(**D**) EXT. TOUNGE & GROOVE (A) EXT. TOUNGE & GROOVE (B) FIBER CEMENT (E) FIBER CEMENT (C) EXT. GRADE PLYWOOD (F) EXT. GRADE PLYWOOD

EXTERIOR LIGHT(S) NOTE: REQUIRED TO BE DARK SKY COMPLIANT] (A) MAXIM LIGHTING WHISPER DARK SKY WALL LANTERN (8639BZ) OR EQUAL

(B) FORTE LIGHTING - BLACK FINISH WITH HONEY GLASS (C) OTHER; REQUIRES APPROVAL. PROVIDE SPECIFICATIONS 11/A-911

DESERT MODERN

43/A-921 (A) OVERHEAD BRACE IMPERIAL LATTICE MARQUEE 6" GUTTER 54/A-931 (18" MIN. TO 24" MAX.) (WWW.GENERALAWNINGS.COM) (B) OTHER; REQUIRES APPROVAL. PROVIDE NAME, MANUFACTURER, & SPECIFICATIONS. (C) NONE

1) PRIMARY OPTION: CASEMENT WINDOWS

2) ALTERNATIVE: SLIDERS WITHOUT GRIDS (SEE MEDITERRANEAN) EXT. WALL COVERING SELECTION (SEE MATERIALS LEGEND) 1/A1-202 (A) EL DORADO STONE (CRC R703) ADHERED MASONRY VENEER 42/A-924

ROOFING MATERIAL (SEE MATERIALS LEGEND)

(B) OTHER STONE VENEER PRODUCT/MFR:

*REQUIRED TO BE DARK SKY COMPLIANT

(A) ASPHALT SHINGLE; CLASS C MIN. (NOTE: SEE CRC R905.1, R905.2 & R905.1.1) (B) ASPHALT SHINGLE; CLASS A MIN. REQ. WHEN PROJECT LOCATED IN HSFZ PER CRC 337 (NOTE: SEE CRC R905.1, R905.2 & R905.1.1) 1/A1-122 (C) OTHER; REQUIRES APPROVAL

EXTERIOR EAVES, RAKES, & SOFFITS CONFIGURATION & MATERIAL SELECTION CRC R337 **WUI** COMPLIANCE OPT. PROVIDED FOR EACH OPTION; DETAILS:

1. ENCLOSED (A) EXT. TOUNGE & GROOVE (A) EXT. TOUNGE & GROOVE (B) FIBER CEMENT (E) FIBER CEMENT

(C) EXT. GRADE PLYWOOD

(A) THE GREAT OUTDOORS KIRKHAM ASPEN BRONZE (8102-A138-L) OR EQUAL (B) THE LUTEC BARN LIGHT SCONCE W/ DUSK TO DAWN (6940002012) OR EQUAL (C) OTHER: REQUIRES APPROVAL. PROVIDE SPECIFICATIONS

(F) EXT. GRADE PLYWOOD

12/A-921

SHEET

2 Ш H

S

Cathedral City

THESE PLANS ARE PROVIDED BY THE CITY OF

CATHEDRAL CITY AS PART OF THE PRE-APPROVED ADU PROGRAM AND ARE PUBLIC DOMAIN. THERE

CANNOT BE A CHARGE TO PROVIDE THESE PLANS.

ALTERATIONS MUST BE DONE UNDER A SEPARATE

PERMIT ONCE THE BUILDING PERMIT FOR THE ADU

CONSTRUCTION KNOWLEDGE AND EXPERIENCE TO

CONTRUCT THESE PLANS WITHOUT FURTHER DETAILS,

IT IS RECOMMENDED YOU HIRE A CONTRACTOR TO

DO THE CONSTRUCTION. THE CITY WILL NOT PROVIDE

FURTHER INFORMATION OR DETAILS AND BUILDING

INSPECTORS WILL NOT PROVIDE STEP BY STEP

INSTRUCTIONS IN THE FIELD.

HAS BEEN ISSUED AND FINAL INSPECTION COMPLETED. IF YOU DO NOT HAVE THE

NO ALTERATIONS TO THESE PLANS ARE ALLOWED. AL

08/08/24

FLOOR PLAN NOTES

- WEATHER BARRIERS.
- a. NOT FEWER THAN ONE-LAYER WATER-RESISTIVE BARRIER SHALL BE APPLIED OVER STUDS OR SHEATHING OF ALL EXTERIOR WALLS CONTINUOUS FROM TOP OF WALS AND TERMINATED AT PENETRATIONS AND BUILDING APPENDAGES WITH FLASHING. MINIMUM NO. 15 FELT COMPLYING WITH ASTM D226, TYPE 1.
- b. PROVIDE (2) LAYERS OF GRADE D PAPER OR EQUAL WHEN PLASTER IS INSTALLED OVER WOOD BASED SHEATHING. (2022 CRC R703.7.3) . DOMESTIC RANGE VENTILATION DUCTS SHALL HAVE SMOOTH INTERIOR SURFACES. (2022 CMC 504.3)
- CLOTHES DRYER MOISTURE EXHAUST DUCTS SHALL TERMINATE OUTSIDE THE BUILDING AND HAVE A BACK-DRAFT DAMPER. EXHAUST DUCT IS LIMITED TO 14'-0" W/ TWO ELBOWS. THIS SHALL BE REDUCED 2'-0" FOR EVERY ELBOW IN EXCESS OF TWO. MIN. DIA. 4", SMOOTH, METAL DUCT. (2022)
- ALL MANUFACTURED EQUIPMENT SHALL BE INSTALLED AS PER MANUFACTURER'S SPECIFICATION AND DIMENSIONS VERIFIED WITH INSTALLATION REQUIREMENTS. ALL MANUFACTURER'S INSTALLATION
- INSTRUCTIONS SHOULD BE ON SITE FOR INSPECTIONS. SHOWERS AND TUB-SHOWER COMBINATIONS: CONTROL VALVES MUST BE PRESSURE BALANCED OR THERMOSTATIC MIXING VALVES. (2022 CPC 417.0.)
- WET-ROOM GLAZING. PROVIDE TEMPERED GLAZING IN DOORS AND ENCLOSURES FOR SHOWERS, BATHTUBS, SAUNAS, STEAM ROOMS, HOT TUBS & SIMILAR USES WHERE THE BOTTOM EXPOSED EDGE IS LESS THAN
- 60-INCHES ABOVE A STANDING SURFACE. (2022 CRC R308.4.5) HEATING AND AIR-CONDITIONING SYSTEM DESIGN SHALL CONFORM TO
- CALGREEN SEC. 4.507. ENVIRONMENTAL COMFORT.
- WATER CLOSETS. a. CLEARANCES: 24" MIN. FRONT. 30" MIN COMPARTMENT WIDTH. b. PROVIDE A MIN 3 SE WINDOW, 1/2 OF WHICH SHALL BE OPENABLE OR AN
- DIRECT VENT TO OUTSIDE WITH BACKDRAFT DAMPER. (2022 CRC R303.3) NEW WATER CLOSETS AND ASSOCIATED FLUSHOMETER VALVES, IF ANY SHALL USE NO MORE THAN 1.28 GALLONS PER FLUSH AND SHALL MEET PERFORMANCE STANDARDS ESTABLISHED BY THE AMERICAN SOCIETY OF MECHANICAL ENGINEERS STANDARD A112.19.2. H & S CODE,

EXHAUST FAN 50 CFM FOR INTERMITTENT OR 20 CFM FOR CONTINUOUS.

- SECTION 17921.3(B). BATH ACCESSORIES: PROVIDE MINIMUM 1 TOILET PAPER HOLDER AND 1 TOWEL BAR PER BATHROOM. PROVIDE NECESSARY BLOCKING FOR TOILET PAPER HOLDER AND TOWEL BARS.
- 10. WHOLE-BUILDING MECHANICAL VENTILATION SYSTEM PER ASHRAE STANDARD 62.2. PROVIDE THE INSPECTOR WITH THE FOLLOWING INFORMATION AT OR BEFORE THE TIME OF INSPECTION:
- a. CALCULATIONS FOR REQUIRED VENTING RATES. b. CALCULATION ADJUSTMENTS FOR INTERMITTENT SYSTEMS IF
- APPLICABLE. c. DUCT DIAMETER AND MAXIMUM DUCT LENGTH PER ASHRAE 62.2 TABLE
- d. TYPE OF SYSTEM USED AND PROVIDE COMPLETED CF-6R-MECH-05
- e. FANS SHALL BE A MAXIMUM OF 1 SONE. FANS SHALL BE PROVIDED A COVER OF R-4.2 WHEN OFF.
- 11. ATTIC ACCESS: a. WHERE REQUIRED, PROVIDE 30" MIN. HEADROOM IN THE ATTIC SPACE
- (2022 CRC R807.1) b. BUILDINGS WITH COMBUSTIBLE CEILING OR ROOF CONSTRUCTION SHALL HAVE AN ATTIC ACCESS OPENING TO ATTIC AREAS THAT EXCEED 30 SQUARE FEET AND HAVE A VERTICAL HEIGHT OF 30-INCHES OR GREATER. THE VERTICAL HEIGHT SHALL BE MEASURED FROM TOP OF

THE CEILING FRAMING MEMBERS TO THE UNDERSIDE OF THE ROOF

- THE ROUGH-FRAMED OPENING SHALL NOT BE LESS THAN 22" X 30" AND SHALL BE LOCATED NOT OVER 20 FEET FROM THE EQUIPMENT. (2022
- d. IN ATTIC, PROVIDE LIGHT AND SWITCH, AND ALL NECESSARY ELECTRICAL. PROVIDE UNOBSTRUCTED PASSAGEWAY 24" WIDE OF SOLID CONTINUOUS FLOORING FROM ACCESS TO EQUIPMENT AND IT'S CONTROLS. ALSO PROVIDE UNOBSTRUCTED WORK SPACE IN FRONT OF EQUIPMENT 30" DEPTH MINIMUM. PROVIDE COMBUSTION AIR AND CONDENSATE LINE TO OUTSIDE OR AN APPROVED DRAIN FOR OPTIONAL
- e. PROVIDE A 120V RECEPTACLE AND A LIGHT NEAR THE EQUIPMENT WITH LIGHT SWITCH LOCATED AT THE ATTIC ACCESS.
- 12. BATHTUB AND SHOWER FLOORS AND WALLS ABOVE BATHTUBS WITH INSTALLED SHOWER HEADS AND IN SHOWER COMPARTMENTS SHALL BE FINISHED WITH A NONABSORBENT SURFACE. SUCH WALL SURFACES SHALL EXTEND TO A HEIGHT OF NOT LESS THAN 6 FEET ABOVE THE FLOOR PER 2022 CRC, SECTION R307.2.

SITE NOTES

- CALL BEFORE YOU DIG! CONTACT UNDERGROUND SERVICE ALERT (USA) AT 1-800-227-2600 AT LEAST 2 WORKING DAYS BEFORE EXCAVATING.
- UNLESS OTHERWISE NOTED ON THE PLANS, FINISHED GROUND SURFACES SHALL BE GRADED TO DRAIN THE FINISHED SITE PROPERLY WITHIN 10-FEET OF ANY BUILDING FOUNDATION WITH A SLOPE OF 5% AWAY FROM ANY BUILDING OR STRUCTURE. ALL EXTERIOR HARDSCAPE WITHIN 10-FEET OF A BUILDING FOUNDATION SHALL BE INSTALLED WITH A 2% MINIMUM SLOPE AWAY FROM ANY BUILDING OR STRUCTURE. DRAINAGE SWALES SHALL BE A 1.5% MINIMUM SLOPE. ALL GRADED SLOPES SHALL HAVE A MAXIMUM SLOPE OF 3H TO 1V (33%), UNLESS
- SHOWN OTHERWISE ON THE PLANS. LOT GRADING SHALL CONFORM AT THE PROPERTY LINES AND SHALL NOT SLOPE TOWARD PROPERTY LINES IN A MANNER WHICH WOULD CAUSE STORM WATER TO FLOW ONTO NEIGHBORING PROPERTY. HISTORIC DRAINAGE PATTERNS SHALL NOT BE ALTERED IN A MANNER
- TO CAUSE DRAINAGE PROBLEMS TO NEIGHBORING PROPERTY. NEW RAINWATER DOWNSPOUTS SHALL BE DISCONNECTED AND DIRECT RUNOFF TO A LANDSCAPED AREA. DOWNSPOUTS MAY BE CONNECTED TO A POP-UP DRAINAGE EMITTER IN THE LANDSCAPED AREA OR MAY DRAIN TO SPLASH BLOCKS OR COBBLESTONES THAT DIRECT WATER
- AWAY FROM THE BUILDING. CONTRACTOR TO FIELD VERIFY EXISTING DRAINAGE. IF THE EXISTING DRAINAGE SYSTEM IS DAMAGED DURING EXCAVATION, CONTRACTOR SHALL REPAIR AND/OR REROUTE DRAINAGE SYSTEM AND CONNECT TO
- EXISTING DRAINAGE FACILITY AS NECESSARY. EXISTING PUBLIC IMPROVEMENTS THAT ARE DAMAGED BY THE PROJECT CONSTRUCTION SHALL BE REPAIRED OR REPLACED. EXISTING DAMAGED PUBLIC IMPROVEMENTS WITHIN THE PROJECT LIMITS SHALL BE REPAIRED OR REPLACED EVEN IF THE DAMAGE OCCURRED PRIOR
- TO THE START OF CONSTRUCTION. EROSION AND SEDIMENT CONTROL FACILITIES SHALL BE INSTALLED PRIOR TO OCTOBER 1 AND SHALL BE MAINTAINED DAILY UNTIL APRIL 30. THESE FACILITIES SHALL CONTROL AND CONTAIN EROSION-CAUSED SILT DEPOSITS AND PROVIDE FOR THE SAFE DISCHARGE OF SILT-FREE STORM WATERS INTO EXISTING STORM DRAIN FACILITIES. EROSION AND SEDIMENT CONTROL SUPPLIES MUST BE KEPT ON-SITE DURING THE DRY SEASON AND EMPLOYED, AS NECESSARY PRIOR TO AND
- DURING RAIN EVENTS. SEASONALLY APPROPRIATE BEST MANAGEMENT PRACTICES FOR THE FOLLOWING SITE MANAGEMENT CATEGORIES MUST BE IMPLEMENTED YEAR-ROUND: 1) EROSION CONTROL; 2) RUN-ON AND RUN-OFF CONTROL; 3) SEDIMENT CONTROL; 4) GOOD SITE MANAGEMENT; AND 5)
- NON-STORMWATER MANAGEMENT. AN ENCROACHMENT PERMIT WILL BE REQUIRED FOR ANY CONSTRUCTION ACTIVITY WITHIN A PUBLIC STREET RIGHT OF WAY THAT HAS BEEN ACCEPTED BY THE CITY.

ELECTRICAL NOTES

- 1. CONFORM WITH CURRENT CEC, NFPA, MFR'S, AND LOCAL REQUIREMENTS.
- ELECTRICAL SYSTEM GROUND TO BE PROVIDED PER NEC ARTICLE 250-81. ALL MATERIALS TO BE U.L. LABELED.
- METER: "SQUARE D". 120 VOLT/ 240 VOLT. 1 AND 3 WIRE GROUND OR EQUAL ELECTRICAL SUB PANEL: FLUSH MOUNT, 30" CLEARANCE. 100 AMP. 6. CONDUCTORS: TW, THW, COPPER, MINIMUM 14 AT LIGHTING, 12 AT OTHER
- ALL LUMINARIES SHALL COMPLY WITH 2022 CENC SECTION 150.0 (K) AND TABLE 150.0-A AS REFERENCED IN ENERGY NOTES, LUMINAIRE REQUIREMENTS SHEET G-101.
- ALL ELECTRICAL OUTLETS INSTALLED IN BATHROOMS, GARAGES, BASEMENTS, CRAWL SPACES, OUTDOORS, KITCHEN COUNTERS, AND AT WET BAR SINKS SHALL HAVE GROUND-FAULT CIRCUIT-INTERRUPTER PROTECTION IN COMPLIANCE WITH NEC Art. 210-8, CONSISTING OF 125 VOLT, SINGLE-PHASE, 15- AND 20- AMPERE RECEPTACLES.
- 9. ALL BATHROOM RECEPTACLE OUTLETS SHALL BE SUPPLIED BY A MINIMUM OF ONE 120-VOLT, 20-AMPERE BRANCH CIRCUIT. SUCH CIRCUITS SHALL HAVE NO OTHER OUTLETS. THIS DEDICATED CIRCUIT MAY SERVE MORE THAN ONE BATHROOM. (2022 CEC 210.11(C))
- 10. THERMOSTAT SHALL BE A PROGRAMMABLE TYPE, HONEYWELL TH8320 OR
- 11. CEILING-SUSPENDED (PADDLE) FANS SHALL BE SUPPORTED INDEPENDENTLY OF AN OUTLET BOX OR BY LISTED OUTLET BOX OR OUTLET BOX SYSTEMS IDENTIFIED FOR THE USE AND INSTALLED IN ACCORDANCE WITH 2022 CEC 314.27(C) (2022 CEC 422.18).
- 12. ALL LUMINARIES, LAMPHOLDERS, AND RETROFIT KITS SHALL BE LISTED (2022 CEC 410.6).
- 13. ALL 120-VOLT, SINGLE PHASE 15- AND 20- AMPERE BRANCH CIRCUITS SUPPLYING OUTLETS INSTALLED IN DWELLING UNIT KITCHENS, FAMILY ROOMS, LIVING ROOMS, DINING ROOMS, PARLORS, LIBRARIES, DENS. BEDROOMS, SUNROOMS, RECREATION ROOMS, CLOSETS, HALLWAYS OR SIMILAR ROOMS OR AREAS SHALL BE PROTECTED BY A LISTED ARC-FAULT CIRCUIT INTERRUPTER, COMBINATION-TYPE, INSTALLED TO PROVIDE PROTECTION OF THE BRANCH CIRCUIT. (2022 CEC 210-12(A)).
- 14. ALL NON-LOCKING TYPE 125-VOLT, 15 AND 20 AMPERE RECEPTACLES IN A DWELLING UNIT SHALL BE LISTED TAMPER-RESISTANT RECEPTACLES. EXCEPTIONS: (1) RECEPTACLES MORE THAN 5'6" ABOVE THE FLOOR, (2) RECEPTACLES PART OF A LUMINAIRE OR APPLIANCE. (3) A SINGLE RECEPTACLE OR A DUPLEX RECEPTACLE FOR TWO APPLIANCES THAT ARE NOT EASILY MOVED AND LOCATED WITHIN DEDICATED SPACE AND ARE CHORD-AND-PLUG CONNECTED AS PER CEC 400.10, AND (4) NON-GROUNDING RECEPTACLES USED FOR REPLACEMNETS AS PERMITTED IN CEC 406.4(D)(2)(A).
- 15. HIGH EFFICACY LUMINAIRES OTHER THAN OUTDOOR HID LIGHTING CONTAIN ONLY ONLY HIGH EFFICACY LAMPS AS OUTLINED IN TABLE 150-C OF THE RESIDENTIAL ENERGY CODE AND NOT CONTAIN A MEDIUM SCREW BASE SOCKET
- 16. BALLAST FOR LAMPS 13 WATTS OR GREATER SHALL BE ELECTRONIC AND
- HAVE AN OUTPUT FREQUENCY NO LESS THAT 20 kHz. 17. SMOKE DETECTORS SHALL RECEIVE THEIR PRIMARY POWER FROM THE BUILDING WIRING AND PROVIDED WITH A BATTERY BACK-UP. ALL SMOKE DETECTORS SHALL BE INTERCONNECTEED. ALL SMOKE DETECTORS SHALL MAINTAIN A MINIMUM 3 FOOT CLEARANCE TO HVAC SUPPLY OR RETURN AIR
- 18. CARBON MONOXIDE ALARMS SHALL RECEIVE THEIR PRIMARY POWER FROM THE BUILDING WIRING AND PROVIDED WITH A BATTERY BACK-UP. ALL CARBON MONOXIDE ALARAMS SHALL BE INTERCONNECTEED.
- 19. EXHAUST FANS WILL BE CONTROLLED BY A HUMIDISTAT PER THE GREEN BUILDING STANDARDS CODE SECTION 4.506. EXHAUST FANS MUST BE SWITCHED SEPARATELY FROM LIGHTS (2022 CEnC 150.0(k)2G).
- 20. IN ADDITION TO THE NUMBER OF BRANCH CIRCUTS REQUIRED BY OTHER PARTS OF THE CODE, TWO OR MORE 20-AMPERE SMALL-APPLIANCE BRANCH CIRCUTS SHALL BE PROVIDED FOR ALL RECEPTACLE OUTLETS IN THE KITCHEN, PANTRY, BREAKFAST ROOM, DINING ROOM, OR SIMILAR AREA PER 2022 CEC, ARTICLE 210.11 (C)(1). THE CIRCUTS SHALL HAVE NO OTHER
- OUTLETS PER 2022 CEC, ARTICLE 210.52(B). 21. IN ADDITION TO THE NUMBER OF BRANCH CIRCUTS REQUIRED BY OTHER PARTS OF THE CODE, AT LEAST ONE ADDITIONAL 20-AMPERE BRANCH CIRCUT SHALL BE PROVIDED TO SUPPLY THE LAUNDRY RECEPTACLE OUTLET(S) REQUIRED BY 2022 CEC, ARTICLE 210.52 (F). THIS CIRCUT SHALL HAVE NO OTHER OUTLETS PER 2022 CEC, ARTICLE 201.11(C)(2).

ENERGY NOTES

1. THE BUILDER MUST PROVIDE NEW HOMEWONERS WITH A LUMINAIRE SCHEDULE THAT INCLUDES A LIST OF INSTALLED LAMPS AND LUMINARIES.

LUMINAIRE REQUIREMENTS (2022 CEnC 150.0(k)1). LUMINAIRE EFFICACY. ALL INSTALLED LUMINAIRES SHALL MEET THE

REQUIREMENTS IN TABLE 150.0-A. EXCEPT: INTEGRATED DEVICE LIGHTING. LIGHTING INTEGRAL TO EXHAUST FANS, KITCHEN RANGE HOODS, BATH VANITY MIRRORS AND GARAGE DOOR OPENERS. NAVIGATION LIGHTING: SUCH AS NIGHT LIGHTS, STEP LIGHTS, AND PATH LIGHTS LESS THAN 5 WATTS. CABINET LIGHTING: LIGHTING INTERNAL TO DRAWERS. CABINETRY AND LINEN CLOSETS WITH AN

- EFFICACY OF 45 LUMENS PER WATT OR GREATER. THE FOLLOWING ARE HIGH-EFFICACY LIGHT SOURCES PER TABLE 150.0-A: THE FOLLOWING LIGHT SOURCES, OTHER THAN THOSE INSTALLED IN CEILING RECESSED DOWNLIGHT LUMINAIRES, ARE NOT REQUIRED TO
- COMPLY WITH REFERENCE JOINT APPENDIX JA8: 1. LED LIGHT SOURCES INSTALLED OUTDOORS. 2. INSEPARABLE SOLID STATE LIGHTING (SSL) LUMINAIRES CONTAINING COLORED LIGHT SOURCES THAT ARE INSTALLED TO
- PROVIDE DECORATIVE LIGHTING. 3. PIN-BASED LINEAR FLUORESCENT OR COMPACT FLUORESCENT LIGHT SOURCES USING ELECTRONIC BALLASTS. 4. HIGH INTENSITY DISCHARGE (HID) LIGHT SOURCES INCLUDING PULSE START METAL HALIDE AND HIGH PRESSURE SODIUM LIGHT
- SOURCES. LUMINAIRES WITH HARDWIRED HIGH FREQUENCY GENERATOR AND
- INDUCTION LAMP. CEILING FAN LIGHT KITS SUBJECT TO FEDERAL APPLIANCE REGULATIONS.
- THE FOLLOWING LIGHT SOURCES ARE ONLY CONSIDERED TO BE HIGH EFFICACY IF THEY ARE CERTIFIED TO THE COMMISSION AS HIGH EFFICACY LIGHT SOURCES IN ACCORDANCE WITH REFERENCE JOINT APPENDIX JA8 AND MARKED AS REQUIRED BY JA8:
- 1. ALL LIGHT SOURCES INSTALLED IN CEILING RECESSED DOWNLIGHT LUMINAIRES. NOTE THAT CEILING RECESSED DOWNLIGHT LUMINAIRES SHALL NOT HAVE SCREW BASES REGARDLESS OF LAMP TYPE AS DESCRIBED IN SECTION 150.0(K)1C. 2. ANY LIGHT SOURCE NOT OTHERWISE LISTED.
- B. **SCREW-BASED LUMINAIRES.** SCREW-BASED LUMINAIRES SHALL CONTAIN LAMPS THAT COMPLY WITH REFERENCE JOINT APPENDIX JA8. RECESSED DOWNLIGHT LUMINAIRES IN CEILINGS. LUMINAIRES RECESSED INTO CEILINGS SHALL MEET ALL OF THE FOLLOWING
- **REQUIREMENTS:** . SHALL NOT CONTAIN SCREW BASE LAMP SOCKETS; AND 2. HAVE A LABEL THAT CERTIFIES THE LUMINAIRE IS AIRTIGHT WITH AIR LEAKAGE LESS THAN 2.0 CFM AT 75 PASCALS WHEN TESTED IN ACCORDANCE WITH ASTM E283. AN EXHAUST FAN HOUSING WITH INTEGRAL LIGHT SHALL NOT BE REQUIRED TO BE CERTIFIED AIRTIGHT;
- 3. BE SEALED WITH A GASKET OR CAULK BETWEEN THE LUMINAIRE HOUSING AND CEILING, AND HAVE ALL AIR LEAK PATHS BETWEEN CONDITIONED AND UNCONDITIONED SPACES SEALED WITH A GASKET OR CAULK, OR BE INSTALLED PER MANUFACTURER'S INSTRUCTIONS TO MAINTAIN AIRTIGHTNESS BETWEEN THE LUMINAIRE HOUSING AND
- 4. MEET THE CLEARANCE AND INSTALLATION REQUIREMENTS OF CALIFORNIA ELECTRICAL CODE SECTION 410.116 FOR RECESSED LUMINAIRES.

CEILING: AND

EXCEPT: RECESSED LUMINAIRES MARKED FOR USE IN FIRE-RATED INSTALLATIONS EXTRUDED INTO CEILING SPACE AND RECESSED LUMINAIRES INSTALLED IN NONINSULATED CEILINGS.

ENERGY NOTES CONTINUED

- D. LIGHT SOURCES IN ENCLOSED OR RECESSED LUMINAIRES. LAMPS AND OTHER SEPARABLE LIGHT SOURCES THAT ARE NOT COMPLIANT WITH THE JA8 ELEVATED TEMPERATURE REQUIREMENTS, INCLUDING MARKING REQUIREMENTS. SHALL NOT BE INSTALLED IN ENCLOSED OR RECESSED
- LUMINAIRES. BLANK ELECTRICAL BOXES. THE NUMBER OF ELECTRICAL BOXES THAT ARE MORE THAN 5 FEET ABOVE THE FINISHED FLOOR AND DO NOT CONTAIN A LUMINAIRE OR OTHER DEVICE SHALL BE NO GREATER THAN THE NUMBER OF BEDROOMS. THESE ELECTRICAL BOXES MUST BE SERVED BY A DIMMER. VACANCY SENSOR CONTROL, LOW VOLTAGE WIRING OR FAN SPEED CONTROL.
- INDOOR LIGHTING CONTROLS (2022 CEnC 150.0(k)2). A. LIGHTING SHALL HAVE READILY ACCESSIBLE WALL-MOUNTED CONTROLS THAT ALLOW THE LIGHTING TO BE MANUALLY TURNED ON AND OFF. **EXCEPT:** CEILING FANS MAY PROVIDE CONTROL OF INTEGRATED LIGHTING
- VIA A REMOTE CONTROL. A. NO CONTROLS SHALL BYPASS A DIMMER, OCCUPANT SENSOR OR VACANCY SENSOR FUNCTION WHERE THAT DIMMER OR SENSOR HAS BEEN
- INSTALLED TO COMPLY WITH SECTION 150.0(K) B. LIGHTING CONTROLS SHALL COMPLY WITH THE APPLICABLE
- REQUIREMENTS OF SECTION 110.9. C. AN ENERGY MANAGEMENT CONTROL SYSTEM (EMCS) OR A MULTISCENE PROGRAMMABLE CONTROL MAY BE USED TO COMPLY WITH DIMMING, OCCUPANCY AND LIGHTING CONTROL REQUIREMENTS IN SECTION 150.0(K)2 IF IT PROVIDES THE FUNCTIONALITY OF THE SPECIFIED CONTROLS IN ACCORDANCE WITH SECTION 110.9, AND THE PHYSICAL CONTROLS
- SPECIFIED IN SECTION 150.0(K)2A. D. AUTOMATIC-OFF CONTROLS. 1. IN BATHROOMS, GARAGES, LAUNDRY ROOMS, UTILITY ROOMS AND WALK-IN CLOSETS, AT LEAST ONE INSTALLED LUMINAIRE SHALL BE CONTROLLED BY AN OCCUPANCY OR VACANCY SENSOR PROVIDING
- AUTOMATIC-OFF FUNCTIONALITY. FOR LIGHTING INTERNAL TO DRAWERS AND CABINETRY WITH OPAQUE FRONTS OR DOORS, CONTROLS THAT TURN THE LIGHT OFF WHEN THE DRAWER OR DOOR IS CLOSED SHALL BE PROVIDED.
- **DIMMING CONTROLS.** LIGHTING IN HABITABLE SPACES, INCLUDING BUT NOT LIMITED TO LIVING ROOMS, DINING ROOMS, KITCHENS AND BEDROOMS, SHALL HAVE READILY ACCESSIBLE WALL-MOUNTED DIMMING CONTROLS THAT ALLOW THE LIGHTING TO BE MANUALLY ADJUSTED UP AND DOWN. FORWARD PHASE CUT DIMMERS CONTROLLING LED LIGHT SOURCES IN THESE SPACES SHALL COMPLY WITH NEMA SSL 7A. **EXCEPT:** CEILING FANS MAY PROVIDE CONTROL OF INTEGRATED LIGHTING VIA A REMOTE CONTROL. LUMINAIRES CONNECTED TO A CIRCUIT WITH CONTROLLED LIGHTING POWER LESS THAN 20 WATTS OR CONTROLLED BY AN OCCUPANCY OR VACANCY SENSOR PROVIDING AUTOMATIC-OFF FUNCTIONALITY. NAVIGATION LIGHTING SUCH AS NIGHT LIGHTS, STEP LIGHTS, AND PATH LIGHTS LESS THAN 5 WATTS, AND LIGHTING INTERNAL TO DRAWERS AND CABINETRY WITH OPAQUE FRONTS OR DOORS OR WITH
- AUTOMATIC-OFF CONTROLS. INDEPENDENT CONTROLS. INTEGRATED LIGHTING OF EXHAUST FANS SHALL BE CONTROLLED INDEPENDENTLY FROM THE FANS. THE FOLLOWING SHALL BE CONTROLLED SEPARATELY FROM CEILING-INSTALLED LIGHTING SUCH THAT ONE CAN BE TURNED ON WITHOUT TURNING ON THE OTHER: UNDERCABINET LIGHTING, UNDERSHELF LIGHTING, INTERIOR LIGHTING
- OF DISPLAY CABINETS, AND SWITCHED OUTLETS. RESIDENTIAL OUTDOOR LIGHTING (2022 CEnC 150.0(k)3). IN ADDITION TO MEETING THE REQUIREMENTS OF SECTION 150.0(K)1A, LUMINAIRES PROVIDING RESIDENTIAL OUTDOOR LIGHTING SHALL MEET THE FOLLOWING
- REQUIREMENTS, AS APPLICABLE: A. FOR SINGLE-FAMILY RESIDENTIAL BUILDINGS, OUTDOOR LIGHTING PERMANENTLY MOUNTED TO A RESIDENTIAL BUILDING OR TO OTHER BUILDINGS ON THE SAME LOT SHALL MEET THE REQUIREMENT IN ITEM I AND THE REQUIREMENTS IN EITHER ITEM II OR ITEM III:
- 1. CONTROLLED BY A MANUAL ON AND OFF CONTROL SWITCH THAT PERMITS THE AUTOMATIC ACTIONS OF ITEMS II OR III BELOW; AND 2. CONTROLLED BY A PHOTOCELL AND EITHER A MOTION SENSOR OR AN
- AUTOMATIC TIME SWITCH CONTROL; OR CONTROLLED BY AN ASTRONOMICAL TIME CLOCK CONTROL. NOTE: CONTROLS THAT OVERRIDE TO ON SHALL NOT BE ALLOWED UNLESS THE OVERRIDE AUTOMATICALLY RETURNS THE AUTOMATIC CONTROL TO ITS NORMAL OPERATION WITHIN 6 HOURS. AN ENERGY MANAGEMENT CONTROL SYSTEM THAT PROVIDES THE SPECIFIED LIGHTING CONTROL FUNCTIONALITY AND COMPLIES WITH ALL REQUIREMENTS APPLICABLE TO THE SPECIFIED CONTROLS MAY BE USED TO MEET THESE REQUIREMENTS.
- 1. ALL JOINTS, PENETRATIONS AND OTHER OPENINGS IN THE BUILDING ENVELOPE THAT ARE POTENTIAL SOURCES OF AIR LEAKAGE SHALL BE CAULKED, GASKETED, WEATHER-STRIPPED OR OTHERWISE SEALED TO LIMIT INFILTRATION AND EXFILTRATION (2022 CEnC 110.7). 2. ATTIC ACCESS DOORS SHALL HAVE PERMANENTLY ATTACHED INSULATION USING ADHESIVE OR MECHANICAL FASTENERS. THE ATTIC ACCESS SHALL BE GASKETED TO PREVENT AIR LEAKAGE (2022 CEnC 150.0(a)2)

ENERGY STORAGE READINESS

- **ENERGY STORAGE SYSTEM (ESS) REQUIREMENTS:**
- IN SINGLE-FAMILY RESIDENTIAL BUILDINGS THAT INCLUDE ONE OR TWO DWELLINGS, EACH DWELLING UNIT SHALL BE PROVIDED WITH DEDICATED RACEWAYS, DESIGNATED BRANCH CIRCUITS AND ISOLATION DEVICES FOR ENERGY STORAGE SYSTEMS AS SPECIFIED IN CALIFORNIA ENERGY CODE SECTION 150.0(S). ADDITIONALLY. THE PANELBOARDS SHALL BE PROVIDED WITH THE MINIMUM BUSBAR RATING AS SPECIFIED IN CALIFORNIA ENERGY CODE SECTION 150.0(S). (2022 CEC SECTION 706.10)
- CALIFORNIA ENERGY CODE SECTION 150.0(S)
- AT LEAST ONE OF THE FOLLOWING SHALL BE PROVIDED: A. ESS READY INTERCONNECTION EQUIPMENT WITH A MINIMUM BACKED-UP CAPACITY OF 60 AMPS AND A MINIMUM OF FOUR ESS-SUPPLIED BRANCH
- CIRCUITS, OR B. A DEDICATED RACEWAY FROM THE MAIN SERVICE TO A PANELBOARD (SUBPANEL) THAT SUPPLIES THE BRANCH CIRCUITS IN SECTION 150.0(S) (2). ALL BRANCH CIRCUITS ARE PERMITTED TO BE SUPPLIED BY THE MAIN SERVICE PANEL PRIOR TO THE INSTALLATION OF AN ESS. THE TRADE SIZE OF THE RACEWAY SHALL BE NOT LESS THAN 1 INCH. THE PANELBOARD THAT SUPPLIES THE BRANCH CIRCUITS (SUBPANEL) MUST
- BE LABELED "SUBPANEL SHALL INCLUDE ALL BACKEDUP LOAD CIRCUITS." A MINIMUM OF FOUR BRANCH CIRCUITS SHALL BE IDENTIFIED AND HAVE THEIR SOURCE OF SUPPLY COLLOCATED AT A SINGLE PANELBOARD SUITABLE TO BE SUPPLIED BY THE ESS. AT LEAST ONE CIRCUIT SHALL SUPPLY THE REFRIGERATOR, ONE LIGHTING CIRCUIT SHALL BE LOCATED NEAR THE PRIMARY EGRESS AND AT LEAST ONE CIRCUIT SHALL SUPPLY A
- SLEEPING ROOM RECEPTACLE OUTLET. THE MAIN PANELBOARD SHALL HAVE A MINIMUM BUSBAR RATING OF 225
- 4. SUFFICIENT SPACE SHALL BE RESERVED TO ALLOW FUTURE INSTALLATION OF A SYSTEM ISOLATION EQUIPMENT/TRANSFER SWITCH WITHIN 3 FEET OF THE MAIN PANELBOARD. RACEWAYS SHALL BE INSTALLED BETWEEN THE PANELBOARD AND THE SYSTEM ISOLATION EQUIPMENT/TRANSFER SWITCH LOCATION TO ALLOW THE CONNECTION OF BACKUP POWER SOURCE.

PLUMBING NOTES

- 1. CONFORM WITH CURRENT CPC AND LOCAL REQUIREMENTS.
- 2. DOMESTIC WATER (WITHIN BUILDING): COPPER OR PEX PIPE OR APPROVED
- 3. AIR CHAMBERS: 12" LONG CAPPED NIPPLE AT END OF EACH BRANCH TO EACH FIXTURE.

4. DIELECTRIC UNIONS "F.P.C.O." REQUIREMENT AT ALL DISSIMILAR MATERIAL

- CONNECTIONS. 5. WHEN "OPTIONAL" SOFT-WATER LOOP INTALLED, PROVIDE WITH 2 GATE
- VALVES
- 6. WATER SERVICE PIPE SHALL BE PER CIVIL PLANS OR AS REQUIRED BY THE JURISDICTION. 7. WATER METER: PER WATER DISTRICT (REFER SIZE W/ FIRE SPRINKLER
- PLANS IF APPLICABLE) 8. SHOWER HEADS AND FAUCETS: FLOW RATES PER 2022 CGBSC SECTION
- 9. WATER HEATER (REFER TO BUILDING ENERGY ANALYSIS REPORT):
- A. ALL DOMESTIC HOT WATER PIPING SHALL BE INSULATED. (2022 CPC PIPES UP TO 2 INCHES IN DIAMETER: INSULATION WALL THICKNESS
- NOT LESS THAN DIAMETER OF PIPE. (2022 CPC 609.12.2) 2. PIPES GREATER THAN 2 INCHES IN DIAMETER: INSULATION WALL THICKNESS NOT LESS THAN 2 INCHES. (2022 CPC 609.12.2)
- **EXCEPTIONS:** 1. PIPING THAT PENETRATES FRAMING MEMBERS SHALL NOT BE REQUIRED TO HAVE PIPE INSULATION FOR THE DISTANCE OF
- THE FRAMING PENETRATION. (2022 CPC 609.12.2) 2. HOT WATER PIPING BETWEEN THE FIXTURE CONTROL VALVE OR SUPPLY STOP AND THE FIXTURE OR APPLIANCE SHALL NOT BE
- REQUIRED TO BE INSULATED. (2022 CPC 609.12.2) PROVIDE A TEMPERATURE AND PRESSURE RELIEF VALVE WITH A FULL SIZE DRAIN OF GALVANIZED STEEL OR HARD DRAWN COPPER TO THE OUTSIDE OF THE BUILDING WITH THE END OF THE PIPE PROTRUDING 6" MINIMUM @ 2' MAX. ABOVE GRADE POINTING DOWNWARD TO THE **TERMINATION - UNTHREADED.**
- C. COMBUSTION AIR PER MANUFACTURE REQUIREMENTS.
- **D.** CLEARANCES PER MANUFACTURE REQUIREMENTS. 10. PLUMBING INSULATION PER 2022 CENC 150.0 (J) AND CBC 609.11
- A. DOMESTIC HOT WATER PIPING SHALL BE INSULATED. B. HOT WATER PIPE INSULATION SHALL HAVE A MINIMUM WALL THICKNESS OF NOT LESS THAN THE DIAMETER OF THE PIPE FOR A PIPE UP TO 2 INCHES (50 MM) IN DIAMETER. INSULATION WALL THICKNESS SHALL BE NOT LESS THAN 2 INCHES (51 MM) FOR A PIPE OF 2 INCHES (50 MM) OR
- MORE IN DIAMETER. 1. PIPING THAT PENETRATES FRAMING MEMBERS SHALL NOT BE REQUIRED TO HAVE PIPE INSULATION FOR THE DISTANCE OF THE FRAMING PENETRATION.
- 2. HOT WATER PIPING BETWEEN THE FIXTURE CONTROL VALVE OR SUPPLY STOP AND THE FIXTURE OR APPLIANCE SHALL NOT BE REQUIRED TO BE INSULATED.
- C. SERVICE WATER HEATING SYSTEMS PIPING TO INCLUDE. RECIRCULATING SYSTEM PIPING, INCLUDING THE SUPPLY AND
- RETURN PIPING TO THE WATER HEATER. 2. THE FIRST 8 FEET OF HOT AND COLD OUTLET PIPING, INCLUDING PIPING BETWEEN A STORAGE TANK AND A HEAT TRAP, FOR A
- NON-RECIRCULATING STORAGE SYSTEM. 3. PIPES THAT ARE EXTERNALLY HEATED.
- SHALL BE INSULATED AS FOLLOWS: UP TO 1" PIPE DIAMETER TO HAVE 1.0 MIN THICKNESS OR R7/7 RATING PER CENC TABLE 120.3A **EXCEPTIONS:**
- 1. FACTORY-INSTALLED PIPING WITHIN SPACE-CONDITIONING EQUIPMENT CERTIFIED UNDER SECTION 110.1 OR 110.2. 2. PIPING THAT PENETRATES FRAMING MEMBERS SHALL NOT BE
- REQUIRED TO HAVE PIPE INSULATION FOR THE DISTANCE OF THE FRAMING PENETRATION. METAL PIPING THAT ENETRATES METAL FRAMING SHALL USE GROMMETS, PLUGS, WRAPPING OR OTHER INSULATING MATERIAL TO ASSURE THAT NO CONTACT IS
- MADE WITH THE METAL FRAMING. 3. PIPING INSTALLED IN INTERIOR OR EXTERIOR WALLS SHALL NOT BE REQUIRED TO HAVE PIPE INSULATION IF ALL OF THE REQUIREMENTS ARE MET FOR COMPLIANCE WITH QUALITY INSULATION INSTALLATION (QII) AS SPECIFIED IN THE
- 4. PIPING SURROUNDED WITH A MINIMUM OF 1 INCH OF WALL INSULATION, 2 INCHES OF CRAWLSPACE INSULATION, OR 4 INCHES OF ATTIC INSULATION SHALL NOT BE REQUIRED TO HAVE PIPE INSULATION. 11. INSULATION PROTECTION. PIPE INSULATION SHALL BE PROTECTED FROM

REFERENCE RESIDENTIAL APPENDIX RA3.5.

DAMAGE DUE TO SUNLIGHT, MOISTURE, EQUIPMENT MAINTENANCE AND WIND. PROTECTION SHALL, AT MINIMUM, INCLUDE THE FOLLOWING (2022 CEC SECTION 120.3(B)): A. PIPE INSULATION EXPOSED TO WEATHER SHALL BE PROTECTED BY A COVER SUITABLE FOR OUTDOOR SERVICE. THE COVER SHALL BE

WATER RETARDANT AND PROVIDES SHIELDING FROM SOLAR RADIATION

- THAT CAN CAUSE DEGRADATION OF THE MATERIAL. ADHESIVE TAPE SHALL NOT BE USED TO PROVIDE THIS PROTECTION. B. PIPE INSULATION COVERING CHILLED WATER PIPING AND REFRIGERANT SUCTION PIPING LOCATED OUTSIDE THE CONDITIONED SPACE SHALL
- INCLUDE, OR BE PROTECTED BY, A CLASS I OR CLASS II VAPOR RETARDER, ALL PENETRATIONS AND JOINTS SHALL BE SEALED. C. PIPE INSULATION BURIED BELOW GRADE MUST BE INSTALLED IN A
- WATER PROOF AND NONCRUSHABLE CASING OR SLEEVE. 12. PIPE INSULATION: REFER TO TITLE 24 - MANDATORY MEASURES - "SPACE CONDITIONING, WATER HEATING & PLUMBING SYSTEM MEASURES"
- 13. STRAPS AND HANGERS: PROVIDE AS NECESSARY TO INSURE A STABLE INSTALLATION. SEE TITLE-24 FOR WATER HEATER REQUIREMENTS. 14. ALL HOSE BIBS SHALL HAVE APPROVED BACK FLOW PREVENTION DEVICES.
- 15. PLUMBING FIXTURES (WATER CLOSETS) AND FITTINGS (FAUCETS AND SHOWERHEADS) SHALL MEET THE STANDARDS REFERENCED IN CALGREEN TABLE 4.303.3. **16.** WATER HEATER SHALL BE PROVIDED WITH A TEMPERATURE AND
- PROVIDED WITH A DRAIN LINE WHICH EXTENDS FROM THE VALVES TO THE OUTSIDE OF THE BUILDING. PER [2022 608.5 CPC] 17. PER 2022 CPC 603.5.7 OUTLETS WITH HOSE ATTATCHMENTS. POTABLE WATER OUTLETS WITH HOSE ATTACHMENTS, OTHER THAN WATER HEATER DRAINS, BOILER DRAINS, AND CLOTHES WASHER CONNECTIONS, SHALL BE PROTECTED BY A NONREMOVABLE HOSE BIBB TYPE BACKFLOW PREVENTER, A NONREMOVABLE HOSE BIBB TYPE VACUMM BREAKER, OR BY AN ATMOSPHERE VACUUM BREAKER INSTALLED NOT LESS THAN 6 INCHES ABOVE THE HIGHEST POINT OF USAGE LOCATED ON THE DISCHARGE SIDE OF THE LAST VALVE. IN CLIMATES WHERE FREEZING TEMPERATURES OCCUR, A LISTED SELF DRAINING FROST-PROOF HOSE BIBB WITH AN INTEGRAL BACKFLOW PREVENTER OR VACUUM BREAKER SHALL BE USED.

PRESSURE RELIEF VALVE. PER [2022 CPC 505.2] THE RELIEF VALVE SHALL BE

PROJECT GENERAL NOTES

- APPLICABLE CODES AND STANDARDS:
- 1.1. 2022 CALIFORNIA RESIDENTIAL CODE AND STANDARDS.
- 1.2. 2022 CALIFORNIA PLUMBING CODE AND STANDARDS. 1.3. 2022 CALIFORNIA MECHANICAL CODE AND STANDARDS.
- 1.4. 2022 CALIFORNIA FIRE CODE AND STANDARDS.
- 1.5. 2022 CALIFORNIA ELECTRICAL CODE AND STANDARDS.
- 1.6. 2022 CALIFORNIA ENERGY CODE AND STANDARDS.
- 1.7 2022 CALIFORNIA GREEN BUILDING STANDARDS CODE AND STANDARDS. 1.8 CITY OF CATHEDRAL CITY MUNICIPAL CODE
- ALL WORK DESCRIBED IN THE DRAWINGS SHALL BE VERIFIED FOR DIMENSION, GRADE, EXTENT AND COMPATIBILITY WITH EXISTING SITE CONDITIONS. ANY DISCREPANCIES AND UNEXPECTED CONDITIONS THAT AFFECT OR CHANGE THE WORK DESCRIBED IN THE CONTRACT DOCUMENTS SHALL BE BROUGHT TO THE ARCHITECT'S ATTENTION IMMEDIATELY. DO NOT PROCEED WITH THE WORK IN THE AREA OF DISCREPANCIES UNTIL ALL SUCH DISCREPANCIES ARE RESOLVED. IF THE CONTRACTOR CHOOSES TO DO SO, HE/SHE SHALL BE PROCEEDING AT HIS/HER OWN RISK.
- DIMENSIONS SHOWN SHALL TAKE PRECEDENCE OVER DRAWING SCALE OR PROPORTION. LARGER SCALE DRAWINGS SHALL TAKE PRECEDENCE OVER SMALLER SCALE DRAWINGS.
- IN THE EVENT OF THE UNFORESEEN ENCOUNTER OF MATERIALS SUSPECTED TO BE OF AN ARCHAEOLOGICAL OR PALEONTOLOGICAL NATURE, ALL GRADING AND EXCAVATION SHALL CEASE IN THE IMMEDIATE AREA AND THE THE CONTRACTOR SHALL NOTIFY THE OWNER. THE FIND SHALL BE LEFT UNTOUCHED UNTIL AN EVALUATION BY A QUALIFIED ARCHAEOLOGIST OR PALEONTOLOGIST IS MADE.
- CONTRACTOR IS TO BE RESPONSIBLE FOR BEING FAMILIAR WITH THESE DOCUMENTS INCLUDING ALL CONTRACT REQUIREMENTS.
- GRADING PLANS, DRAINAGE IMPROVEMENTS, ROAD AND ACCESS REQUIREMENTS AND ENVIRONMENTAL HEALTH CONSIDERATIONS SHALL COMPLY WITH ALL LOCAL ORDINANCES.
- SHOP WELDS MUST BE PERFORMED BY A LICENSED FABRICATOR'S SHOP. THE FOLLOWING ITEMS SHOWN ON THE DRAWINGS ARE OWNER PROVIDED. OWNER INSTALLED. UTILITIES PROVIDED FOR THESE ITEMS WILL BE PROVIDED BY THE CONTRACTOR. CONTRACTOR TO COORDINATE
- INSTALLATION WITH OWNER. 8.1. TV/DVD SYSTEMS
- 8.2. ICE MACHINE 8.3. VENDING MACHINE
- 8.4. REFRIGERATOR
- 8.5. MICROWAVE OSHA PERMITS REQUIRED FOR VERTICAL CUTS 5' OR OVER.
- 10. CONTRACTOR TO PROVIDE COMPLETE DETAILS OF ENGINEERED TEMPORARY SHORING OR SLOT CUTTING PROCEDURES ON PLANS. CALL FOR INSPECTION BEFORE EXCAVATION BEGINS.
- 11. THE SOILS ENGINEER IS TO APPROVE THE KEY OR BOTTOM AND LEAVE A CERTIFICATE ON THE SITE FOR THE GRADING INSPECTOR. THE GRADING INSPECTOR IS TO BE NOTIFIED BEFORE ANY GRADING BEGINS. AND FOR BOTTOM INSPECTION, BEFORE FILL IS PLACED. FILL MAY NOT BE PLACED WITHOUT APPROVAL OF THE GRADING INSPECTOR.
- 12. CONTRACTOR TO REVIEW CALIFORNIA GREEN CODE REQUIREMENTS FOR CONTRACTOR REQUIREMENTS.
- 13. A SEPARATE OFFICER, ACCESS EASEMENT/AGREEMENT, AND/OR RECIPROCAL ACCESS EASEMENT/AGREEMENT MAY BE REQUIRED TO INSURE THAT THE PROPOSED PRIVATE ACCESS ROADWAY WILL REMAIN OPEN TO THROUGH TRAFFIC AND EMERGENCY VEHICLES PRIOR TO FINAL OF BUILDING

MECHANICAL NOTES

- CONFORM WITH CURRENT ADOPTED CRC, CMC, SMACCNA, NFPA AND
- LOCAL REQUIREMENTS. DUCTWORK: SMACCNA "LOW VELOCITY DUCT CONSTRUCTION" NFPA STANDARD #90A. ALL TRANSVERSE DUCT PLENUM AND FITTING JOINTS SHALL BE SEALED WITH PRESSURE SENSITIVE NON-CLOTH TAPE MEETING THE REQUIREMENTS OF UL181, 181A, OR 181B, OR MASTIC TO PREVENT AIR LOSS. DUCTS SHALL BE INSULATED AS REQUIRED BY THE UMC. SEE FLOOR PLAN FOR F.A.U. AND FIREPLACES. DUCTS PENETRATING A WALL OR FLOOR-CEILING BETWEEN GARAGE & DWELLING TO BE MINIMUM 26 GAUGE
- METAL WITHOUT OPENING IN GARAGE. FIRE DAMPER REQUIRED OTHERWISE GRILLES AND REGISTERS, DIFFUSERS, ETC: SUBJECT TO OWNERS
- APPROVAL. "CARNES" OR EQUAL FANS: DIRECTLY VENTED TO OUTSIDE. BACK DRAFT DAMPERS ARE REQUIRED (PER TABLE 2-53V, TITLE 24 C.A.C.). 4. LAUNDRY DRYER VENT TO EXTERIOR TO BE 14 FEET MAXIMUM, LESS 2 FEET PER 90 DEGREE TURN PER CMC 504.3.2.2. IF VENT IS OVER 14' AN APPROVED POWER ASSISTED DEVICE IS REQUIRED. DRYER EXHAUST DUCT POWER VENTILATORS SHALL BE LISTED AND LABELED IN ACCORDANCE WITH UL 705 AND INSTALLED IN ACCORDANCE WITH THE MANUFACTURER'S INSTALLATION INSTRUCTIONS PER 2022 CMC, SECTION 504.2.2.3. SEE NOTE
- BATHROOM EXHAUST FANS (BATHROOM APPLIES TO ROOMS CONTAINING BATHTUB, SHOWER, OR TUB/SHOWER COMBINATION) WHICH EXHAUST DIRECTLY FROM BATHROOMS SHALL COMPLY WITH THE
- FOLLOWING (2022 CGBSC SEC. 4.506.1): a. FANS SHALL BE ENERGY STAR COMPLIANT AND BE DUCTED TO TERMINATE OUTSIDE THE BUILDING MIN 3' FROM OPENINGS. b. UNLESS FUNCTIONING AS A COMPONENT OF A WHOLE HOUSE
- CONTROL HUMIDITY CONTROLS SHALL BE CAPABLE OF ADJUSTMENT BETWEEN A RELATIVE HUMIDITY RANGE OF ≤ 50 PERCENT TO A MAXIMUM OF 80 PERCENT. A HUMIDITY CONTROL MAY UTILIZE

BE INTEGRAL(I.E. BUILT IN)

MANUAL OR AUTOMATIC MEANS OF ADJUSTMENT. A HUMIDITY CONTROL MAY BE A SEPARATE COMPONENT TO EXHAUST FAN AND IS NOT REQUIRED TO

VENTILATION SYSTEM, FANS MUST BE CONTROLLED BY A HUMIDITY

BATHROOM EXHAUST FANS SHALL PROVIDE MINIMUM 50 CFM EXHAUST RATE (2022 CMC TABLE 403.7). KITCHEN EXHAUST FANS SHALL PROVIDE MINIMUM 100 CFM EXHAUST RATE (2022 CMC TABLE 403.7)


Cathedral City

THESE PLANS ARE PROVIDED BY THE CITY OF CATHEDRAL CITY AS PART OF THE PRE-APPROVED ADU PROGRAM AND ARE PUBLIC DOMAIN. THERE CANNOT BE A CHARGE TO PROVIDE THESE PLANS. NO ALTERATIONS TO THESE PLANS ARE ALLOWED. ALL ALTERATIONS MUST BE DONE UNDER A SEPARATE PERMIT ONCE THE BUILDING PERMIT FOR THE ADU HAS BEEN ISSUED AND FINAL INSPECTION COMPLETED. IF YOU DO NOT HAVE THE CONSTRUCTION KNOWLEDGE AND EXPERIENCE TO CONTRUCT THESE PLANS WITHOUT FURTHER DETAILS, IT IS RECOMMENDED YOU HIRE A CONTRACTOR TO DO THE CONSTRUCTION. THE CITY WILL NOT PROVIDE FURTHER INFORMATION OR DETAILS AND BUILDING INSPECTORS WILL NOT PROVIDE STEP BY STEP INSTRUCTIONS IN THE FIELD.

ED 工

Z Ш

08/08/24 SHEET

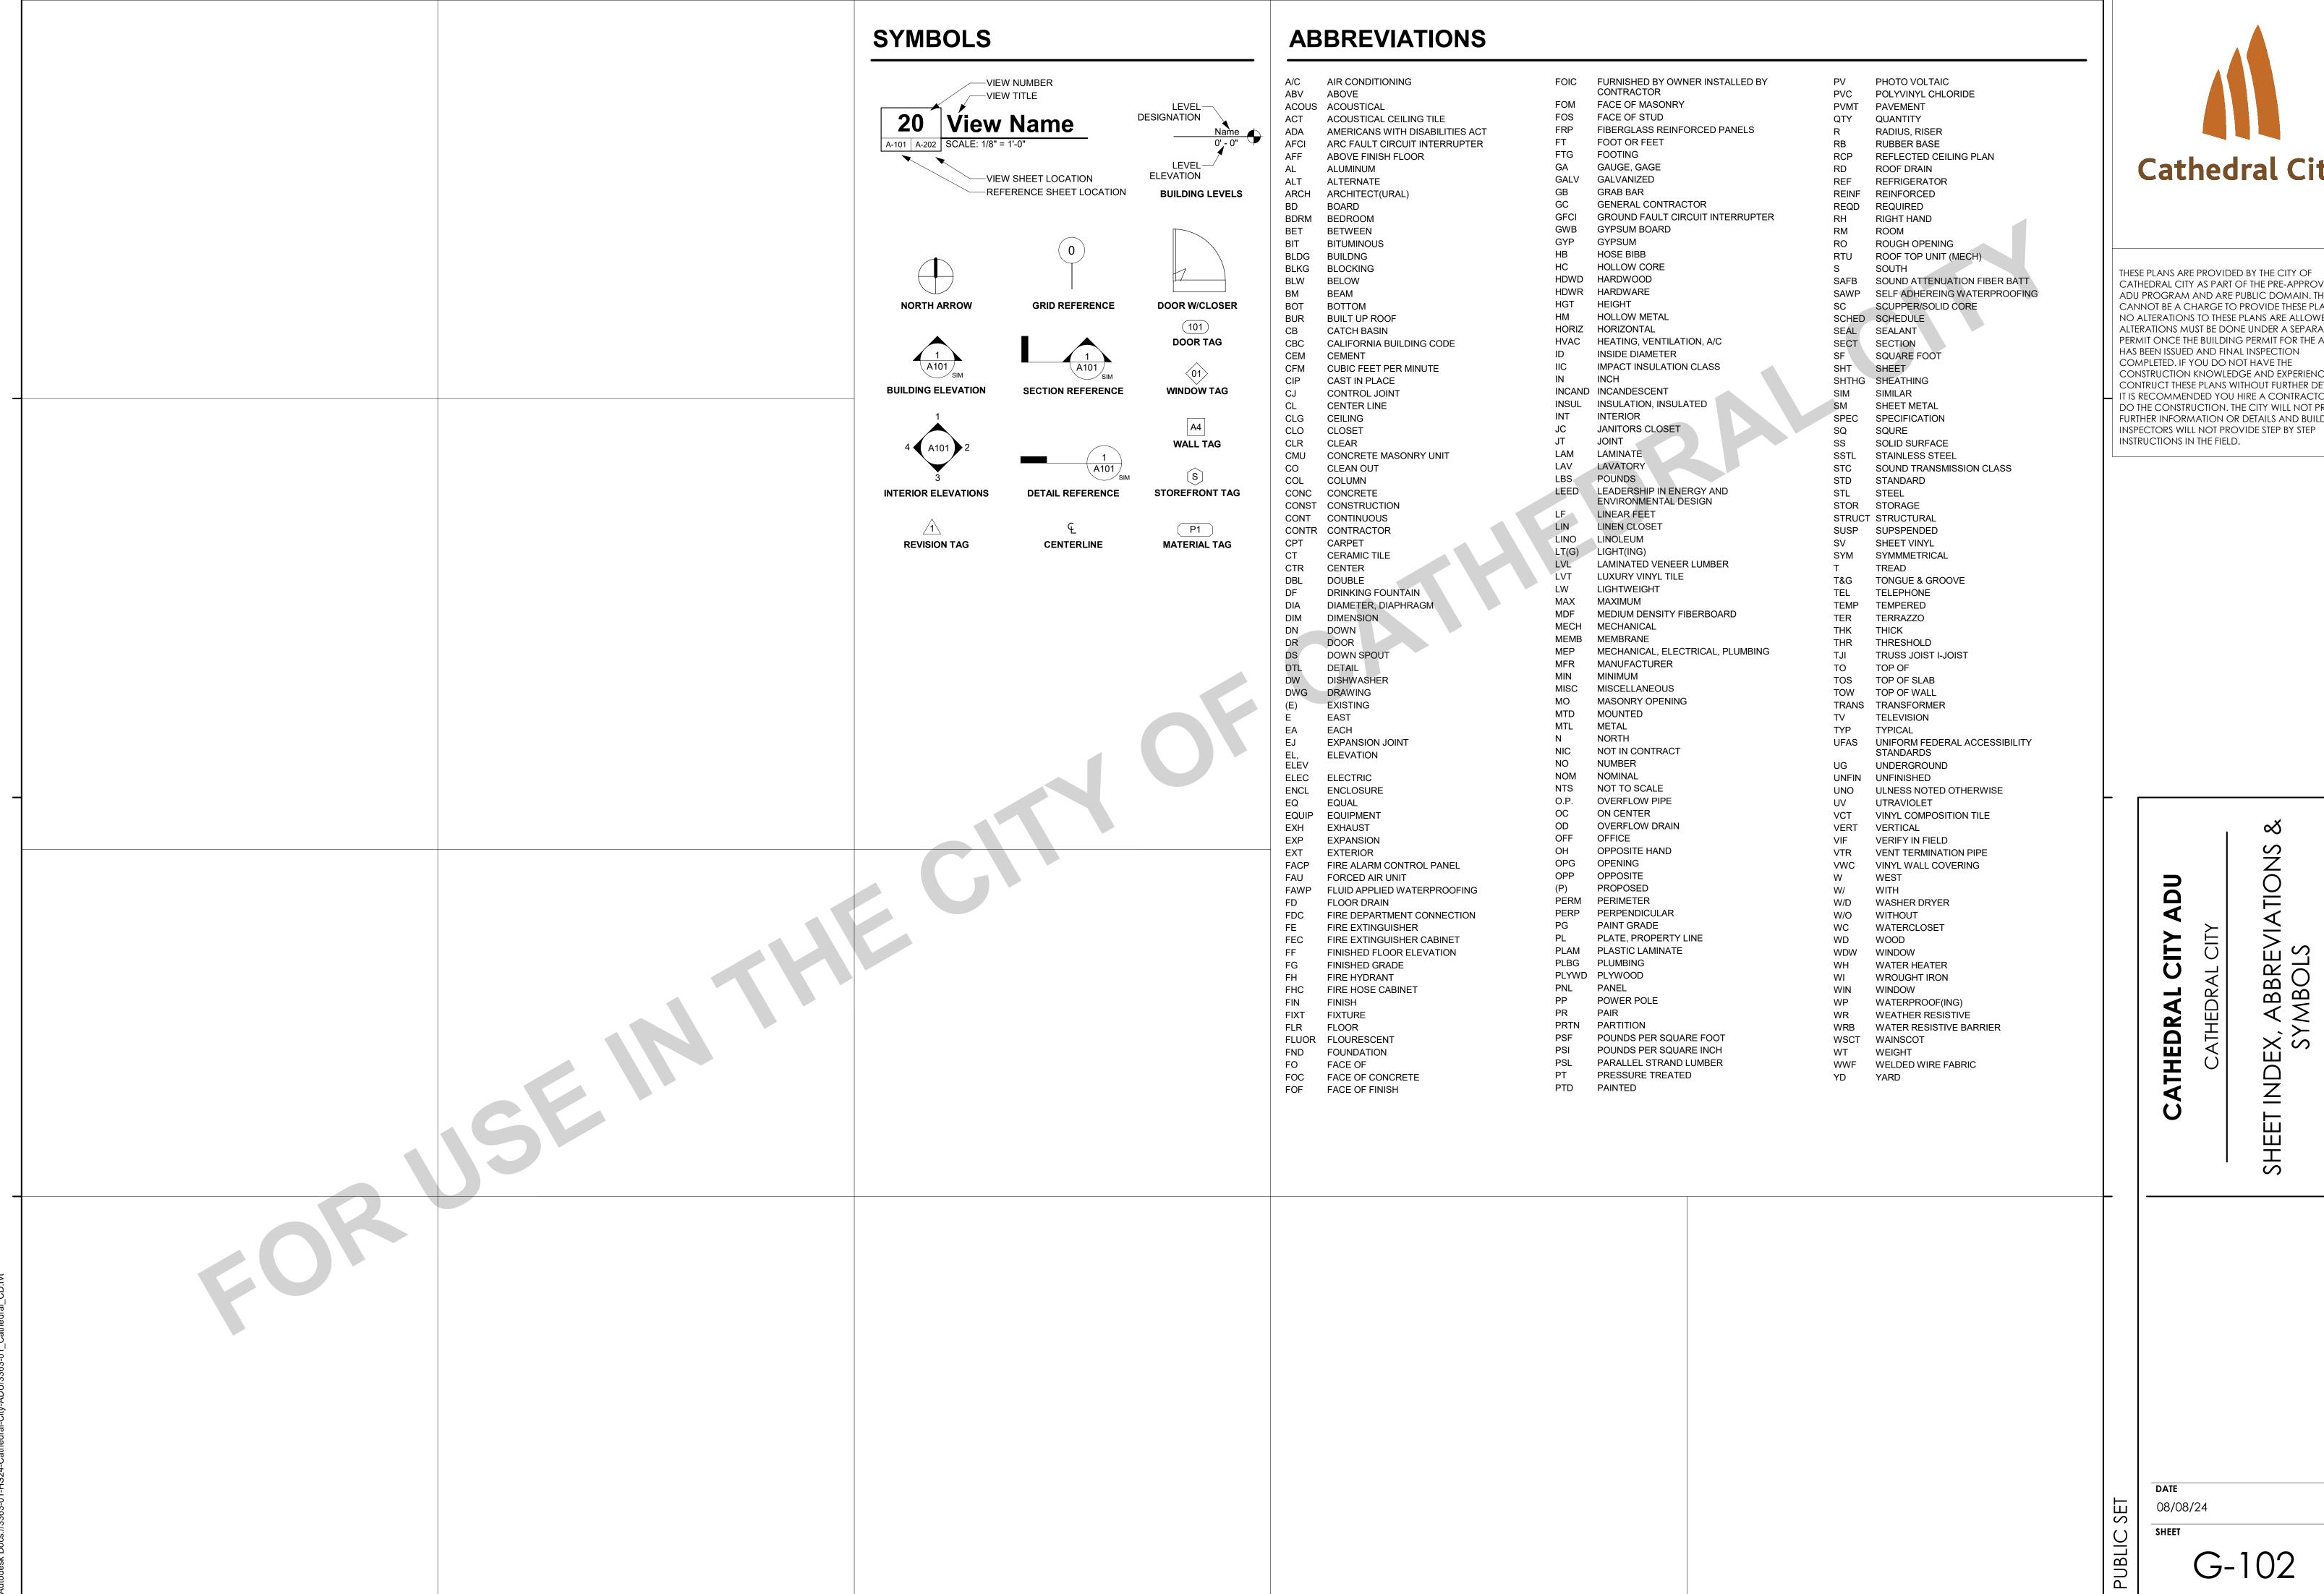

Cathedral City

CATHEDRAL CITY AS PART OF THE PRE-APPROVED ADU PROGRAM AND ARE PUBLIC DOMAIN. THERE CANNOT BE A CHARGE TO PROVIDE THESE PLANS. NO ALTERATIONS TO THESE PLANS ARE ALLOWED. ALL ALTERATIONS MUST BE DONE UNDER A SEPARATE PERMIT ONCE THE BUILDING PERMIT FOR THE ADU CONSTRUCTION KNOWLEDGE AND EXPERIENCE TO CONTRUCT THESE PLANS WITHOUT FURTHER DETAILS, IT IS RECOMMENDED YOU HIRE A CONTRACTOR TO DO THE CONSTRUCTION. THE CITY WILL NOT PROVIDE FURTHER INFORMATION OR DETAILS AND BUILDING

2022 CALIFORNIA GREEN BUILDING STANDARDS CODE

RESIDENTIAL MANDATORY MEASURES (SHEET 1)

CHAPTER 1 - ADMINISTRATION

SECTION 101 GENERAL

THESE REGULATIONS SHALL BE KNOWN AS THE CALIFORNIA GREEN BUILDING STANDARDS CODE AND MAY BE CITED AS SUCH AND WILL BE REFERRED TO HEREIN AS "THIS CODE." IT IS INTENDED THAT IT SHALL ALSO BE KNOWN AS THE CALGREEN CODE. THE CALIFORNIA GREEN BUILDING STANDARDS CODE IS PART 11 OF THIRTEEN PARTS OF THE OFFICIAL COMPILATION AND PUBLICATION OF THE ADOPTION, AMENDMENT AND REPEAL OF BUILDING REGULATIONS TO THE CALIFORNIA CODE OF REGULATIONS, TITLE 24, ALSO REFERRED TO AS THE CALIFORNIA BUILDING

THE PURPOSE OF THIS CODE IS TO IMPROVE PUBLIC HEALTH, SAFETY AND GENERAL WELFARE BY ENHANCING THE DESIGN AND CONSTRUCTION OF BUILDINGS THROUGH THE USE OF BUILDING CONCEPTS HAVING A REDUCED NEGATIVE IMPACT OR POSITIVE ENVIRONMENTAL IMPACT AND ENCOURAGING SUSTAINABLE CONSTRUCTION PRACTICES IN THE **FOLLOWING CATEGORIES:**

- PLANNING AND DESIGN. ENERGY EFFICIENCY.
- 3. WATER EFFICIENCY AND CONSERVATION.
- 4. MATERIAL CONSERVATION AND RESOURCE EFFICIENCY. ENVIRONMENTAL QUALITY.

101.3 SCOPE.

THE PROVISIONS OF THIS CODE SHALL APPLY TO THE PLANNING, DESIGN, OPERATION, CONSTRUCTION, USE AND OCCUPANCY OF EVERY NEWLY CONSTRUCTED BUILDING OR STRUCTURE, UNLESS OTHERWISE INDICATED IN THIS CODE, THROUGHOUT THE STATE OF CALIFORNIA.

IT IS NOT THE INTENT THAT THIS CODE SUBSTITUTE OR BE IDENTIFIED AS MEETING THE CERTIFICATION REQUIREMENTS OF ANY GREEN BUILDING

SECTION 102 CONSTRUCTION DOCUMENTS AND INSTALLATION VERIFICATION

102.1 SUBMITTAL DOCUMENTS.

CONSTRUCTION DOCUMENTS AND OTHER DATA SHALL BE SUBMITTED IN ONE OR MORE SETS WITH EACH APPLICATION FOR A PERMIT. WHERE SPECIAL CONDITIONS EXIST. THE ENFORCING AGENCY IS AUTHORIZED TO REQUIRE ADDITIONAL CONSTRUCTION DOCUMENTS TO BE PREPARED BY A LICENSED DESIGN PROFESSIONAL AND MAY BE SUBMITTED SEPARATELY.

EXCEPTION: THE ENFORCING AGENCY IS AUTHORIZED TO WAIVE THE SUBMISSION OF CONSTRUCTION DOCUMENTS AND OTHER DATA NOT REQUIRED TO BE PREPARED BY A LICENSED DESIGN PROFESSIONAL.

102.2 INFORMATION ON CONSTRUCTION DOCUMENTS.

CONSTRUCTION DOCUMENTS SHALL BE OF SUFFICIENT CLARITY TO INDICATE THE LOCATION, NATURE AND SCOPE OF THE PROPOSED GREEN BUILDING FEATURE AND SHOW THAT IT WILL CONFORM TO THE PROVISIONS OF THIS CODE. THE CALIFORNIA BUILDING STANDARDS CODE AND OTHER RELEVANT LAWS, ORDINANCES, RULES AND REGULATIONS AS DETERMINED BY THE ENFORCING AGENCY.

DOCUMENTATION OF CONFORMANCE FOR APPLICABLE GREEN BUILDING MEASURES SHALL BE PROVIDED TO THE ENFORCING AGENCY. ALTERNATE METHODS OF DOCUMENTATION SHALL BE ACCEPTABLE WHEN THE ENFORCING AGENCY FINDS THAT THE PROPOSED ALTERNATE DOCUMENTATION IS SATISFACTORY TO DEMONSTRATE SUBSTANTIAL CONFORMANCE WITH THE INTENT OF THE PROPOSED GREEN BUILDING

CHAPTER 3 - GREEN BUILDING

SECTION 301 GENERAL

BUILDINGS SHALL BE DESIGNED TO INCLUDE THE GREEN BUILDING MEASURES SPECIFIED AS MANDATORY IN THE APPLICATION CHECKLISTS CONTAINED IN THIS CODE. VOLUNTARY GREEN BUILDING MEASURES ARE ALSO INCLUDED IN THE APPLICATION CHECKLISTS AND MAY BE INCLUDED IN THE DESIGN AND CONSTRUCTION OF STRUCTURES COVERED BY THIS CODE, BUT ARE NOT REQUIRED UNLESS ADOPTED BY A CITY, COUNTY, OR CITY AND COUNTY AS SPECIFIED IN SECTION 101.7.

301.1.1 ADDITIONS AND ALTERATIONS. [HCD] THE MANDATORY PROVISIONS OF CHAPTER 4 SHALL BE APPLIED TO ADDITIONS OR ALTERATIONS OF EXISTING RESIDENTIAL BUILDINGS WHERE THE ADDITION OR ALTERATION INCREASES THE BUILDING'S CONDITIONED AREA, VOLUME, OR SIZE. THE REQUIREMENTS SHALL APPLY ONLY TO AND/OR WITHIN THE SPECIFIC AREA OF THE ADDITION OR ALTERATION.

THE MANDATORY PROVISIONS OF SECTION 4.106.4.2 MAY APPLY TO ADDITIONS OR ALTERATIONS OF EXISTING PARKING FACILITIES OR THE ADDITION OF NEW PARKING FACILITIES SERVING EXISTING MULTIFAMILY BUILDINGS. SEE SECTION 4.106.4.3 FOR APPLICATION.

NOTE: REPAIRS INCLUDING, BUT NOT LIMITED TO, RESURFACING. RESTRIPING, AND REPAIRING OR MAINTAINING EXISTING LIGHTING FIXTURES ARE NOT CONSIDERED ALTERATIONS FOR THE PURPOSE OF

301.2 LOW-RISE AND HIGH-RISE RESIDENTIAL BUILDINGS [HCD]. THE PROVISIONS OF INDIVIDUAL SECTIONS OF CALGREEN MAY APPLY TO EITHER LOW-RISE RESIDENTIAL BUILDINGS, HIGH-RISE RESIDENTIAL BUILDINGS, OR BOTH. INDIVIDUAL SECTIONS WILL BE DESIGNATED BY BANNERS TO INDICATE WHERE THE SECTION APPLIES SPECIFICALLY TO LOW-RISE ONLY (LR) OR HIGH-RISE ONLY (HR). WHEN THE SECTION APPLIES TO BOTH LOW-RISE AND HIGH-RISE BUILDINGS, NO BANNER WILL BE USED.

SECTION 302 MIXED OCCUPANCY BUILDINGS

302.1 MIXED OCCUPANCY BUILDINGS.

IN MIXED OCCUPANCY BUILDINGS, EACH PORTION OF A BUILDING SHALL COMPLY WITH THE SPECIFIC GREEN BUILDING MEASURES APPLICABLE TO EACH SPECIFIC OCCUPANCY.

CHAPTER 4 - RESIDENTIAL MANDATORY MEASURES

DIVISION 4.1 PLANNING AND DESIGN 4.106 SITE DEVELOPMENT

4.106.1 GENERAL.

PRESERVATION AND USE OF AVAILABLE NATURAL RESOURCES SHALL BE ACCOMPLISHED THROUGH EVALUATION AND CAREFUL PLANNING TO MINIMIZE NEGATIVE EFFECTS ON THE SITE AND ADJACENT AREAS. PRESERVATION OF SLOPES, MANAGEMENT OF STORM WATER DRAINAGE AND EROSION CONTROLS SHALL COMPLY WITH THIS SECTION.

4.106.2 STORM WATER DRAINAGE AND RETENTION DURING CONSTRUCTION PROJECTS WHICH DISTURB LESS THAN ONE ACRE OF SOIL AND ARE NOT PART OF A LARGER COMMON PLAN OF DEVELOPMENT WHICH IN TOTAL DISTURBS ONE ACRE OR MORE. SHALL MANAGE STORM WATER DRAINAGE DURING CONSTRUCTION. IN ORDER TO MANAGE STORM WATER DRAINAGE DURING CONSTRUCTION, ONE OR MORE OF THE FOLLOWING MEASURES SHALL BE IMPLEMENTED TO PREVENT FLOODING OF ADJACENT PROPERTY PREVENT EROSION AND RETAIN SOIL RUNOFF ON THE SITE. . RETENTION BASINS OF SUFFICIENT SIZE SHALL BE UTILIZED TO RETAIN

STORM WATER ON THE SITE. 2. WHERE STORM WATER IS CONVEYED TO A PUBLIC DRAINAGE SYSTEM, COLLECTION POINT, GUTTER OR SIMILAR DISPOSAL METHOD, WATER SHALL BE FILTERED BY USE OF A BARRIER SYSTEM, WATTLE OR OTHER

METHOD APPROVED BY THE ENFORCING AGENCY. 3. COMPLIANCE WITH A LAWFULLY ENACTED STORM WATER MANAGEMENT ORDINANCE.

4.106.3 GRADING AND PAVING

CONSTRUCTION PLANS SHALL INDICATE HOW THE SITE GRADING OR DRAINAGE SYSTEM WILL MANAGE ALL SURFACE WATER FLOWS TO KEEP WATER FROM ENTERING BUILDINGS. EXAMPLES OF METHODS TO MANAGE SURFACE WATER INCLUDE, BUT ARE NOT LIMITED TO, THE FOLLOWING:

- WATER COLLECTION AND DISPOSAL SYSTEMS
- FRENCH DRAINS WATER RETENTION GARDENS
- 5. OTHER WATER MEASURES WHICH KEEP SURFACE WATER AWAY FROM BUILDINGS AND AID IN GROUNDWATER RECHARGE. **EXCEPTIONS:** ADDITIONS AND ALTERATIONS NOT ALTERING THE
- 4.106.4 ELECTRIC VEHICLE (EV) CHARGING FOR NEW CONSTRUCTION NEW CONSTRUCTION SHALL COMPLY WITH SECTION 4.106.4.1, 4.106.4.2, OR 4.106.4.3. TO FACILITATE FUTURE INSTALLATION AND USE OF EV CHARGERS ELECTRIC VEHICLE SUPPLY EQUIPMENT (EVSE) SHALL BE INSTALLED IN ACCORDANCE WITH THE CALIFORNIA ELECTRICAL CODE, ARTICLE 625.

ON A CASE-BY-CASE BASIS, WHERE THE LOCAL ENFORCING AGENCY HAS DETERMINED EV CHARGING AND INFRASTRUCTURE ARE NOT FEASIBLE BASED UPON ONE OR MORE OF THE FOLLOWING CONDITIONS: 1.1. WHERE THERE IS NO LOCAL UTILITY POWER SUPPLY OR THE LOCAL UTILITY IS UNABLE TO SUPPLY ADEQUATE POWER. 1.2. WHERE THERE IS EVIDENCE SUITABLE TO THE LOCAL ENFORCING AGENCY SUBSTANTIATING THAT ADDITIONAL LOCAL UTILITY INFRASTRUCTURE DESIGN REQUIREMENTS, DIRECTLY RELATED TO THE IMPLEMENTATION OF SECTION 4.106.4, MAY ADVERSELY IMPACT THE CONSTRUCTION COST OF THE PROJECT.

2. ACCESSORY DWELLING UNITS (ADU) AND JUNIOR ACCESSORY DWELLING UNITS (JADU) WITHOUT ADDITIONAL PARKING FACILITIES.

4.106.4.1 NEW ONE- AND TWO-FAMILY DWELLINGS AND TOWNHOUSES WITH

ATTACHED PRIVATE GARAGES FOR EACH DWELLING UNIT, INSTALL A LISTED RACEWAY TO ACCOMODATE A DEDICATED 208/240-VOLT BRANCH CIRCUIT. THE RACEWAY SHALL NOT BE LESS THAN TRADE SIZE 1 (NOMINAL 1-INCH INSIDE DIAMTER). THE RACEWAY SHALL ORIGINATE AT THE MAIN SERVICE OR SUBPANEL AND SHALL TERMINATE INTO A LISTED CABINET, BOX OR OTHER ENCLOSURE IN CLOSE PROXIMITY TO THE PROPOSED LOCATION OF AN EV CHARGER, RACEWAYS ARE REQUIRED TO BE CONTINUOUS AT ENCLOSED, INACCESSIBLE OR CONCEALED AREAS AND SPACES. THE SERVICE PANEL AND/OR SUBPANEL SHALL PROVIDE CAPACITY TO INSTALL A 40-AMPERE MINIMUM DEDICATED BRANCH CIRCUIT AND SPACE(S) RESERVED TO PERMIT INSTALLATION OF A BRANCH CIRCUIT OVERCURRENT PROTECTION DEVICE.

4.106.4.1.1 IDENTIFICATION

THE SERVICE PANEL OR SUBPANEL CIRCUIT DIRECTORY SHALL IDENTIFY THE OVERCURRENT PROTECTIVE DEVICE SPACE(S) RESERVED FOR FUTURE EV CHARGING AS "EV CAPABLE". THE RACEWAY TERMINATION LOCATION SHALL BE PERMANENTLY AND VISIBLY MARKED AS "EV CAPABLE".

4.106.4.2 NEW MULTIFAMILY DWELLINGS, HOTELS AND MOTELS AND NEW

RESIDENTIAL PARKING FACILITIES WHEN PARKING IS PROVIDED, PARKING SPACES FOR NEW MULTIFAMILY DWELLINGS, HOTELS AND MOTELS SHALL MEET THE REQUIREMENTS OF SECTIONS 4.106.4.2.1 AND 4.106.4.2.2. CALCULATIONS FOR SPACES SHALL BE ROUNDED UP TO THE NEAREST WHOLE NUMBER. A PARKING SPACE SERVED BY ELECTRIC VEHICLE SUPPLY EQUIPMENT OR DESIGNED AS A FUTURE EV CHARGING SPACE SHALL COUNT AS AT LEAST ONE STANDARD AUTOMOBILE PARKING SPACE ONLY FOR THE PURPOSE OF COMPLYING WITH ANY APPLICABLE MINIMUM PARKING SPACE REQUIREMENTS ESTABLISHED BY A LOCAL JURISDICTION. SEE VEHICLE CODE SECTION 22511.2 FOR FURTHER DETAILS.

4.106.4.2.1 MULTIFAMILY DEVELOPMENT PROJECTS WITH LESS THAN 20 DWELLING UNITS; AND HOTELS AND MOTELS WITH LESS THAN 20 SLEEPING

UNITS OR GUEST ROOMS THE NUMBER OF DWELLING UNITS, SLEEPING UNITS OR GUEST ROOMS SHALL BE BASED ON ALL BUILDINGS ON A PROJECT SITE SUBJECT TO THIS

EV CAPABLE. TEN (10) PERCENT OF THE TOTAL NUMBER OF PARKING SPACES ON A BUILDING SITE, PROVIDED FOR ALL TYPES OF PARKING FACILITIES, SHALL BE ELECTRIC VEHICLE CHARGING SPACES (EV SPACES) CAPABLE OF SUPPORTING FUTURE LEVEL 2 EVSE. ELECTRICAL LOAD CALCULATIONS SHALL DEMONSTRATE THAT THE ELECTRICAL PANEL SERVICE CAPACITY AND ELECTRICAL SYSTEM, INCLUDING ANY ON-SITE DISTRIBUTION TRANSFORMER(S), HAVE SUFFICIENT CAPACITY TO SIMULTANEOUSLY CHARGE ALL EVS AT ALL REQUIRED EV SPACES AT A MINIMUM OF 40 AMPERES.

THE SERVICE PANEL OR SUBPANEL CIRCUIT DIRECTORY SHALL IDENTIFY THE OVERCURRENT PROTECTIVE DEVICE SPACE(S) RESERVED FOR FUTURE EV CHARGING PURPOSES AS "EV CAPABLE" IN ACCORDANCE WITH THE CALIFORNIA ELECTRICAL CODE.

EXCEPTIONS: 1. WHEN EV CHARGERS (LEVEL 2 EVSE) ARE INSTALLED IN A NUMBER EQUAL TO OR GREATER THAN THE REQUIRED NUMBER OF EV CAPABLE

2. WHEN EV CHARGERS (LEVEL 2 EVSE) ARE INSTALLED IN A NUMBER LESS THAN THE REQUIRED NUMBER OF EV CAPABLE SPACES, THE NUMBER OF EV CAPABLE SPACES REQUIRED MAY BE REDUCED BY A NUMBER EQUAL TO THE NUMBER OF EV CHARGERS INSTALLED.

a. CONSTRUCTION DOCUMENTS ARE INTENDED TO DEMONSTRATE THE PROJECT'S CAPABILITY AND CAPACITY FOR FACILITATING FUTURE EV

b. THERE IS NO REQUIREMENT FOR EV SPACES TO BE CONSTRUCTED OR AVAILABLE UNTIL RECEPTACLES FOR EV CHARGING OR EV CHARGERS ARE INSTALLED FOR USE.

2. EV READY. TWENTY-FIVE (25) PERCENT OF THE TOTAL NUMBER OF PARKING SPACES SHALL BE EQUIPPED WITH LOW POWER LEVEL 2 EV CHARGING RECEPTACLES. FOR MULTIFAMILY PARKING FACILITIES, NO MORE THAN ONE RECEPTACLE IS REQUIRED PER DWELLING UNIT WHEN MORE THAN ONE PARKING SPACE IS PROVIDED FOR USE BY A SINGLE DWELLING UNIT. **EXCEPTION:** AREAS OF PARKING FACILITIES SERVED BY PARKING LIFTS.

4.106.4.2.2 MULTIFAMILY DEVELOPMENT PROJECTS WITH 20 OR MORE DWELLING UNITS, HOTELS AND MOTELS WITH 20 OR MORE SLEEPING UNITS OR **GUEST ROOMS**

THE NUMBER OF DWELLING UNITS, SLEEPING UNITS OR GUEST ROOMS SHALL BE BASED ON ALL BUILDINGS ON A PROJECT SITE SUBJECT TO THIS SECTION.

1. **EV CAPABLE.** TEN (10) PERCENT OF THE TOTAL NUMBER OF PARKING SPACES ON A BUILDING SITE, PROVIDED FOR ALL TYPES OF PARKING FACILITIES, SHALL BE ELECTRIC VEHICLE CHARGING SPACES (EV SPACES) CAPABLE OF SUPPORTING FUTURE LEVEL 2 EVSE. ELECTRICAL LOAD CALCULATIONS SHALL DEMONSTRATE THAT THE ELECTRICAL PANEL SERVICE CAPACITY AND ELECTRICAL SYSTEM, INCLUDING ANY ON-SITE DISTRIBUTION TRANSFORMER(S), HAVE SUFFICIENT CAPACITY TO SIMULTANEOUSLY CHARGE ALL EVS AT ALL REQUIRED EV SPACES AT A MINIMUM OF 40 AMPERES.

THE SERVICE PANEL OR SUBPANEL CIRCUIT DIRECTORY SHALL IDENTIFY THE OVERCURRENT PROTECTIVE DEVICE SPACE(S) RESERVED FOR FUTURE EV CHARGING PURPOSES AS "EV CAPABLÉ" IN ACCORDANCE WITH THE CALIFORNIA ELECTRICAL CODE.

EXCEPTION: WHEN EV CHARGERS (LEVEL 2 EVSE) ARE INSTALLED IN A NUMBER GREATER THAN FIVE (5) PERCENT OF PARKING SPACES REQUIRED BY SECTION 4.106.4.2.2, ITEM 3, THE NUMBER OF EV CAPABLE SPACES REQUIRED MAY BE REDUCED BY A NUMBER EQUAL TO THE NUMBER OF EV CHARGERS INSTALLED OVER THE FIVE (5) PERCENT REQUIRED.

CONSTRUCTION DOCUMENTS SHALL SHOW LOCATIONS OF FUTURE EV

THERE IS NO REQUIREMENT FOR EV SPACES TO BE CONSTRUCTED OR AVAILABLE UNTIL RECEPTACLES FOR EV CHARGING OR EV CHARGERS ARE

2. EV READY. TWENTY-FIVE (25) PERCENT OF THE TOTAL NUMBER OF PARKING SPACES SHALL BE EQUIPPED WITH LOW POWER LEVEL 2 EV CHARGING RECEPTACLES. FOR MULTIFAMILY PARKING FACILITIES. NO MORE THAN ONE RECEPTACLE IS REQUIRED PER DWELLING UNIT WHEN MORE THAN ONE PARKING SPACE IS PROVIDED FOR USE BY A SINGLE DWELLING UNIT.

EXCEPTION: AREAS OF PARKING FACILITIES SERVED BY PARKING LIFTS.

3. EV CHARGERS. FIVE (5) PERCENT OF THE TOTAL NUMBER OF PARKING SPACES SHALL BE EQUIPPED WITH LEVEL 2 EVSE. WHERE COMMON USE PARKING IS PROVIDED, AT LEAST ONE EV CHARGER SHALL BE LOCATED IN THE COMMON USE PARKING AREA AND SHALL BE AVAILABLE FOR USE BY ALL RESIDENTS OR GUESTS.

WHEN LOW POWER LEVEL 2 EV CHARGING RECEPTACLES OR LEVEL 2 EVSE ARE INSTALLED BEYOND THE MINIMUM REQUIRED, AN AUTOMATIC LOAD MANAGEMENT SYSTEM (ALMS) MAY BE USED TO REDUCE THE MAXIMUM REQUIRED ELECTRICAL CAPACITY TO EACH SPACE SERVED BY THE ALMS. THE ELECTRICAL SYSTEM AND ANY ON-SITE DISTRIBUTION TRANSFORMERS SHALL HAVE SUFFICIENT CAPACITY TO DELIVER AT LEAST 3.3 KW SIMULTANEOUSLY TO EACH EV CHARGING STATION (EVCS) SERVED BY THE ALMS. THE BRANCH CIRCUIT SHALL HAVE A MINIMUM CAPACITY OF 40 AMPERES, AND INSTALLED EVSE SHALL HAVE A CAPACITY OF NOT LESS THAN 30 AMPERES. ALMS SHALL NOT BE USED TO REDUCE THE MINIMUM REQUIRED ELECTRICAL CAPACITY TO THE REQUIRED EV CAPABLE SPACES.

4.106.4.2.2.1 ELECTRIC VEHICLE CHARGING STATIONS (EVCS) ELECTRIC VEHICLE CHARGING STATIONS REQUIRED BY SECTION 4.106.4.2.2, ITEM 3, SHALL COMPLY WITH SECTION 4.106.4.2.2.1.

EXCEPTION: ELECTRIC VEHICLE CHARGING STATIONS SERVING PUBLIC ACCOMMODATIONS, PUBLIC HOUSING, MOTELS AND HOTELS SHALL NOT BE REQUIRED TO COMPLY WITH THIS SECTION, SEE CALIFORNIA BUILDING CODE, CHAPTER 11B, FOR APPLICABLE REQUIREMENTS.

4.106.4.2.2.1.1 LOCATION

EVCS SHALL COMPLY WITH AT LEAST ONE OF THE FOLLOWING OPTIONS: THE CHARGING SPACE SHALL BE LOCATED ADJACENT TO AN ACCESSIBLE PARKING SPACE MEETING THE REQUIREMENTS OF THE CALIFORNIA BUILDING CODE, CHAPTER 11A, TO ALLOW USE OF THE EV CHARGER FROM THE ACCESSIBLE PARKING SPACE.

THE CHARGING SPACE SHALL BE LOCATED ON AN ACCESSIBLE ROUTE, AS DEFINED IN THE CALIFORNIA BUILDING CODE, CHAPTER 2, TO THE BUILDING.

EXCEPTION: ELECTRIC VEHICLE CHARGING STATIONS DESIGNED AND CONSTRUCTED IN COMPLIANCE WITH THE CALIFORNIA BUILDING CODE. CHAPTER 11B, ARE NOT REQUIRED TO COMPLY WITH SECTION 4.106.4.2.2.1.1 AND SECTION 4.106.4.2.2.1.2, ITEM 3.

4.106.4.2.2.1.2 ELECTRIC VEHICLE CHARGING STATIONS (EVCS) DIMENSIONS THE CHARGING SPACES SHALL BE DESIGNED TO COMPLY WITH THE FOLLOWING:

- 1. THE MINIMUM LENGTH OF EACH EV SPACE SHALL BE 18 FEET 2. THE MINIMUM WIDTH OF EACH EV SPACE SHALL BE 9 FEET.
- 3. ONE IN EVERY 25 CHARGING SPACES, BUT NOT LESS THAN ONE, SHALL ALSO HAVE AN 8-FOOT WIDE MINIMUM AISLE. A 5-FOOT WIDE MINIMUM AISLE SHALL BE PERMITTED PROVIDED THE MINIMUM WIDTH OF THE EV SPACE IS 12 FEET.

a. SURFACE SLOPE FOR THIS EV SPACE AND THE AISLE SHALL NOT EXCEED 1 UNIT VERTICAL IN 48 UNITS HORIZONTAL (2.083 PERCENT SLOPE) IN ANY DIRECTION.

4.106.4.2.2.1.3 ACCESSIBLE EV SPACES

IN ADDITION TO THE REQUIREMENTS IN SECTIONS 4.106.4.2.2.1.1 AND 4.106.4.2.2.1.2, ALL EVSE, WHEN INSTALLED, SHALL COMPLY WITH THE ACCESSIBILITY PROVISIONS FOR EV CHARGERS IN THE CALIFORNIA BUILDING CODE, CHAPTER 11B. EV READY SPACES AND EVCS IN MULTIFAMILY DEVELOPMENTS SHALL COMPLY WITH CALIFORNIA BUILDING CODE, CHAPTER 11A, SECTION 1109A.

4.106.4.2.3 EV SPACE REQUIREMENTS

SINGLE EV SPACE REQUIRED. INSTALL A LISTED RACEWAY CAPABLE OF ACCOMMODATING A 208/240-VOLT DEDICATED BRANCH CIRCUIT. THE RACEWAY SHALL NOT BE LESS THAN TRADE SIZE 1 (NOMINAL 1-INCH INSIDE DIAMETER). THE RACEWAY SHALL ORIGINATE AT THE MAIN SERVICE OR SUBPANEL AND SHALL TERMINATE INTO A LISTED CABINET, BOX OR ENCLOSURE IN CLOSE PROXIMITY TO THE LOCATION OR THE PROPOSED LOCATION OF THE EV SPACE. CONSTRUCTION DOCUMENTS SHALL IDENTIFY THE RACEWAY TERMINATION POINT, RECEPTACLE OR CHARGER LOCATION, AS APPLICABLE. THE SERVICE PANEL AND/ OR SUBPANEL SHALL HAVE A 40-AMPERE MINIMUM DEDICATED BRANCH CIRCUIT, INCLUDING BRANCH CIRCUIT OVERCURRENT PROTECTIVE DEVICE INSTALLED, OR SPACE(S) RESERVED TO PERMIT INSTALLATION OF A BRANCH CIRCUIT OVERCURRENT

EXCEPTION: A RACEWAY IS NOT REQUIRED IF A MINIMUM 40-AMPERE 208/240-VOLT DEDICATED EV BRANCH CIRCUIT IS INSTALLED IN CLOSE PROXIMITY TO THE LOCATION OR THE PROPOSED LOCATION OF THE EV SPACE, AT THE TIME OF ORIGINAL CONSTRUCTION IN ACCORDANCE WITH THE CALIFORNIA ELECTRICAL CODE.

MULTIPLE EV SPACES REQUIRED. CONSTRUCTION DOCUMENTS SHALL INDICATE THE RACEWAY TERMINATION POINT AND THE LOCATION OF INSTALLED OR FUTURE EV SPACES, RECEPTACLES OR EV CHARGERS. CONSTRUCTION DOCUMENTS SHALL ALSO PROVIDE INFORMATION ON AMPERAGE OF INSTALLED OR FUTURE RECEPTACLES OR EVSE, RACEWAY METHOD(S), WIRING SCHEMATICS AND ELECTRICAL LOAD CALCULATIONS. PLAN DESIGN SHALL BE BASED UPON A 40-AMPERE MINIMUM BRANCH CIRCUIT. REQUIRED RACEWAYS AND RELATED COMPONENTS THAT ARE PLANNED TO BE INSTALLED UNDERGROUND, ENCLOSED, INACCESSIBLE OR IN CONCEALED AREAS AND SPACES SHALL BE INSTALLED AT THE TIME OF ORIGINAL CONSTRUCTION.

EXCEPTION: A RACEWAY IS NOT REQUIRED IF A MINIMUM 40-AMPERE 208/240-VOLT DEDICATED EV BRANCH CIRCUIT IS INSTALLED IN CLOSE PROXIMITY TO THE LOCATION OR THE PROPOSED LOCATION OF THE EV SPACE AT THE TIME OF ORIGINAL CONSTRUCTION IN ACCORDANCE WITH THE CALIFORNIA ELECTRICAL CODE.

4.106.4.2.4 IDENTIFICATION

THE SERVICE PANEL OR SUBPANEL CIRCUIT DIRECTORY SHALL IDENTIFY THE OVERCURRENT PROTECTIVE DEVICE SPACE(S) RESERVED FOR FUTURE EV CHARGING PURPOSES AS "EV CAPABLÉ" IN ACCORDANCE WITH THE CALIFORNIA ELECTRICAL CODE.

4.106.4.2.5 ELECTRIC VEHICLE READY SPACE SIGNAGE

ELECTRIC VEHICLE READY SPACES SHALL BE IDENTIFIED BY SIGNAGE OR PAVEMENT MARKINGS. IN COMPLIANCE WITH CALTRANS TRAFFIC OPERATIONS POLICY DIRECTIVE 13-01 (ZERO EMISSION VEHICLE SIGNS AND PAVEMENT MARKINGS) OR ITS SUCCESSOR(S).

4.106.4.3 ELECTRIC VEHICLE CHARGING FOR ADDITIONS AND ALTERATIONS OF PARKING FACILITIES SERVING EXISTING MULTIFAMILY BUILDINGS

WHEN NEW PARKING FACILITIES ARE ADDED, OR ELECTRICAL SYSTEMS OR LIGHTING OF EXISTING PARKING FACILITIES ARE ADDED OR ALTERED AND THE WORK REQUIRES A BUILDING PERMIT, TEN (10) PERCENT OF THE TOTAL NUMBER OF PARKING SPACES ADDED OR ALTERED SHALL BE ELECTRIC VEHICLE CHARGING SPACES (EV SPACES) CAPABLE OF SUPPORTING FUTURE LEVEL 2 EVSE.

1. CONSTRUCTION DOCUMENTS ARE INTENDED TO DEMONSTRATE THE PROJECT'S CAPABILITY AND CAPACITY FOR FACILITATING FUTURE EV CHARGING.

2. THERE IS NO REQUIREMENT FOR EV SPACES TO BE CONSTRUCTED OR AVAILABLE UNTIL EV CHARGERS ARE INSTALLED FOR USE.

DIVISION 4.2 ENERGY EFFICIENCY

4.201 GENERAL

4.201.1 SCOPE.

FOR THE PURPOSES OF MANDATORY ENERGY EFFICIENCY STANDARDS IN THIS CODE, THE CALIFORNIA ENERGY COMMISSION WILL CONTINUE TO ADOPT MANDATORY STANDARDS.

DIVISION 4.3 WATER EFFICIENCY AND CONSERVATION

4.303 INDOOR WATER USE

4.303.1 WATER CONSERVING PLUMBING FIXTURES AND FITTINGS PLUMBING FIXTURES (WATER CLOSETS AND URINALS) AND FITTINGS (FAUCETS AND SHOWERHEADS) SHALL COMPLY WITH THE FOLLOWING:

4.303.1.1 WATER CLOSETS

THE EFFECTIVE FLUSH VOLUME OF ALL WATER CLOSETS SHALL NOT EXCEED 1.28 GALLONS PER FLUSH, TANK-TYPE WATER CLOSETS SHALL BE CERTIFIED TO THE PERFORMANCE CRITERIA OF THE U.S. EPA WATERSENSE SPECIFICATION FOR TANK TYPE TOILET.

NOTE: THE EFFECTIVE FLUSH VOLUME OF DUAL FLUSH TOILETS IS DEFINED AS THE COMPOSITE. AVERAGE FLUSH VOLUME OF TWO REDUCED FLUSHES AND ONE FULL FLUSH.

4.303.1.2 URINALS

THE EFFECTIVE FLUSH VOLUME OF WALL-MOUNTED URINALS SHALL NOT EXCEED 0.125 GALLONS PER FLUSH. THE EFFECTIVE FLUSH VOLUME OF ALL OTHER URINALS SHALL NOT EXCEED 0.5 GALLONS PER

4.303.1.3 SHOWERHEADS

4.303.1.3.1 SINGLE SHOWERHEAD SHOWERHEADS SHALL HAVE A MAXIMUM FLOW RATE OF NOT MORE THAN 1.8 GALLONS PER MINUTE AT 80 PSI, SHOWERHEADS SHALL BE CERTIFIED TO THE PERFORMANCE CRITERIA OF THE U.S. EPA

WATERSENSE SPECIFICATION FOR SHOWERHEADS. 4.303.1.3.2 MULTIPLE SHOWERHEADS SERVING ONE SHOWER

WHEN A SHOWER IS SERVED BY MORE THAN ONE SHOWERHEAD, THE COMBINED FLOW RATE OF ALL SHOWERHEADS AND/OR OTHER SHOWER OUTLETS CONTROLLED BY A SINGLE VALVE SHALL NOT EXCEED 1.8 GALLONS PER MINUTE AT 80 PSI, OR THE SHOWER SHALL BE DESIGNED TO ALLOW ONLY ONE SHOWER OUTLET TO BE IN OPERATION AT A TIME.

NOTE: A HAND HELD SHOWER SHALL BE CONSIDERED A SHOWERHEAD.

4.303.1.4 FAUCETS

4.303.1.4.1 RESIDENTIAL LAVATORY FAUCETS

THE MAXIMUM FLOW RATE OF RESIDENTIAL LAVATORY FAUCETS SHALL NOT EXCEED 1.2 GALLONS PER MINUTE AT 60 PSI. THE MINIMUM FLOW RATE OF RESIDENTIAL LAVATORY FAUCETS SHALL NOT BE LESS THAN 0.8 GALLONS PER MINUTE AT 20 PSI.

4.303.1.4.2 LAVATORY FAUCETS IN COMMON AND PUBLIC USE AREAS THE MAXIMUM FLOW RATE OF LAVATORY FAUCETS INSTALLED IN COMMON AND PUBLIC USE AREAS (OUTSIDE OF DWELLINGS OR SLEEPING UNITS) IN RESIDENTIAL BUILDINGS SHALL NOT EXCEED 0.5 GALLONS PER MINUTE AT 60 PSI.

4.303.1.4.3 METERING FAUCETS METERING FAUCETS WHEN INSTALLED IN RESIDENTIAL BUILDINGS

4.303.1.4.4 KITCHEN FAUCETS THE MAXIMUM FLOW RATE OF KITCHEN FAUCETS SHALL NOT EXCEED 1.8 GALLONS PER MINUTE AT 60 PSI. KITCHEN FAUCETS MAY TEMPORARILY INCREASE THE FLOW ABOVE THE MAXIMUM RATE, BUT NOT TO EXCEED 2.2 GALLONS PER MINUTE AT 60 PSI, AND MUST DEFAULT TO A MAXIMUM FLOW RATE OF 1.8 GALLONS PER MINUTE

SHALL NOT DELIVER MORE THAN 0.2 GALLONS PER CYCLE.

NOTE: WHERE COMPLYING FAUCETS ARE UNAVAILABLE, AERATORS OR OTHER MEANS MAY BE USED TO ACHIEVE REDUCTION.

4.303.2 SUBMETERS FOR MULTIFAMILY BUILDINGS AND DWELLING UNITS IN MIXED-USE RESIDENTIAL/COMMERCIAL BUILDINGS SUBMETERS SHALL BE INSTALLED TO MEASURE WATER USAGE OF INDIVIDUAL RENTAL DWELLING UNITS IN ACCORDANCE WITH THE CALIFORNIA PLUMBING CODE.

4.303.2 SUBMETERS FOR MULTIFAMILY BUILDINGS AND DWELLING UNITS IN MIXED-USE RESIDENTIAL/COMMERCIAL BUILDINGS

SUBMETERS SHALL BE INSTALLED TO MEASURE WATER USAGE OF INDIVIDUAL RENTAL DWELLING UNITS IN ACCORDANCE WITH THE CALIFORNIA PLUMBING CODE.

4.303.3 STANDARDS FOR PLUMBING FIXTURES AND FITTINGS

PLUMBING FIXTURES AND FITTINGS SHALL BE INSTALLED IN ACCORDANCE WITH THE CALIFORNIA PLUMBING CODE, AND SHALL MEET THE APPLICABLE STANDARDS REFERENCED IN TABLE 1701.1 OF THE CALIFORNIA PLUMBING

THIS TABLE COMPILES THE DATA IN SECTION 4.303.1 AND IS INCLUDED AS A

TABLE - MAXIMUM FIXTURE WATER USE FLOW RATE **FIXTURE TYPE** SHOWER HEADS (RESIDENTIAL) 1.8 GMP @ 80 PSI LAVATORY FAUCETS MAX. 1.2 GPM @ 60 PSI (RESIDENTIAL) MIN. 0.8 GPM @ 20 PSI LAVATORY FAUCETS IN COMMON & PUBLIC 0.5 GPM @ 60 PSI USE AREAS KITCHEN FAUCETS 1.8 GPM @ 60 PSI 0.2 GAL/CYCLE METERING FAUCETS WATER CLOSET 1.28 GAL/FLUSH URINALS 0.125 GAL/FLUSH

4.304 OUTDOOR WATER USE

4.304.1 OUTDOOR POTABLE WATER USE IN LANDSCAPE AREAS

RESIDENTIAL DEVELOPMENTS SHALL COMPLY WITH A LOCAL WATER EFFICIENT LANDSCAPE ORDINANCE OR THE CURRENT CALIFORNIA DEPARTMENT OF WATER RESOURCES' MODEL WATER EFFICIENT LANDSCAPE ORDINANCE (MWELO), WHICHEVER IS MORE STRINGENT.

1. THE MODEL WATER EFFICIENT LANDSCAPE ORDINANCE (MWELO) IS LOCATED IN THE CALIFORNIA CODE OF REGULATIONS, TITLE 23, CHAPTER 2.7, DIVISION 2.

MWELO AND SUPPORTING DOCUMENTS, INCLUDING A WATER BUDGET CALCULATOR, ARE AVAILABLE AT: HTTPS:// WWW.WATER.CA.GOV/

DIVISION 4.4 MATERIAL CONSERVATION AND RESOURCE EFFICIENCY

4.406 ENHANCED DURABILITY AND REDUCED MAINTENANCE

ANNULAR SPACES AROUND PIPES, ELECTRIC CABLES, CONDUITS OR OTHER OPENINGS IN SOLE/BOTTOM PLATES AT EXTERIOR WALLS SHALL BE PROTECTED AGAINST THE PASSAGE OF RODENTS BY LCOSING SUCH OPENINGS WITH CEMENT MORTAR, CONCRETE MASONRY OR A SIMILAR METHOD ACCEPTABLE TO THE ENFORCING AGENCY.

4.408 CONSTRUCTION WASTE REDUCTION, DISPOSAL AND RECYCLING

4.408.1 CONSTRUCTION WASTE MANAGEMENT

RECYCLE AND/OR SALVAGE FOR REUSE A MINIMUM OF 65 PERCENT OF THE NONHAZARDOUS CONSTRUCTION AND DEMOLITION WASTE IN ACCORDANCE WITH EITHER SECTION 4.408.2, 4.408.3, OR 4.408.4, OR MEET A MORE STRINGENT LOCAL CONSTRUCTION AND DEMOLITION WASTE MANAGEMENT ORDINANCE.

- 1. EXCAVATED SOIL AND LAND-CLEARING DEBRIS. 2. ALTERNATE WASTE REDUCTION METHODS DEVELOPED BY WORKING WITH LOCAL AGENCIES IF DIVERSION OR RECYCLE FACILITIES CAPABLE OF COMPLIANCE WITH THIS ITEM DO NOT EXIST OR ARE NOT LOCATED REASONABLY CLOSE TO THE JOBSITE.
- 3. THE ENFORCING AGENCY MAY MAKE ACCEPTIONS TO THE REQUIREMENTS OF THIS SECTION WHEN ISOLATED JOBSITES ARE LOCATED IN AREAS BEYOND THE HAUL BOUNDARIES OF THE DIVERSION FACILITY.

4.408.2 CONSTRUCTION WASTE MANAGEMENT PLAN

SUBMIT A CONSTRUCTION WASTE MANAGEMENT PLAN IN COMFORMANCE WITH ITEMS 1 THROUGH 5. THE CONSTRUCTION WASTE MANAGEMENT PLAN SHALL BE UPDATED AS NECESSARY AND SHALL BE AVAILABLE DURING CONSTRUCTION FOR EXAMINATION BY THE ENFORCING AGENCY.

1. IDENTIFY THE CONSTRUCTION AND DEMOLITION WASTE MATERIALS

TO BE DIVERTED FROM DISPOSAL BY RECYCLING, REUSE ON THE PROJECT OR SALVAGE FOR FUTURE USE OR SALE. 2. SPECIFY IF CONSTRUCTION AND DEMOLITION WASTE MATERIALS

WILL BE SORTED ON-SITE (SOURCE-SEPARATED) OR BULK MIXED (SINGLE STREAM).

3. IDENTIFY DIVERSION FACILITIES WHERE THE CONSTRUCTION AND DEMOLITION WASTE MATERIAL WILL BE TAKEN. . IDENTIFY CONSTRUCTION METHODS EMPLOYED TO REDUCE THE AMOUNT OF CONSTRUCTION AND DEMOLITION WASTE GENERATED.

5. SPECIFY THAT THE AMOUNT OF CONSTRUCTION AND DEMOLITION

WASTE MATERIAL DIVERTED SHALL BE CALCULATED BY WEIGHT OR

VOLUME, BUT NOT BY BOTH.

4.408.3 WASTE MANAGEMENT COMPANY. UTILIZE A WASTE MANAGEMENT COMPANY, APPROVED BY THE ENFORCING AGENCY, WHICH CAN PROVIDE VERIFIABLE DOCUMENTATION THAT THE PERCENTAGE OF CONSTRUCTION AND DEMOLITION WASTE MATERIAL DIVERTED FROM THE LANDFILL COMPLIES WITH SECTION 4.408.1. NOTE: THE OWNER OR CONTRACTOR MAY MAKE THE DETERMINATION IF

DIVERTED BY A WASTE MANAGEMENT COMPANY.

4.408.4 WASTE STREAM REDUCTION ALTERNATIVE [LR]. PROJECTS THAT GENERATE A TOTAL COMBINED WEIGHT OF CONSTRUCTION AND DEMOLITION WASTE DISPOSED OF IN LANDFILLS. WHICH DO NOT EXCEED 3.4 POUNDS PER SQUARE FOOT OF THE BUILDING AREA SHALL MEET THE MINIMUM 65 PERCENT CONSTRUCTION WASTE REDUCTION REQUIREMENT IN SECTION 4.408.1.

THE CONSTRUCTION AND DEMOLITION WASTE MATERIALS WILL BE

4.408.4.1 WASTE STREAM REDUCTION ALTERNATIVE

PROJECTS THAT GENERATE A TOTAL COMBINED WEIGHT OF CONSTRUCTION AND DEMOLITION WASTE DISPOSED OF IN LANDFILLS, WHICH DO NOT EXCEED 2 POUNDS PER SQUARE FOOT OF THE BUILDING AREA, SHALL MEET THE MINIMUM 65-PERCENT CONSTRUCTION WASTE REDUCTION REQUIREMENT IN SECTION 4.408.1.

4.408.5 DOCUMENTATION

DOCUMENTATION SHALL BE PROVIDED TO THE ENFORCING AGENCY WHICH DEMONSTRATES COMPLIANCE WITH SECTION 4.408.2, ITEMS 1 THOUGH 5, SECTION 4.408.3 OR SECTION 4.408.4

2. MIXED CONSTRUCTION AND DEMOLITION DEBRIS (C&D)

1. SAMPLE FORMS FOUND IN "A GUIDE TO THE CALIFORNIA GREEN BUILDING STANDARDS CODE (RESIDENTIAL)" LOCATED AT WWW.HCD.CA.GOV/CALGREEN.HTML MAY BE USED TO ASSIST IN DOCUMENTING COMPLIANCE WITH THIS SECTION.

OF RESOURCES RECYCLING AND RECOVERY (CALRECYCLE).

PROCESSORS CAN BE LOCATED AT THE CALIFORNIA DEPARTMENT

THESE PLANS ARE PROVIDED BY THE CITY OF CATHEDRAL CITY AS PART OF THE PRE-APPROVED ADU PROGRAM AND ARE PUBLIC DOMAIN. THERE CANNOT BE A CHARGE TO PROVIDE THESE PLANS. NO ALTERATIONS TO THESE PLANS ARE ALLOWED. ALL ALTERATIONS MUST BE DONE UNDER A SEPARATE PERMIT ONCE THE BUILDING PERMIT FOR THE ADU HAS BEEN ISSUED AND FINAL INSPECTION COMPLETED. IF YOU DO NOT HAVE THE CONSTRUCTION KNOWLEDGE AND EXPERIENCE TO CONTRUCT THESE PLANS WITHOUT FURTHER DETAILS, IT IS RECOMMENDED YOU HIRE A CONTRACTOR TO DO THE CONSTRUCTION. THE CITY WILL NOT PROVIDE FURTHER INFORMATION OR DETAILS AND BUILDING INSPECTORS WILL NOT PROVIDE STEP BY STEP INSTRUCTIONS IN THE FIELD.

H

08/08/24

SHEET

2022 CALIFORNIA GREEN BUILDING STANDARDS CODE

RESIDENTIAL MANDATORY MEASURES (SHEET 2)

4.410 BUILDING MAINTENANCE AND OPERATION

4.410.1 OPERATION AND MAINTENANCE MANUAL AT THE TIME OF FINAL INSPECTION, A MANUAL, COMPACT DISC, WEB-BASED REFERENCE OR OTHER MEDIA ACCEPTABLE TO THE ENFORCING AGENCY

- 1. DIRECTIONS TO THE OWNER OR OCCUPANT THAT THE MANUAL SHALL REMAIN WITH THE BUILDING THROUGHOUT THE LIFE CYCLE
- OF THE STRUCTURE. 2. OPERATION AND MAINTENANCE INSTRUCTIONS FOR THE

WHICH INCLUDES ALL OF THE FOLLOWING SHALL BE PLACED IN THE

- FOLLOWING: a. EQUIPMENT AND APPLIANCES, INCLUDING WATER-SAVING DEVICES AND SYSTEMS, HVAC SYSTEMS, PHOTOVOLTAIC SYSTEMS, ELECTRIC VEHICLE CHARGERS, WATER-HEATING SYSTEMS AND OTHER MAJOR APPLIANCES AND EQUIPMENT.
- b. ROOF AND YARD DRAINAGE, INCLUDING GUTTERS AND DOWNSPOUTS. c. SPACE CONDITIONING SYSTEMS, INCLUDING CONDENSERS AND
- AIR FILTERS.
- d. LANDSCAPE IRRIGATION SYSTEMS.
- e. WATER REUSE SYSTEMS.
- 3. INFORMATION FROM LOCAL UTILITY, WATER AND WASTE RECOVERY PROVIDERS ON METHODS TO FURTHER REDUCE RESOURCE CONSUMPTION, INCLUDING RECYCLE PROGRAMS AND LOCATIONS. 4. PUBLIC TRANSPORTATION AND/OR CARPOOL OPTIONS AVAILABLE IN
- 5. EDUCATIONAL MATERIAL ON THE POSITIVE IMPACTS OF AN INTERIOR RELATIVE HUMIDITY BETWEEN 30-60 PERCENT AND WHAT METHODS AN OCCUPANT MAY USE TO MAINTAIN THE RELATIVE HUMIDITY
- LEVEL IN THAT RANGE. 6. INFORMATION ABOUT WATER-CONSERVING LANDSCAPE AND IRRIGATION DESIGN AND CONTROLLERS WHICH CONSERVE WATER. INSTRUCTIONS FOR MAINTAINING GUTTERS AND DOWNSPOUTS AND
- THE IMPORTANCE OF DIVERTING WATER AT LEAST 5 FEET AWAY FROM THE FOUNDATION. 8. INFORMATION ON REQUIRED ROUTINE MAINTENANCE MEASURES,
- INCLUDING, BUT NOT LIMITED TO, CAULKING, PAINTING, GRADING AROUND THE BUILDING, ETC. 9. INFORMATION ABOUT STATE SOLAR ENERGY AND INCENTIVE
- PROGRAMS AVAILABLE. 10. A COPY OF ALL SPECIAL INSPECTION VERIFICATIONS REQUIRED BY
- THE ENFORCING AGENCY OR THIS CODE. 11. INFORMATION FROM CAL FIRE ON MAINTENANCE OF DEFENSIBLE
- SPACE AROUND RESIDENTIAL STRUCTURES.
- 12. INFORMATION AND/OR DRAWINGS IDENTIFYING THE LOCATION OF GRAB BAR REINFORCEMENTS.

4.410.2 RECYCLING BY OCCUPANTS.

THE AREA

WHERE 5 OR MORE MULTIFAMILY DWELLING UNITS ARE CONSTRUCTED ON A BUILDING SITE, PROVIDE READILY ACCESSIBLE AREA(S) THAT SERVES ALL BUILDINGS ON THE SITE AND IS IDENTIFIED FOR THE DEPOSITING, STORAGE AND COLLECTION OF NON-HAZARDOUS MATERIALS FOR RECYCLING, INCLUDING (AT A MINIMUM) PAPER, CORRUGATED CARDBOARD, GLASS, PLASTICS, ORGANIC WASTE, AND METALS, OR MEEL A LAWFULLY ENACTED LOCAL RECYCLING ORDINANCE, IF MORE RESTRICTIVE.

RURAL JURISDICTIONS THAT MEET AND APPLY FOR THE EXEMPTION IN PUBLIC RESOURCES CODE SECTION 42649.82 (A)(2)(A) ET SEQ. ARE NOT REQUIRED TO COMPLY WITH THE ORGANIC WASTE PORTION OF THIS

DIVISION 4.5 ENVIROMENTAL QUALITY

4.501 GENERAL

4.501.1 SCOPE THE PROVISIONS OF THIS CHAPTER SHALL OUTLINE MEANS OF REDUCING THE QUANTITY OF AIR CONTAMINANTS THAT ARE ODOROUS, IRRITATING AND/OR HARMFUL TO THE COMFORT AND WELL-BEING OF A BUILDING'S INSTALLERS, OCCUPANTS AND NEIGHBORS.

4.503 FIREPLACES

4.503.1 GENERAL

ANY INSTALLED GAS FIREPLACE SHALL BE A DIRECT-VENT SEALED-COMBUSTION TYPE. ANY INSTALLED WOODSTOVE OR PELLET STOVE SHALL COMPLY WITH U.S. EPA NEW SOURCE PERFORMANCE STANDARDS (NSPS) EMISSION LIMITS AS APPLICABLE, AND SHALL HAVE A PERMANENT LABEL INDICATING THEY ARE CERTIFIED TO MEET THE EMISSION LIMITS. WOODSTOVES, PELLET STOVES AND FIREPLACES SHALL ALSO COMPLY WITH APPLICABLE LOCAL ORDINANCES.

4.504 POLLUTANT CONTROL

4.504.1 COVERING OF DUCT OPENINGS AND PROTECTION OF MECHANICAL

EQUIPMENT DURING CONSTRUCTION AT THE TIME OF ROUGH INSTALLATION, DURING STORAGE ON THE CONSTRUCTION SITE AND UNTIL FINAL STARTUP OF THE HEATING, COOLING AND VENTILATING EQUIPMENT, ALL DUCT AND OTHER RELATED AIR

DISTRIBUTION COMPONENT OPENINGS SHALL BE COVERED WITH TAPE, PLASTIC, SHEETMETAL OR OTHER METHODS ACCEPTABLE TO THE ENFORCING AGENCY TO REDUCE THE AMOUNT OF WATER, DUST AND DEBRIS, WHICH MAY ENTER THE SYSTEM.

4.504.2 FINISH MATERIAL POLLUTANT CONTROL

FINISH MATERIALS SHALL COMPLY WITH THIS SECTION.

4.504.2.1 ADHESIVES, SEALANTS AND CAULKS ADHESIVES, SEALANTS AND CAULKS USED ON THE PROJECT SHALL MEET THE REQUIREMENTS OF THE FOLLOWING STANDARDS UNLESS MORE STRINGENT LOCAL OR REGIONAL AIR POLLUTION OR AIR QUALITY MANAGEMENT DISTRICT RULES APPLY:

- 1. ADHESIVES, ADHESIVE BONDING PRIMERS, ADHESIVE PRIMERS, SEALANTS, SEALANT PRIMERS, AND CAULKS SHALL COMPLY WITH LOCAL OR REGIONAL AIR POLLUTION CONTROL OR AIR QUALITY MANAGEMENT DISTRICT RULES WHERE APPLICABLE OR SCAQMD RULE 1168 VOC LIMITS, AS SHOWN IN TABLE 4.504.1 OR 4.504.2, AS APPLICABLE. SUCH PRODUCTS ALSO SHALL COMPLY WITH THE RULE 1168 PROHIBITION ON THE USE OF CERTAIN TOXIC COMPOUNDS (CHLOROFORM, ETHYLENE DICHLORIDE, METHYLENE CHLORIDE, PERCHLOROETHYLENE AND TRICHLOROETHYLENE), EXCEPT FOR AEROSOL PRODUCTS, AS
- SPECIFIED IN SUBSECTION 2 BELOW. 2. AEROSOL ADHESIVES, AND SMALLER UNIT SIZES OF ADHESIVES, AND SEALANT OR CAULKING COMPOUNDS (IN UNITS OF PRODUCT, LESS PACKAGING, WHICH DO NOT WEIGH MORE THAN 1 POUND AND DO NOT CONSIST OF MORE THAN 16 FLUID OUNCES) SHALL COMPLY WITH STATEWIDE VOC STANDARDS AND OTHER REQUIREMENTS, INCLUDING PROHIBITIONS ON USE OF CERTAIN TOXIC COMPOUNDS, OF CALIFORNIA CODE OF REGULATIONS, TITLE 17, COMMENCING WITH SECTION 94507.

4.504.2.2 PAINTS AND COATINGS

APPLY.

ARCHITECTURAL PAINTS AND COATINGS SHALL COMPLY WITH VOC LIMITS IN TABLE 1 OF THE ARB ARCHITECTURAL SUGGESTED CONTROL MEASURE, AS SHOWN IN TABLE 4.504.3, UNLESS MORE STRINGENT LOCAL LIMITS APPLY. THE VOC CONTENT LIMIT FOR COATINGS THAT DO NOT MEET THE DEFINITIONS FOR THE SPECIALTY COATINGS CATEGORIES LISTED IN TABLE 4.504.3 SHALL BE DETERMINED BY CLASSIFYING THE COATING AS A FLAT. NONFLAT OR NONFLAT-HIGH GLOSS COATING, BASED ON ITS GLOSS, AS DEFINED IN SUBSECTIONS 4.21, 4.36, AND 4.37 OF THE 2007 CALIFORNIA AIR RESOURCES BOARD. SUGGESTED CONTROL MEASURE, AND THE CORRESPONDING FLAT, NONFLAT OR NONFLAT-HIGH GLOSS VOC LIMIT IN TABLE 4.504.3 SHALL

4.504.2.3 AEROSOL PAINTS AND COATINGS

AEROSOL PAINTS AND COATINGS SHALL MEET THE PRODUCT-WEIGHTED MIR LIMITS FOR ROC IN SECTION 94522(A)(2) AND OTHER REQUIREMENTS. INCLUDING PROHIBITIONS ON USE OF CERTAIN TOXIC COMPOUNDS AND OZONE DEPLETING SUBSTANCES, IN SECTIONS 94522(E)(1) AND (F)(1) OF CALIFORNIA CODE OF REGULATIONS, TITLE 17, COMMENCING WITH SECTION 94520; AND IN AREAS UNDER THE JURISDICTION OF THE BAY AREA AIR QUALITY MANAGEMENT DISTRICT ADDITIONALLY COMPLY WITH THE PERCENT VOC BY WEIGHT OF PRODUCT LIMITS OF REGULATION 8, RULE 49.

4.504.2.4 VERIFICATION

VERIFICATION OF COMPLIANCE WITH THIS SECTION SHALL BE PROVIDED AT THE REQUEST OF THE ENFORCING AGENCY. DOCUMENTATION MAY INCLUDE, BUT IS NOT LIMITED TO, THE FOLLOWING: MANUFACTURER'S PRODUCT SPECIFICATION.

2. FIELD VERIFICATION OF ON-SITE PRODUCT CONTAINERS.

4.504.3 CARPET SYSTEMS

4.504.3.1 CARPET CUSHION

ALL CARPET CUSHION INSTALLED IN THE BUILDING INTERIOR SHALL MEET THE REQUIREMENTS OF THE CALIFORNIA DEPARTMENT OF PUBLIC HEALTH. "STANDARD METHOD FOR THE TESTING AND EVALUATION OF VOLATILE ORGANIC CHEMICAL EMISSIONS FROM INDOOR SOURCES USING ENVIRONMENTAL CHAMBERS," VERSION 1.2, JANUARY 2017 (EMISSION TESTING METHOD FOR CALIFORNIA SPECIFICATION 01350).

SEE CALIFORNIA DEPARTMENT OF PUBLIC HEALTH'S WEBSITE FOR CERTIFICATION PROGRAMS AND TESTING LABS.

HTTPS://WWW.CDPH.CA.GOV/PROGRAMS/CCDPHP/DEODC/EHLB/IAQ/PAG ES/VOC.ASPX

4.504.3.2 CARPET ADHESIVE

ALL CARPET ADHESIVE SHALL MEET THE REQUIREMENTS OF TABLE

4.504.4 RESILIENT FLOORING SYSTEMS

WHERE RESILIENT FLOORING IS INSTALLED, AT LEAST 80 PERCENT OF FLOOR AREA RECEIVING RESILIENT FLOORING SHALL MEET THE REQUIREMENTS OF THE CALIFORNIA DEPARTMENT OF PUBLIC HEALTH "STANDARD METHOD FOR THE TESTING AND EVALUATION OF VOLATILE ORGANIC CHEMICAL EMISSIONS FROM INDOOR SOURCES USING ENVIRONMENTAL CHAMBERS," VERSION 1.2, JANUARY 2017 (EMISSION TESTING METHOD FOR CALIFORNIA SPECIFICATION 01350).

SEE CALIFORNIA DEPARTMENT OF PUBLIC HEALTH'S WEBSITE FOR CERTIFICATION PROGRAMS AND TESTING LABS.

HTTPS://WWW.CDPH.CA.GOV/PROGRAMS/CCDPHP/DEODC/EHLB/IAQ/PAG ES/VOC.ASPX

4.504.5 COMPOSITE WOOD PRODUCTS

HARDWOOD PLYWOOD, PARTICLEBOARD AND MEDIUM DENSITY FIBERBOARD COMPOSITE WOOD PRODUCTS USED ON THE INTERIOR OR EXTERIOR OF THE BUILDING SHALL MEET THE REQUIREMENTS FOR FORMALDEHYDE AS SPECIFIED IN ARB'S AIR TOXICS CONTROL MEASURE FOR COMPOSITE WOOD (17 CCR 93120 ET SEQ.) AS SHOWN IN TABLE 4.504.5.

4.504.5.1 DOCUMENTATION

VERIFICATION OF COMPLIANCE WITH THIS SECTION SHALL BE PROVIDED AS REQUESTED BY THE ENFORCING AGENCY, DOCUMENTATION SHALL INCLUDE AT LEAST ONE OF THE FOLLOWING:

- 1. PRODUCT CERTIFICATIONS AND SPECIFICATIONS. CHAIN OF CUSTODY CERTIFICATIONS.
- PRODUCT LABELED AND INVOICED AS MEETING THE COMPOSITE WOOD PRODUCTS REGULATION (SEE CCR, TITLE 17, SECTION
- 4. EXTERIOR GRADE PRODUCTS MARKED AS MEETING THE PS-1 OR PS-2 STANDARDS OF THE ENGINEERED WOOD ASSOCIATION, THE AUSTRALIAN AS/NZS 2269, EUROPEAN 636 3S, AND CANADIAN CSA 0121, CSA 0151, CSA 0153 AND CSA 0325
- 5. OTHER METHODS ACCEPTABLE TO THE ENFORCING AGENCY.

TABLE 4.504.1 - ADHESIVE VOC LIMIT	
(LESS WATER AND LESS EXEMPT COMPOUNDS IN GRAMS PER LITER)	
ARCHITECTURAL APPLICATIONS	CURRENT VOC LIMIT
INDOOR CARPET ADHESIVES	50
CARPET PAD ADHESIVES	50
OUTDOOR CARPET ADHESIVES	150
WOOD FLOORING ADHESIVES	100
RUBBER FLOORING ADHESIVES	60
SUBFLOOR ADHESIVES	50
CERAMIC TILE ADHESIVES	65
VCT AND ASPHALT TILE ADHESIVES	50
DRYWALL AND PANEL ADHESIVES	50
COVE BASE ADHESIVES	50
MULTIPURPOSE CONSTRUCTION ADHESIVES	70
STRUCTURAL GLAZING ADHESIVES	100
SINGLE-PLY ROOF MEMBRANE ADHESIVES	250
OTHER ADHESIVES NOT SPECIFICALLY LISTED	50
SPECIALTY APPLICATIONS	CURRENT VOC LIMIT
PVC WELDING	510
CPVC WELDING	490
ABD WELDING	325
PLASTIC CEMENT WELDING	250
ADHESIVE PRIMER FOR PLASTIC	550
CONTACT ADHESIVE	80
SPECIAL PURPOSE CONTACT ADHESIVE	250
STRUCTURAL WOOD MEMBER ADHESIVE	140
TOP AND TRIM ADHESIVES	250
SUBSTRATE SPECIFIC APPLICATIONS	CURRENT VOC LIMIT
METAL TO METAL	30
PLASTIC FOAMS	50
POROUS MATERIAL (EXCEPT WOOD)	50
WOOD	30
FIBERGLASS	80

- 1. IF AN ADHESIVE IS USED TO BOND DISSIMILAR SUBSTRATES TOGETHER, THE ADHESIVE WITH THE HIGHEST VOC CONTENT SHALL BE ALLOWED.
- 2. FOR ADDITIONAL INFORMATION REGARDING METHODS TO MEASURE THE VOC CONTENT SPECIFIED IN THIS TABLE, SEE SOUTH COAST AIR QUALITY MANAGEMENT DISTRICT RULE 1168.

TABLE 4.504.2 - SEALANT VOC LIMIT CONTINUED

SEALANTS	CURRENT VOC LIMIT
ARCHITECTURAL	250
MARINE DECK	760
NONMEMBRANE ROOF	300
ROADWAY	250
SINGLE-PLY ROOF MEMBRANE	450
OTHER	420
SEALANT PRIMERS	CURRENT VOC LIMIT
ARCHITECTURAL	
NONPOROUS	250
POROUS	250
MODIFIED BITUMINOUS	500
MARINE DECK	760
OTHER	750

TABLE 4.504.3 - VOC CONTENT LIMITS FOR ARCHITECTURAL COATINGS^{2, 3}

50 100
150
CURRENT VOC LIMIT
400
400
50
350
350
350
100
50
150
350
350
100
250
500
420
250
120
450
100
500
250
420
100
350
250
50
250
730
550
100
250
450
340
100
420
250
275
350
340

- 1. GRAMS OF VOC PER LITER OF COATING, INCLUDING WATER AND
- INCLUDING EXEMPT COMPOUNDS. 2. THE SPECIFIED LIMITS REMAIN IN EFFECT ENLESS REVISED LIMITS
- ARE LISTED IN SUBSEQUENT COLUMNS IN THE TABLE 3. VALUES IN THIS TABLE ARE DERIVED FROM THOSE SPECIFIED BY THE CALIFORNIA AIR RESOURCES BOARD, ARCHITECTURAL COATINGS SUGGESTED CONTROL MEASURE, FEBUARY 1, 2008. MORE INFORMATION IS AVAILABLE FROM THE AIR RESOURCES

TABLE 4.504.5 - FORMALDEHYDE LIMITS¹ (MAXIMUM FORMALDEHYDE EMISSIONS IN PARTS PER MILLION

PRODUCT	CURRENT LIMIT
HARDWOOD PLYWOOD VENEER CORE	0.05
HARDWOOD PLYWOOD COMPOSITE CORE	0.05
PARTICLEBOARD	0.09
MEDIUM DENSITY FIBERBOARD	0.11
THIN MEDIUM DENSITY FIBERBOARD ²	0.13

- 1. VALUES IN THIS TABLE ARE DERIVED FROM THOSE SPECIFIED BY THE CALIFORNIA AIR RESOURCES BOARD, AIR TOXICS CONTROL MEASURE FOR COMPOSITE WOOD AS TESTED IN ACCORDANCE WITH ASTM E1333. FOR ADDITIONAL INFORMATION, SEE CALIFORNIA CODE OF REGULATIONS, TITLE 17, SECTIONS 93120 THROUGH 93120.12.
- 2. THIN MEDIUM DENSITY FIBERBOARD HAS A MAXIMUM THICKNESS OF 5/16 INCH (8MM).

DIVISION 4.5 ENVIORNMENTAL QUALITY

4.505 INTERIOR MOISTURE CONTROL

BUILDINGS SHALL MEET OR EXCEED THE PROVISIONS OF THE CALIFORNIA BUILDING STANDARDS CODE.

4.505.2 CONCRETE SLAB FOUNDATIONS

CONCRETE SLAB FOUNDATIONS REQUIRED TO HAVE A VAPOR RETARDER BY THE CALIFORNIA BUILDING CODE CHAPTER 19 OR CONCRETE SLAB-ON-GROUND FLOORS REQUIRED TO HAVE A VAPOR RETARDER BY THE CALIFORNIA RESIDENTIAL CODE, CHAPTER 5, SHALL ALSO COMPLY WITH

4.505.2.1 CAPILLARY BREAK

A CAPILLARY BREAK SHALL BE INSTALLED IN COMPLIANCE WITH AT

- LEAST ONE OF THE FOLLOWING: . A 4-INCH-THICK (101.6 MM) BASE OF 1/2 INCH (12.7 MM) OR LARGER CLEAN AGGREGATE SHALL BE PROVIDED WITH A VAPOR RETARDER IN DIRECT CONTACT WITH CONCRETE AND A CONCRETE MIX DESIGN, WHICH WILL ADDRESS BLEEDING. SHRINKAGE, AND CURLING, SHALL BE USED. FOR ADDITIONAL INFORMATION, SEE AMERICAN CONCRETE INSTITUTE, ACI
 - . OTHER EQUIVALENT METHODS APPROVED BY THE ENFORCING
- 3. A SLAB DESIGN SPECIFIED BY A LICENSED DESIGN **PROFESSIONAL**

4.505.3 MOISTURE CONTENT OF A BUILDING

BUILDING MATERIALS WITH VISIBLE SIGNS OF WATER DAMAGE SHALL NOT BE INSTALLED. WALL AND FLOOR FRAMING SHALL NOT BE ENCLOSED WHEN THE FRAMING MEMBERS EXCEED 19-PERCENT MOISTURE CONTENT. MOISTURE CONTENT SHALL BE VERIFIED IN COMPLIANCE WITH THE FOLLOWING:

- MOISTURE CONTENT SHALL BE DETERMINED WITH EITHER A PROBE-TYPE OR CONTACT-TYPE MOISTURE METER. EQUIVALENT MOISTURE VERIFICATION METHODS MAY BE APPROVED BY THE ENFORCING AGENCY AND SHALL SATISFY REQUIREMENTS FOUND IN SECTION 101.8 OF THIS CODE.
- MOISTURE READINGS SHALL BE TAKEN AT A POINT 2 FEET (610 MM) TO 4 FEET (1219 MM) FROM THE GRADE STAMPED END OF EACH PIECE TO BE VERIFIED.
- AT LEAST THREE RANDOM MOISTURE READINGS SHALL BE PERFORMED ON WALL AND FLOOR FRAMING WITH DOCUMENTATION ACCEPTABLE TO THE ENFORCING AGENCY PROVIDED AT THE TIME OF APPROVAL TO ENCLOSE THE WALL AND FLOOR FRAMING.

INSULATION PRODUCTS WHICH ARE VISIBLY WET OR HAVE A HIGH MOISTURE CONTENT SHALL BE REPLACED OR ALLOWED TO DRY PRIOR TO ENCLOSURE IN WALL OR FLOOR CAVITIES. WET-APPLIED INSULATION PRODUCTS SHALL FOLLOW THE MANUFACTURERS' DRYING RECOMMENDATIONS PRIOR TO ENCLOSURE.

4.506 INDOOR AIR QUALITY AND EXHAUST

4.506.1 BATHROOM EXHAUST FANS

EACH BATHROOM SHALL BE MECHANICALLY VENTILATED AND SHALL COMPLY WITH THE FOLLOWING: 1. FANS SHALL BE ENERGY STAR COMPLIANT AND BE DUCTED TO

- TERMINATE OUTSIDE THE BUILDING. 2. UNLESS FUNCTIONING AS A COMPONENT OF A WHOLE HOUSE
- VENTILATION SYSTEM, FANS MUST BE CONTROLLED BY A HUMIDITY a. HUMIDITY CONTROLS SHALL BE CAPABLE OF ADJUSTMENT
- BETWEEN A RELATIVE HUMIDITY RANGE OF ≤ 50 PERCENT TO A MAXIMUM OF 80 PERCENT. A HUMIDITY CONTROL MAY UTILIZE MANUAL OR AUTOMATIC MEANS OF ADJUSTMENT. b. A HUMIDITY CONTROL MAY BE A SEPARATE COMPONENT TO THE EXHAUST FAN AND IS NOT REQUIRED TO BE INTEGRAL (I.E.,

1. FOR THE PURPOSES OF THIS SECTION, A BATHROOM IS A ROOM WHICH CONTAINS A BATHTUB, SHOWER, OR TUB/ SHOWER

2. LIGHTING INTEGRAL TO BATHROOM EXHAUST FANS SHALL COMPLY WITH THE CALIFORNIA ENERGY CODE.

4.507 ENVIROMENTAL COMFORT

BUILT-IN).

4.507.1 RESERVED

4.507.2 HEATING AND AIR-CONDITIONING SYSTEM DESIGN

- HEATING AND AIR-CONDITIONING SYSTEMS SHALL BE SIZED, DESIGNED AND HAVE THEIR EQUIPMENT SELECTED USING THE FOLLOWING METHODS: 1. THE HEAT LOSS AND HEAT GAIN IS ESTABLISHED ACCORDING TO ANSI/ACCA 2 MANUAL J—2016 (RESIDENTIAL LOAD CALCULATION), ASHRAE HANDBOOKS OR OTHER EQUIVALENT DESIGN SOFTWARE
- 2. DUCT SYSTEMS ARE SIZED ACCORDING TO ANSI/ACCA 1 MANUAL D-2016 (RESIDENTIAL DUCT SYSTEMS), ASHRAE HANDBOOKS OR OTHER EQUIVALENT DESIGN SOFTWARE OR METHODS.
- 3. SELECT HEATING AND COOLING EQUIPMENT ACCORDING TO ANSI/ACCA 3 MANUAL S—2016 (RESIDENTIAL EQUIPMENT SELECTION) OR OTHER EQUIVALENT DESIGN SOFTWARE OR

EXCEPTION: USE OF ALTERNATE DESIGN TEMPERATURES NECESSARY TO ENSURE THE SYSTEMS FUNCTION ARE ACCEPTABLE.

CHAPTER 7 - INSTALLER & SPECIAL INSPECTOR **QUALIFICATIONS 702 QUALIFICATIONS**

702.1 INSTALLER TRAINING

HVAC SYSTEM INSTALLERS SHALL BE TRAINED AND CERTIFIED IN THE PROPER INSTALLATION OF HVAC SYSTEMS INCLUDING DUCTS AND EQUIPMENT BY A NATIONALLY OR REGIONALLY RECOGNIZED TRAINING OR CERTIFICATION PROGRAM. UNCERTIFIED PERSONS MAY PERFORM HVAC INSTALLATIONS WHEN UNDER THE DIRECT SUPERVISION AND RESPONSIBILITY OF A PERSON TRAINED AND CERTIFIED TO INSTALL HVAC SYSTEMS OR CONTRACTOR LICENSED TO INSTALL HVAC SYSTEMS. EXAMPLES OF ACCEPTABLE HVAC TRAINING AND CERTIFICATION PROGRAMS INCLUDE BUT ARE NOT LIMITED TO THE FOLLOWING:

- STATE CERTIFIED APPRENTICESHIP PROGRAMS.
- PUBLIC UTILITY TRAINING PROGRAMS. TRAINING PROGRAMS SPONSORED BY TRADE, LABOR OR STATEWIDE ENERGY CONSULTING OR VERIFICATION ORGANIZATIONS.
- 4. PROGRAMS SPONSORED BY MANUFACTURING ORGANIZATIONS. 5. OTHER PROGRAMS ACCEPTABLE TO THE ENFORCING AGENCY.

702.2 SPECIAL INSPECTION [HCD]

WHEN REQUIRED BY THE ENFORCING AGENCY, THE OWNER OR THE RESPONSIBLE ENTITY ACTING AS THE OWNER'S AGENT SHALL EMPLOY ONE OR MORE SPECIAL INSPECTORS TO PROVIDE INSPECTION OR OTHER DUTIES NECESSARY TO SUBSTANTIATE COMPLIANCE WITH THIS CODE SPECIAL INSPECTORS SHALL DEMONSTRATE COMPETENCE TO THE SATISFACTION OF THE ENFORCING AGENCY FOR THE PARTICULAR TYPE OF INSPECTION OR TASK TO BE PERFORMED. IN ADDITION TO OTHER CERTIFICATIONS OR QUALIFICATIONS ACCEPTABLE TO THE ENFORCING AGENCY. THE FOLLOWING CERTIFICATIONS OR EDUCATION MAY BE CONSIDERED BY THE ENFORCING AGENCY WHEN EVALUATING THE QUALIFICATIONS OF A SPECIAL INSPECTOR:

- 1. CERTIFICATION BY A NATIONAL OR REGIONAL GREEN BUILDING
- PROGRAM OR STANDARD PUBLISHER. 2. CERTIFICATION BY A STATEWIDE ENERGY CONSULTING OR VERIFICATION ORGANIZATION, SUCH AS HERS RATERS, BUILDING PERFORMANCE CONTRACTORS, AND HOME ENERGY AUDITORS.
- 3. SUCCESSFUL COMPLETION OF A THIRD PARTY APPRENTICE TRAINING PROGRAM IN THE APPROPRIATE TRADE. 4. OTHER PROGRAMS ACCEPTABLE TO THE ENFORCING AGENCY.

- SPECIAL INSPECTORS SHALL BE INDEPENDENT ENTITIES WITH NO FINANCIAL INTEREST IN THE MATERIALS OR THE PROJECT THEY ARE INSPECTING FOR COMPLIANCE WITH THIS CODE.
- 2. HERS RATERS ARE SPECIAL INSPECTORS CERTIFIED BY THE CALIFORNIA ENERGY COMMISSION (CEC) TO RATE HOMES IN CALIFORNIA ACCORDING TO THE HOME ENERGY RATING SYSTEM

BSC] WHEN REQUIRED BY THE ENFORCING AGENCY, THE OWNER OR THE RESPONSIBLE ENTITY ACTING AS THE OWNER'S AGENT SHALL EMPLOY ONE OR MORE SPECIAL INSPECTORS TO PROVIDE INSPECTION OR OTHER DUTIES NECESSARY TO SUBSTANTIATE COMPLIANCE WITH THIS CODE. SPECIAL INSPECTORS SHALL DEMONSTRATE COMPETENCE TO THE SATISFACTION OF THE ENFORCING AGENCY FOR THE PARTICULAR TYPE OF INSPECTION OR TASK TO BE PERFORMED. IN ADDITION, THE SPECIAL INSPECTOR SHALL HAVE A CERTIFICATION FROM A RECOGNIZED STATE, NATIONAL OR INTERNATIONAL ASSOCIATION. AS DETERMINED BY THE LOCAL AGENCY. THE AREA OF CERTIFICATION SHALL BE CLOSELY RELATED TO THE PRIMARY JOB FUNCTION, AS DETERMINED BY THE LOCAL AGENCY.

SPECIAL INSPECTORS SHALL BE INDEPENDENT ENTITIES WITH NO FINANCIAL INTEREST IN THE MATERIALS OR THE PROJECT THEY ARE INSPECTING FOR COMPLIANCE WITH THIS CODE.

703 VERIFICATIONS

703.1 DOCUMENTATION.

DOCUMENTATION USED TO SHOW COMPLIANCE WITH THIS CODE SHALL INCLUDE BUT IS NOT LIMITED TO, CONSTRUCTION DOCUMENTS, PLANS, SPECIFICATIONS, BUILDER OR INSTALLER CERTIFICATION, INSPECTION REPORTS, OR OTHER METHODS ACCEPTABLE TO THE ENFORCING AGENCY WHICH DEMONSTRATE SUBSTANTIAL CONFORMANCE. WHEN SPECIFIC DOCUMENTATION OR SPECIAL INSPECTION IS NECESSARY TO VERIFY COMPLIANCE, THAT METHOD OF COMPLIANCE WILL BE SPECIFIED IN THE APPROPRIATE SECTION OR IDENTIFIED APPLICABLE CHECKLIST.

THESE PLANS ARE PROVIDED BY THE CITY OF CATHEDRAL CITY AS PART OF THE PRE-APPROVED ADU PROGRAM AND ARE PUBLIC DOMAIN. THERE CANNOT BE A CHARGE TO PROVIDE THESE PLANS. NO ALTERATIONS TO THESE PLANS ARE ALLOWED. ALL ALTERATIONS MUST BE DONE UNDER A SEPARATE PERMIT ONCE THE BUILDING PERMIT FOR THE ADU HAS BEEN ISSUED AND FINAL INSPECTION COMPLETED. IF YOU DO NOT HAVE THE CONSTRUCTION KNOWLEDGE AND EXPERIENCE TO CONTRUCT THESE PLANS WITHOUT FURTHER DETAILS, IT IS RECOMMENDED YOU HIRE A CONTRACTOR TO DO THE CONSTRUCTION. THE CITY WILL NOT PROVIDE FURTHER INFORMATION OR DETAILS AND BUILDING INSPECTORS WILL NOT PROVIDE STEP BY STEP INSTRUCTIONS IN THE FIELD.

H

08/08/24 SHEET

	2022 Single-Family Residential Mandatory Requirements Summary
§ 150.0(m)13;	Space Conditioning System Airflow Rate and Fan Efficacy. Space conditioning systems that use ducts to supply cooling must have a hole for the placement of a static pressure probe, or a permanently installed static pressure probe in the supply plenum. Airflow must be ≥ 350 CFM per ton of nominal cooling capacity, and an air-handling unit fan efficacy ≤ 0.45 watts per CFM for gas furnace air handlers and ≤ 0.58 watts per CFM for all others. Small duct high velocity systems must provide an airflow ≥ 250 CFM per ton of nominal cooling capacity, and an air-handling unit fan efficacy ≤ 0.62 watts per CFM. Field verification testing is required in accordance with Reference Residential Appendix RA3.3.*
fautilatian and li	All Ovalies
§ 150.0(o)1:	Requirements for Ventilation and Indoor Air Quality. All dwelling units must meet the requirements of ASHRAE Standard 62.2, Ventilation and Acceptable Indoor Air Quality in Residential Buildings subject to the amendments specified in § 150.0(o)1.
§ 150.0(o)1B:	Central Fan Integrated (CFI) Ventilation Systems. Continuous operation of CFI air handlers is not allowed to provide the whole-dwelling unit ventilation airflow required per §150.0(o)1C. A motorized damper(s) must be installed on the ventilation duct(s) that prevents all airflow through the space conditioning duct system when the damper(s) is closed and controlled per §150.0(o)1Biil&iv. CFI ventilation systems must have controls that track outdoor air ventilation run time, and either open or close the motorized damper(s) for compliance with §150.0(o)1C. Whole-Dwelling Unit Mechanical Ventilation for Single-Family Detached and townhouses. Single-family detached dwelling units,
§ 150.0(o)1C:	and attached dwelling units not sharing ceilings or floors with other dwelling units, occupiable spaces, public garages, or commercial spaces must have mechanical ventilation airflow specified in § 150.0(o)1Ci-lii.
§ 150.0(o)1G:	Local Mechanical Exhaust. Kitchens and bathrooms must have local mechanical exhaust; nonenclosed kitchens must have demand-controlled exhaust system meeting requirements of §150.0(o)1Giii,enclosed kitchens and bathrooms can use demand-controlled or continuous exhaust meeting §150.0(o)1Giii-iv. Airflow must be measured by the installer per §150.0(o)1Gv, and rated for sound per §150.0(o)1Gvi. *
§ 150.0(o)1H&I:	Airflow Measurement and Sound Ratings of Whole-Dwelling Unit Ventilation Systems. The airflow required per § 150.0(o)1C must be measured by using a flow hood, flow grid, or other airflow measuring device at the fan's inlet or outlet terminals/grilles per Reference Residential Appendix RA3.7. Whole-Dwelling unit ventilation systems must be rated for sound per ASHRAE 62.2 §7.2 at no less than the minimum airflow rate required by §150.0(o)1C.
§ 150.0(o)2:	Field Verification and Diagnostic Testing. Whole-Dwelling Unit ventilation airflow, vented range hood airflow and sound rating, and HRV and ERV fan efficacy must be verified in accordance with Reference Residential Appendix RA3.7. Vented range hoods must be verified per Reference Residential Appendix RA3.7.4.3 to confirm if it is rated by HVI or AHAM to comply with the airflow rates and sound requirements per §150.0(o)1G
ool and Spa Sys	stems and Equipment:
§ 110.4(a):	Certification by Manufacturers. Any pool or spa heating system or equipment must be certified to have all of the following: compliance with the Appliance Efficiency Regulations and listing in MAEDbS; an on-off switch mounted outside of the heater that allows shutting off the heater without adjusting the thermostat setting; a permanent weatherproof plate or card with operating instructions; and must not use electric resistance heating. *
§ 110.4(b)1:	Piping. Any pool or spa heating system or equipment must be installed with at least 36 inches of pipe between the filter and the heater, or dedicated suction and return lines, or built-in or built-up connections to allow for future solar heating.
§ 110.4(b)2:	Covers. Outdoor pools or spas that have a heat pump or gas heater must have a cover.
§ 110.4(b)3:	Directional Inlets and Time Switches for Pools. Pools must have directional inlets that adequately mix the pool water, and a time switch that will allow all pumps to be set or programmed to run only during off-peak electric demand periods.
§ 110.5:	Pilot Light. Natural gas pool and spa heaters must not have a continuously burning pilot light.
§ 150.0(p):	Pool Systems and Equipment Installation. Residential pool systems or equipment must meet the specified requirements for pump sizing, flow rate, piping, filters, and valves. *
ighting:	
. 1124	Lighting Controls and Components. All lighting control devices and systems, ballasts, and luminaires must meet the applicable
§ 110.9:	requirements of § 110.9. *
§ 150.0(k)1A:	Luminaire Efficacy. All installed luminaires must meet the requirements in Table 150.0-A, except lighting integral to exhaust fans, kitchen range hoods, bath vanity mirrors, and garage door openers; navigation lighting less than 5 watts; and lighting internal to drawers, cabinets, and line closets with an efficacy of at least 45 lumens per watt.
150.0(k)1B:	Screw based luminaires. Screw based luminaires must contain lamps that comply with Reference Joint Appendix JA8.
§ 150.0(k)1C:	Recessed Downlight Luminaires in Ceilings. Luminaires recessed into ceilings must not contain screw based sockets, must be airtight, and must be sealed with a gasket or caulk. California Electrical Code § 410.116 must also be met.
§ 150.0(k)1D:	Light Sources in Enclosed or Recessed Luminaires. Lamps and other separable light sources that are not compliant with the JA8 elevated temperature requirements, including marking requirements, must not be installed in enclosed or recessed luminaires.
§ 150.0(k)1E:	Blank Electrical Boxes. The number of electrical boxes that are more than five feet above the finished floor and do not contain a luminaire or other device shall be no more than the number of bedrooms. These boxes must be served by a dimmer, vacancy sensor control. low voltage wiring, or fan speed control.

Lighting Integral to Exhaust Fans. Lighting integral to exhaust fans (except when installed by the manufacturer in kitchen exhaust

2022 Single-Family Residential Mandatory Requirements Summary

Pilot Lights. Continuously burning pilot lights are prohibited for natural gas: fan-type central furnaces; household cooking appliances

(except appliances without an electrical supply voltage connection with pilot lights that consume less than 150 Btu per hour); and pool and Building Cooling and Heating Loads. Heating and/or cooling loads are calculated in accordance with the ASHRAE Handbook. Equipment Volume, Applications Volume, and Fundamentals Volume; the SMACNA Residential Comfort System Installation § 150.0(h)1:

Standards Manual; or the ACCA Manual J using design conditions specified in § 150.0(h)2. Clearances. Air conditioner and heat pump outdoor condensing units must have a clearance of at least five feet from the outlet of any § 150.0(h)3A: Liquid Line Drier. Air conditioners and heat pump systems must be equipped with liquid line filter driers if required, as specified by the

Water Piping, Solar Water-heating System Piping, and Space Conditioning System Line Insulation. All domestic hot water piping must be insulated as specified in § 609.11 of the California Plumbing Code. Insulation Protection. Piping insulation must be protected from damage, including that due to sunlight, moisture, equipment

maintenance, and wind as required by §120.3(b). Insulation exposed to weather must be water retardant and protected from UV light (no adhesive tapes). Insulation covering chilled water piping and refrigerant suction piping located outside the conditioned space must include, or be protected by, a Class I or Class II vapor retarder. Pipe insulation buried below grade must be installed in a waterproof and Gas or Propane Water Heating Systems. Systems using gas or propane water heaters to serve individual dwelling units must designate a space at least 2.5' x 2.5' x 7' suitable for the future installation of a heat pump water heater, and meet electrical and

more than 2" higher than the base of the water heater Solar Water-heating Systems. Solar water-heating systems and collectors must be certified and rated by the Solar Rating and Certification Corporation (SRCC), the International Association of Plumbing and Mechanical Officials, Research and Testing (IAPMO R&T), or by a listing agency that is approved by the executive director.

plumbing requirements, based on the distance between this designated space and the water heater location; and a condensate drain no

Ducts. Insulation installed on an existing space-conditioning duct must comply with § 604.0 of the California Mechanical Code (CMC). If a § 110.8(d)3: contractor installs the insulation, the contractor must certify to the customer, in writing, that the insulation meets this requirement. CMC Compliance. All air-distribution system ducts and plenums must meet CMC §§ 601.0-605.0 and ANSI/SMACNA-006-2006 HVAC Duct Construction Standards Metal and Flexible 3rd Edition. Portions of supply-air and return-air ducts and plenums must be insulated to R-6.0 or higher; ducts located entirely in conditioned space as confirmed through field verification and diagnostic testing (RA3.1.4.3.8) do not require insulation. Connections of metal ducts and inner core of flexible ducts must be mechanically fastened. Openings must be sealed with mastic, tape, or other duct-closure system that meets the applicable UL requirements, or aerosol sealant that meets UL 723. The combination of mastic and either mesh or tape must be used to seal openings greater than 1/4", If mastic or tape is used. Building cavities, air handler support platforms, and plenums designed or constructed with materials other than sealed sheet metal, duct board or

these spaces must not be compressed Factory-Fabricated Duct Systems. Factory-fabricated duct systems must comply with applicable requirements for duct construction, connections, and closures; joints and seams of duct systems and their components must not be sealed with cloth back rubber adhesive duct tapes unless such tape is used in combination with mastic and draw bands.

flexible duct must not be used to convey conditioned air. Building cavities and support platforms may contain ducts; ducts installed in

Field-Fabricated Duct Systems. Field-fabricated duct systems must comply with applicable requirements for: pressure-sensitive tapes, mastics, sealants, and other requirements specified for duct construction. Backdraft Damper. Fan systems that exchange air between the conditioned space and outdoors must have backdraft or automatic

§ 150.0(m)7; Gravity Ventilation Dampers. Gravity ventilating systems serving conditioned space must have either automatic or readily accessible, manually operated dampers in all openings to the outside, except combustion inlet and outlet air openings and elevator shaft vents. Protection of Insulation. Insulation must be protected from damage due tosunlight, moisture, equipment maintenance, and wind. Insulation exposed to weather must be suitable for outdoor service (e.g., protected by aluminum, sheet metal, painted canvas, or plastic § 150.0(m)9;

cover). Cellular foam insulation must be protected as above or painted with a water retardant and solar radiation-resistant coating. § 150.0(m)10: Porous Inner Core Flex Duct. Porous inner cores of flex ducts must have a non-porous layer or air barrier between the inner core and Duct System Sealing and Leakage Test. When space conditioning systems use forced air duct systems to supply conditioned air to an occupiable space, the ducts must be sealed and duct leakage tested, as confirmed through field verification and diagnostic testing, in

accordance with Reference Residential Appendix RA3.1. Air Filtration. Space conditioning systems with ducts exceeding 10 feet and the supply side of ventilation systems must have MERV 13 or equivalent filters. Filters for space conditioning systems must have a two inch depth or can be one inch if sized per Equation 150.0-A. Clean-filter pressure drop and labeling must meet the requirements in §150.0(m)12. Filters must be accessible for regular service. Filter racks or grilles must use gaskets, sealing, or other means to close gaps around the inserted filters to and prevents air from bypassing the

§ 150.0(k)11:

2022 Single-Family Residential Mandatory Requirements Summary

NOTE: Single-family residential buildings subject to the Energy Codes must comply with all applicable mandatory measures, regardless of the compliance approach

(04/2022)	te respective section for more information.
Building Envelo	ope:
§ 110.6(a)1:	Air Leakage. Manufactured fenestration, exterior doors, and exterior pet doors must limit air leakage to 0.3 CFM per square foot or less when tested per NFRC-400, ASTM E283, or AAMA/WDMA/CSA 101/I.S.2/A440-2011. *
§ 110.6(a)5:	Labeling. Fenestration products and exterior doors must have a label meeting the requirements of § 10-111(a).
§ 110.6(b):	Field fabricated exterior doors and fenestration products must use U-factors and solar heat gain coefficient (SHGC) values from Tables 110.6-A, 110.6-B, or JA4.5 for exterior doors. They must be caulked and/or weather-stripped.*
§ 110.7:	Air Leakage. All joints, penetrations, and other openings in the building envelope that are potential sources of air leakage must be caulked, gasketed, or weather stripped.
§ 110.8(a):	Insulation Certification by Manufacturers. Insulation must be certified by the Department of Consumer Affairs, Bureau of Household Goods and Services (BHGS).
§ 110.8(g):	Insulation Requirements for Heated Slab Floors. Heated slab floors must be insulated per the requirements of § 110.8(g).
§ 110.8(i):	Roofing Products Solar Reflectance and Thermal Emittance. The thermal emittance and aged solar reflectance values of the roofing material must meet the requirements of § 110.8(i) and be labeled per §10-113 when the installation of a cool roof is specified on the CF1R.
§ 110.8(j):	Radiant Barrier. When required, radiant barriers must have an emittance of 0.05 or less and be certified to the Department of Consumer Affairs.
§ 150.0(a):	Roof Deck, Ceiling and Rafter Roof Insulation. Roof decks in newly constructed attics in climate zones 4 and 8-16 area-weighted average U-factor not exceeding U-0.184. Ceiling and rafter roofs minimum R-22 insulation in wood-frame ceiling; or area-weighted average U-factor must not exceed 0.043. Rafter roof alterations minimum R-19 or area-weighted average U-factor of 0.054 or less. Attic access doors must have permanently attached insulation using adhesive or mechanical fasteners. The attic access must be gasketed to prevent air leakage. Insulation must be installed in direct contact with a roof or ceiling which is sealed to limit infiltration and exfiltration as specified in § 110.7, including but not limited to placing insulation either above or below the roof deck or on top of a drywall ceiling.*
& 150 0(b):	Loose-fill Insulation, Loose fill insulation must meet the manufacturer's required density for the labeled R-value.

Loose-fill Insulation. Loose fill insulation must meet the manufacturer's required density for the labeled R-value Wall Insulation. Minimum R-13 insulation in 2x4 inch wood framing wall or have a U-factor of 0.102 or less, or R-20 in 2x6 inch wood framing or have a U-factor of 0.071 or less. Opaque non-framed assemblies must have an overall assembly U-factor not exceeding 0.102 Masonry walls must meet Tables 150.1-A or B. Raised-floor Insulation. Minimum R-19 insulation in raised wood framed floor or 0.037 maximum U-factor. Slab Edge Insulation. Slab edge insulation must meet all of the following: have a water absorption rate, for the insulation material alone

without facings, no greater than 0.3 percent; have a water vapor permeance no greater than 2.0 perm per inch; be protected from

physical damage and UV light deterioration, and, when installed as part of a heated slab floor, meet the requirements of § 110.8(g).

Vapor Retarder. In climate zones 1 through 16, the earth floor of unvented crawl space must be covered with a Class I or Class II

§ 150.0(g)1: vapor retarder. This requirement also applies to controlled ventilation crawl space for buildings complying with the exception to Vapor Retarder. In climate zones 14 and 16, a Class I or Class II vapor retarder must be installed on the conditioned space side of all insulation in all exterior walls, vented attics, and unvented attics with air-permeable insulation. Fenestration Products. Fenestration, including skylights, separating conditioned space from unconditioned space or outdoors must have

a maximum U-factor of 0.45; or area-weighted average U-factor of all fenestration must not exceed 0.45. Fireplaces, Decorative Gas Appliances, and Gas Log: Pilot Light. Continuously burning pilot lights are not allowed for indoor and outdoor fireplaces. Closable Doors. Masonry or factory-built fireplaces must have a closable metal or glass door covering the entire opening of the firebox. Combustion Intake. Masonry or factory-built fireplaces must have a combustion outside air intake, which is at least six square inches in § 150.0(e)2: area and is equipped with a readily accessible, operable, and tight-fitting damper or combustion-air control device. § 150.0(e)3: Flue Damper. Masonry or factory-built fireplaces must have a flue damper with a readily accessible control. *

Space Conditioning, Water Heating, and Plumbing System: Certification. Heating, ventilation, and air conditioning (HVAC) equipment, water heaters, showerheads, faucets, and all other regulated appliances must be certified by the manufacturer to the California Energy Commission. § 110.2(a): HVAC Efficiency. Equipment must meet the applicable efficiency requirements in Table 110.2-A through Table 110.2-N.* Controls for Heat Pumps with Supplementary Electric Resistance Heaters. Heat pumps with supplementary electric resistance heaters must have controls that prevent supplementary heater operation when the heating load can be met by the heat pump alone; and in which the cut-on temperature for compression heating is higher than the cut-on temperature for supplementary heating, and the cut-off temperature for compression heating is higher than the cut-off temperature for supplementary heating. Thermostats. All heating or cooling systems not controlled by a central energy management control system (EMCS) must have a § 110.2(c): setback thermostat. Insulation. Unfired service water heater storage tanks and solar water-heating backup tanks must have adequate insulation, or tank

surface heat loss rating. Isolation Valves. Instantaneous water heaters with an input rating greater than 6.8 kBtu per hour (2 kW) must have isolation valves with

hose bibbs or other fittings on both cold and hot water lines to allow for flushing the water heater when the valves are closed.

02

2022 Single-Family Residential Mandatory Requirements Summary § 150.0(k)1G: Screw based luminaires. Screw based luminaires must contain lamps that comply with Reference Joint Appendix JA8. Light Sources in Enclosed or Recessed Luminaires. Lamps and other separable light sources that are not compliant with the JA8 § 150.0(k)1H: elevated temperature requirements, including marking requirements, must not be installed in enclosed or recessed luminaires.

Light Sources in Drawers, Cabinets, and Linen Closets. Light sources internal to drawers, cabinetry or linen closets are not required to comply with Table 150.0-A or be controlled by vacancy sensors provided that they are rated to consume no more than 5 watts of power, emit no more than 150 lumens, and are equipped with controls that automatically turn the lighting off when the drawer, cabinet or

Interior Switches and Controls, All forward phase cut dimmers used with LED light sources must comply with NEMA SSL 7A. § 150.0(k)2A: Interior Switches and Controls. Exhaust fans must be controlled separately from lighting systems. Accessible Controls. Lighting must have readily accessible wall-mounted controls that allow the lighting to be manually turned

§ 150.0(k)2A: Multiple Controls. Controls must not bypass a dimmer, occupant sensor, or vacancy sensor function if the dimmer or sensor is installed to comply with § 150.0(k). Mandatory Requirements. Lighting controls must comply with the applicable requirements of § 110.9. Energy Management Control Systems. An energy management control system (EMCS) may be used to comply with dimming,

§ 150.0(k)2D: occupancy, and control requirements if it provides the functionality of the specified control per § 110.9 and the physical controls specified Automatic Shutoff Controls. In bathrooms, garages, laundry rooms, utility rooms and walk-in closets, at least one installed luminaire § 150.0(k)2E: must be controlled by an occupancy or vacancy sensor providing automatic-off functionality. Lighting inside drawers and cabinets with opaque fronts or doors must have controls that turn the light off when the drawer or door is closed.

Dimmers. Lighting in habitable spaces (e.g., living rooms, dining rooms, kitchens, and bedrooms) must have readily accessible wallmounted dimming controls that allow the lighting to be manually adjusted up and down. Forward phase cut dimmers controlling LED light sources in these spaces must comply with NEMA SSL 7A. § 150.0(k)2K: Independent controls. Integrated lighting of exhaust fans shall be controlled independently from the fans. Lighting under cabinets or shelves, lighting in display cabinets, and switched outlets must be controlled separately from ceiling-installed lighting. Residential Outdoor Lighting. For single-family residential buildings, outdoor lighting permanently mounted to a residential building, or t

control) or an astronomical time clock. An energy management control system that provides the specified control functionality and meets all

applicable requirements may be used to meet these requirements. Internally illuminated address signs. Internally illuminated address signs must either comply with § 140.8 or consume no more than 5 Residential Garages for Eight or More Vehicles. Lighting for residential parking garages for eight or more vehicles must comply with the applicable requirements for nonresidential garages in §§ 110.9, 130.0, 130.1, 130.4, 140.6, and 141.0.

§ 150.0(k)3A: other buildings on the same lot, must have a manual on/off switch and either a photocell and motion sensor or automatic time switch

Single-family Residences. Single-family residences located in subdivisions with 10 or more single-family residences and where the § 110.10(a)1; application for a tentative subdivision map for the residences has been deemed complete and approved by the enforcement agency, which do not have a photovoltaic system installed, must comply with the requirements of § 110.10(b)-(e). Minimum Solar Zone Area. The solar zone must have a minimum total area as described below. The solar zone must comply with access, pathway, smoke ventilation, and spacing requirements as specified in Title 24, Part 9 or other parts of Title 24 or in any requirements adopted by a local jurisdiction. The solar zone total area must be comprised of areas that have no dimension less than 5

feet and are no less than 80 square feet each for buildings with roof areas less than or equal to 10,000 square feet or no less than 160 §110.10(b)1A: square feet each for buildings with roof areas greater than 10,000 square feet. For single-family residences, the solar zone must be located on the roof or overhang of the building and have a total area no less than 250 square feet. * § 110.10(b)2: Azimuth. All sections of the solar zone located on steep-sloped roofs must have an azimuth between 90-300° of true north.

Shading. The solar zone must not contain any obstructions, including but not limited to: vents, chimneys, architectural features, and roof § 110.10(b)3A: mounted equipment.* Shading. Any obstruction located on the roof or any other part of the building that projects above a solar zone must be located at least twice the § 110.10(b)3B: horizontal distance of the height difference between the highest point of the obstruction and the horizontal projection of the nearest point of the solar zone, measured in the vertical plane.

Structural Design Loads on Construction Documents. For areas of the roof designated as a solar zone, the structural design loads for roof dead load and roof live load must be clearly indicated on the construction documents. Interconnection Pathways. The construction documents must indicate; a location reserved for inverters and metering equipment and a pathway reserved for routing of conduit from the solar zone to the point of interconnection with the electrical service; and for single-family

residences and central water-heating systems, a pathway reserved for routing plumbing from the solar zone to the water-heating system. Documentation. A copy of the construction documents or a comparable document indicating the information from § 110.10(b)-(c) must be § 110.10(d): provided to the occupant. Main Electrical Service Panel. The main electrical service panel must have a minimum busbar rating of 200 amps.

Main Electrical Service Panel. The main electrical service panel must have a reserved space to allow for the installation of a double pole circuit breaker for a future solar electric installation. The reserved space must be permanently marked as "For Future Solar Electric." Electric and Energy Storage Ready:



THESE PLANS ARE PROVIDED BY THE CITY OF CATHEDRAL CITY AS PART OF THE PRE-APPROVED ADU PROGRAM AND ARE PUBLIC DOMAIN. THERE CANNOT BE A CHARGE TO PROVIDE THESE PLANS. NO ALTERATIONS TO THESE PLANS ARE ALLOWED. ALL ALTERATIONS MUST BE DONE UNDER A SEPARATE PERMIT ONCE THE BUILDING PERMIT FOR THE ADU HAS BEEN ISSUED AND FINAL INSPECTION COMPLETED. IF YOU DO NOT HAVE THE CONSTRUCTION KNOWLEDGE AND EXPERIENCE TO CONTRUCT THESE PLANS WITHOUT FURTHER DETAILS, IT IS RECOMMENDED YOU HIRE A CONTRACTOR TO DO THE CONSTRUCTION. THE CITY WILL NOT PROVIDE FURTHER INFORMATION OR DETAILS AND BUILDING INSPECTORS WILL NOT PROVIDE STEP BY STEP INSTRUCTIONS IN THE FIELD.

ATHEDR,

08/08/24

SHEET

control, low voltage wiring, or fan speed control.

hoods) must meet the applicable requirements of § 150.0(k)

§ 150.0(k)1F:

equipment with backed up capacity of 60 amps or more and four or more ESS supplied branch circuits, or a dedicated raceway from the main service to a subpanel that supplies the branch circuits in § 150.0(s); at least four branch circuits must be identified and have their source collocated at a single panelboard suitable to be supplied by the ESS, with one circuit supplying the refrigerator, one lighting circuit near the primary exit, and one circuit supplying a sleeping room receptacle outlet; main panelboard must have a minimum busbar rating of 225 amps; sufficient space must be reserved to allow future installation of a system isolation equipment/transfer switch within 3' of the main panelboard, with raceways installed between the panelboard and the switch location to allow the connection of backup power source. Heat Pump Space Heater Ready. Systems using gas or propane furnaces to serve individual dwelling units must include: A dedicated unobstructed 240V branch circuit wiring installed within 3' of the furnace with circuit conductors rated at least 30 amps with the blank cover identified as "240V ready;" and a reserved main electrical service panel space to allow for the installation of a double pole circuit breaker permanently marked as "For Future 240V use."


2022 Single-Family Residential Mandatory Requirements Summary

Energy Storage System (ESS) Ready. All single-family residences must meet all of the following: Either ESS-ready interconnection

Electric Cooktop Ready. Systems using gas or propane cooktop to serve individual dwelling units must include: A dedicated unobstructed 240V branch circuit wiring installed within 3' of the cooktop with circuit conductors rated at least 50 amps with the blank cover identified as "240V ready;" and a reserved main electrical service panel space to allow for the installation of a double pole circuit breaker permanently marked as "For Future 240V use."

Electric Clothes Dryer Ready. Clothes dryer locations with gas or propane plumbing to serve individual dwelling units must include: A dedicated unobstructed 240V branch circuit wiring installed within 3' of the dryer location with circuit conductors rated at least 30 amps with the blank cover identified as "240V ready;" and a reserved main electrical service panel space to allow for the installation of a double pole circuit breaker permanently marked as "For Future 240V use."

*Exceptions may apply.

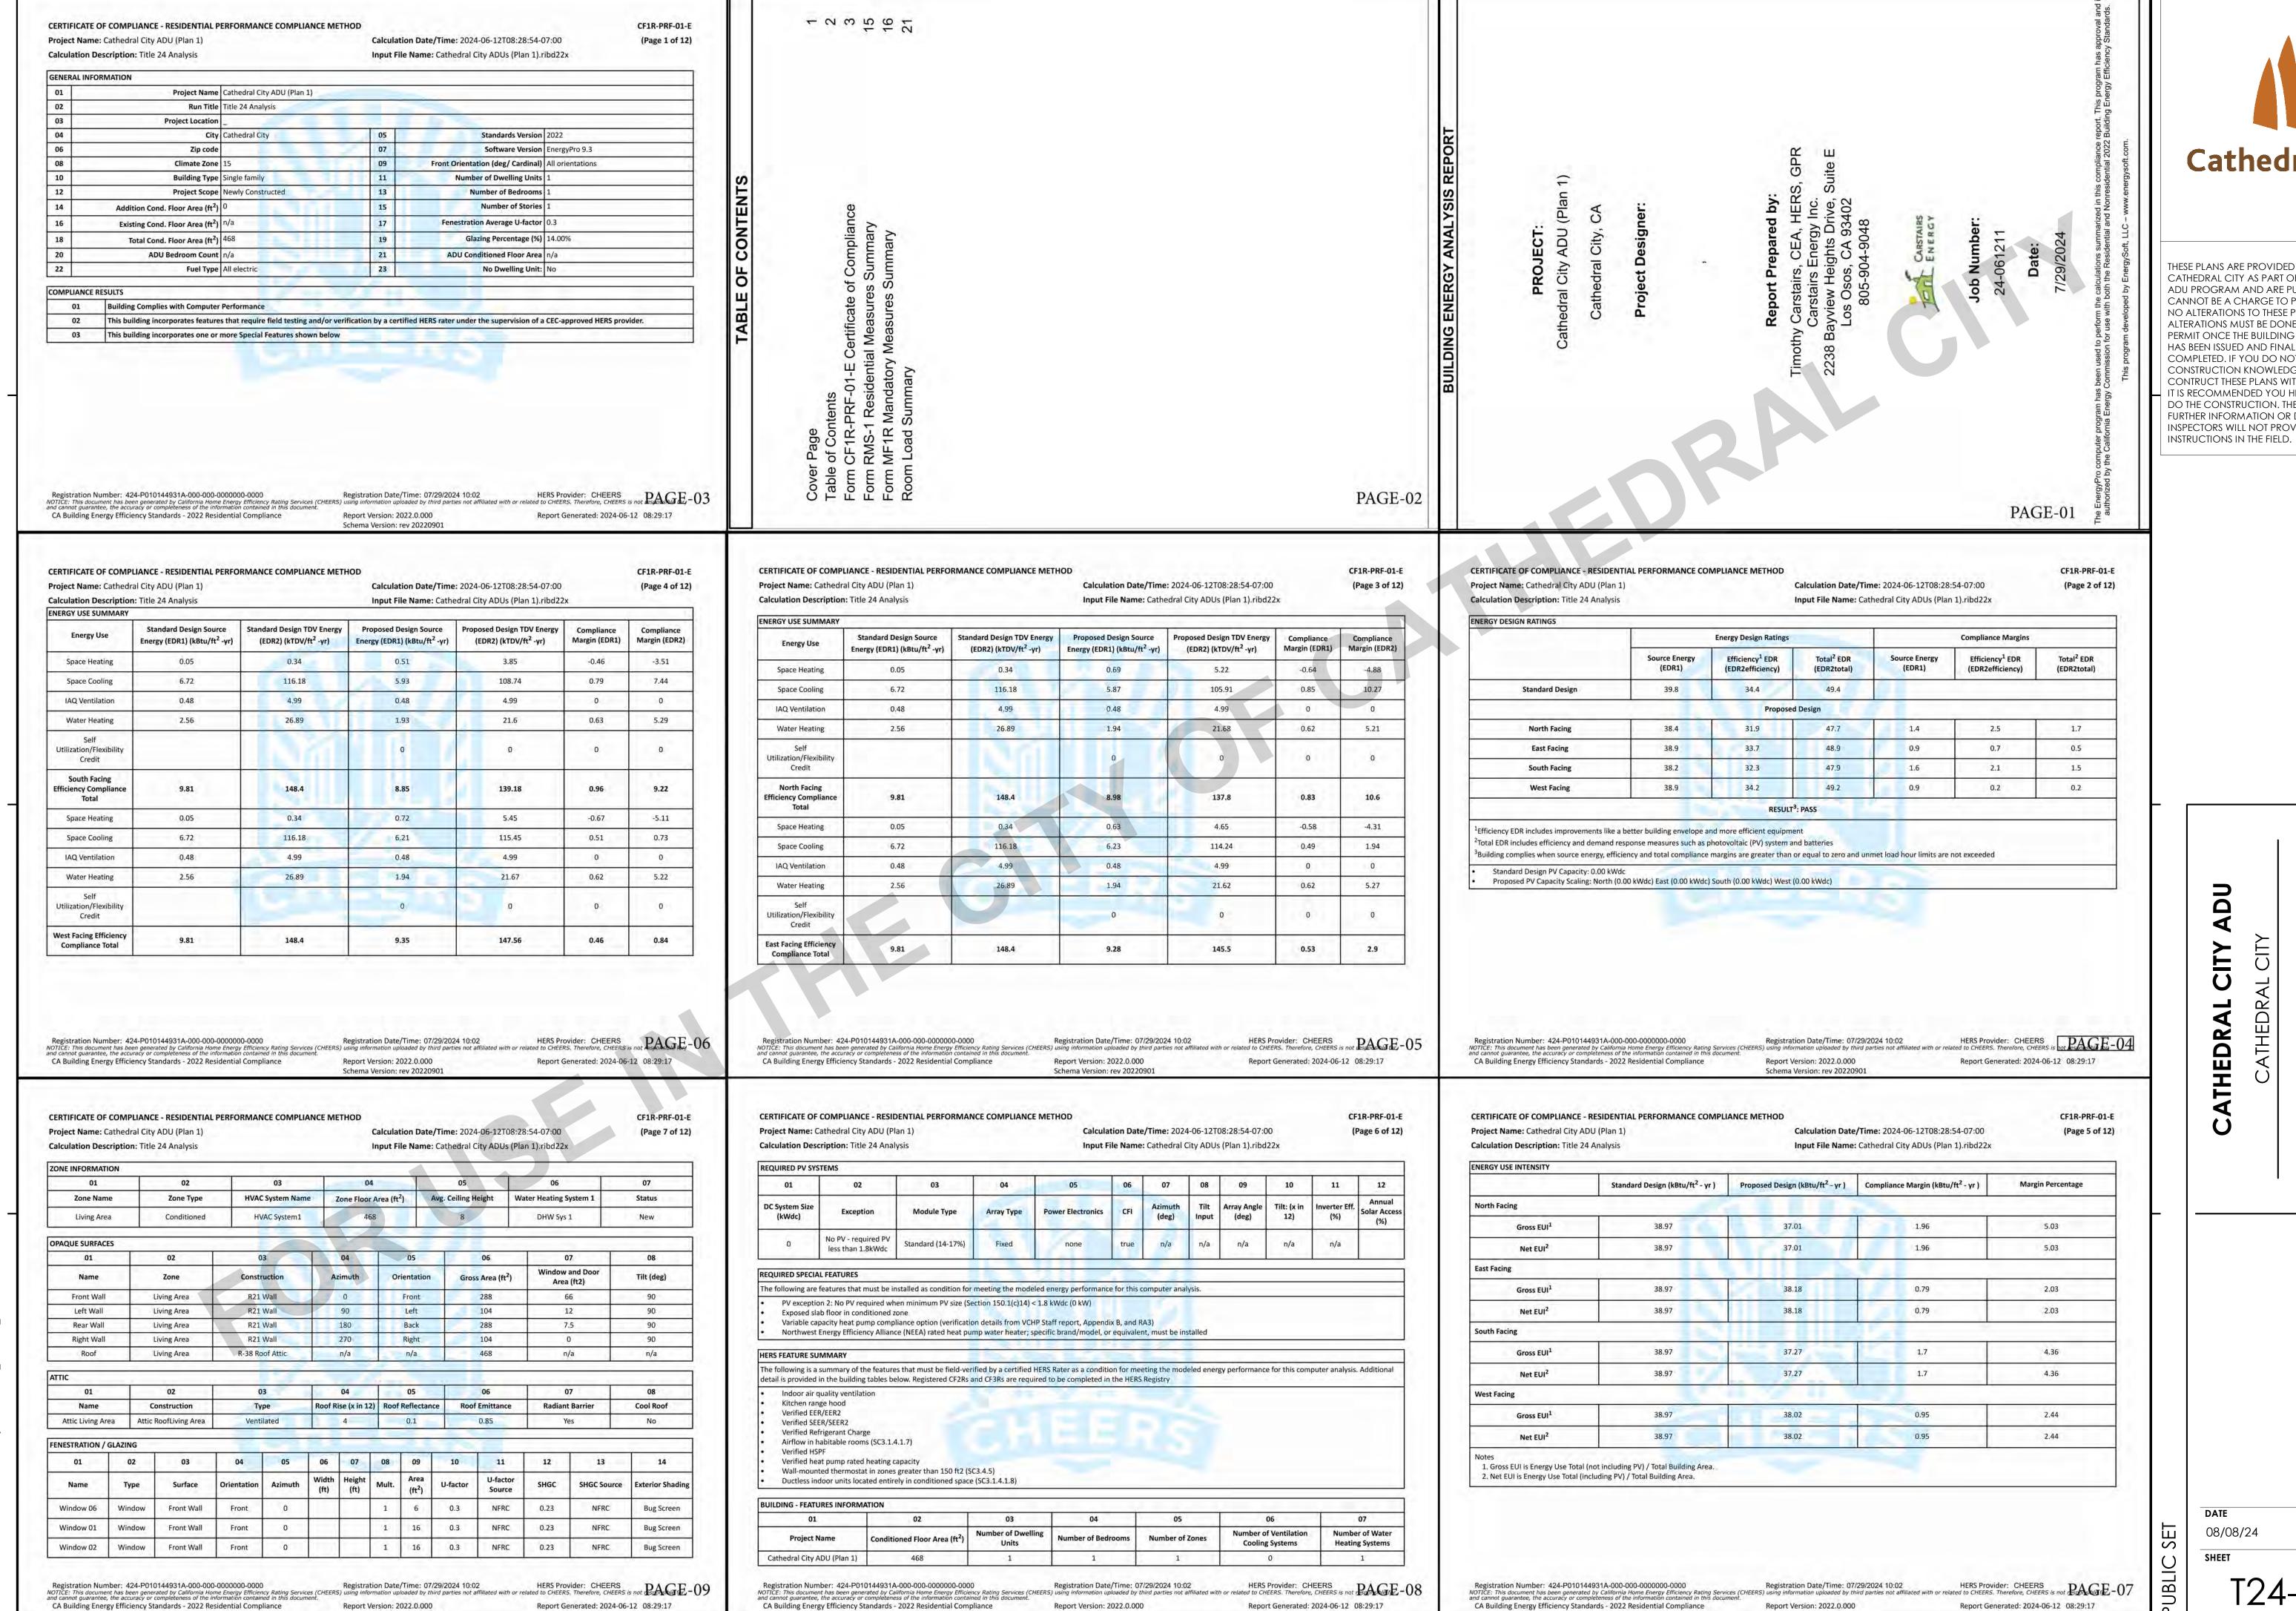


Schema Version: rev 20220901

Schema Version: rev 20220901

Cathedral City

HESE PLANS ARE PROVIDED BY THE CITY OF CATHEDRAL CITY AS PART OF THE PRE-APPROVED ADU PROGRAM AND ARE PUBLIC DOMAIN. THERE CANNOT BE A CHARGE TO PROVIDE THESE PLANS. NO ALTERATIONS TO THESE PLANS ARE ALLOWED. ALI ALTERATIONS MUST BE DONE UNDER A SEPARATE PERMIT ONCE THE BUILDING PERMIT FOR THE ADU HAS BEEN ISSUED AND FINAL INSPECTION COMPLETED. IF YOU DO NOT HAVE THE CONSTRUCTION KNOWLEDGE AND EXPERIENCE TO CONTRUCT THESE PLANS WITHOUT FURTHER DETAILS, IT IS RECOMMENDED YOU HIRE A CONTRACTOR TO DO THE CONSTRUCTION. THE CITY WILL NOT PROVIDE FURTHER INFORMATION OR DETAILS AND BUILDING INSPECTORS WILL NOT PROVIDE STEP BY STEP

Schema Version: rev 20220901

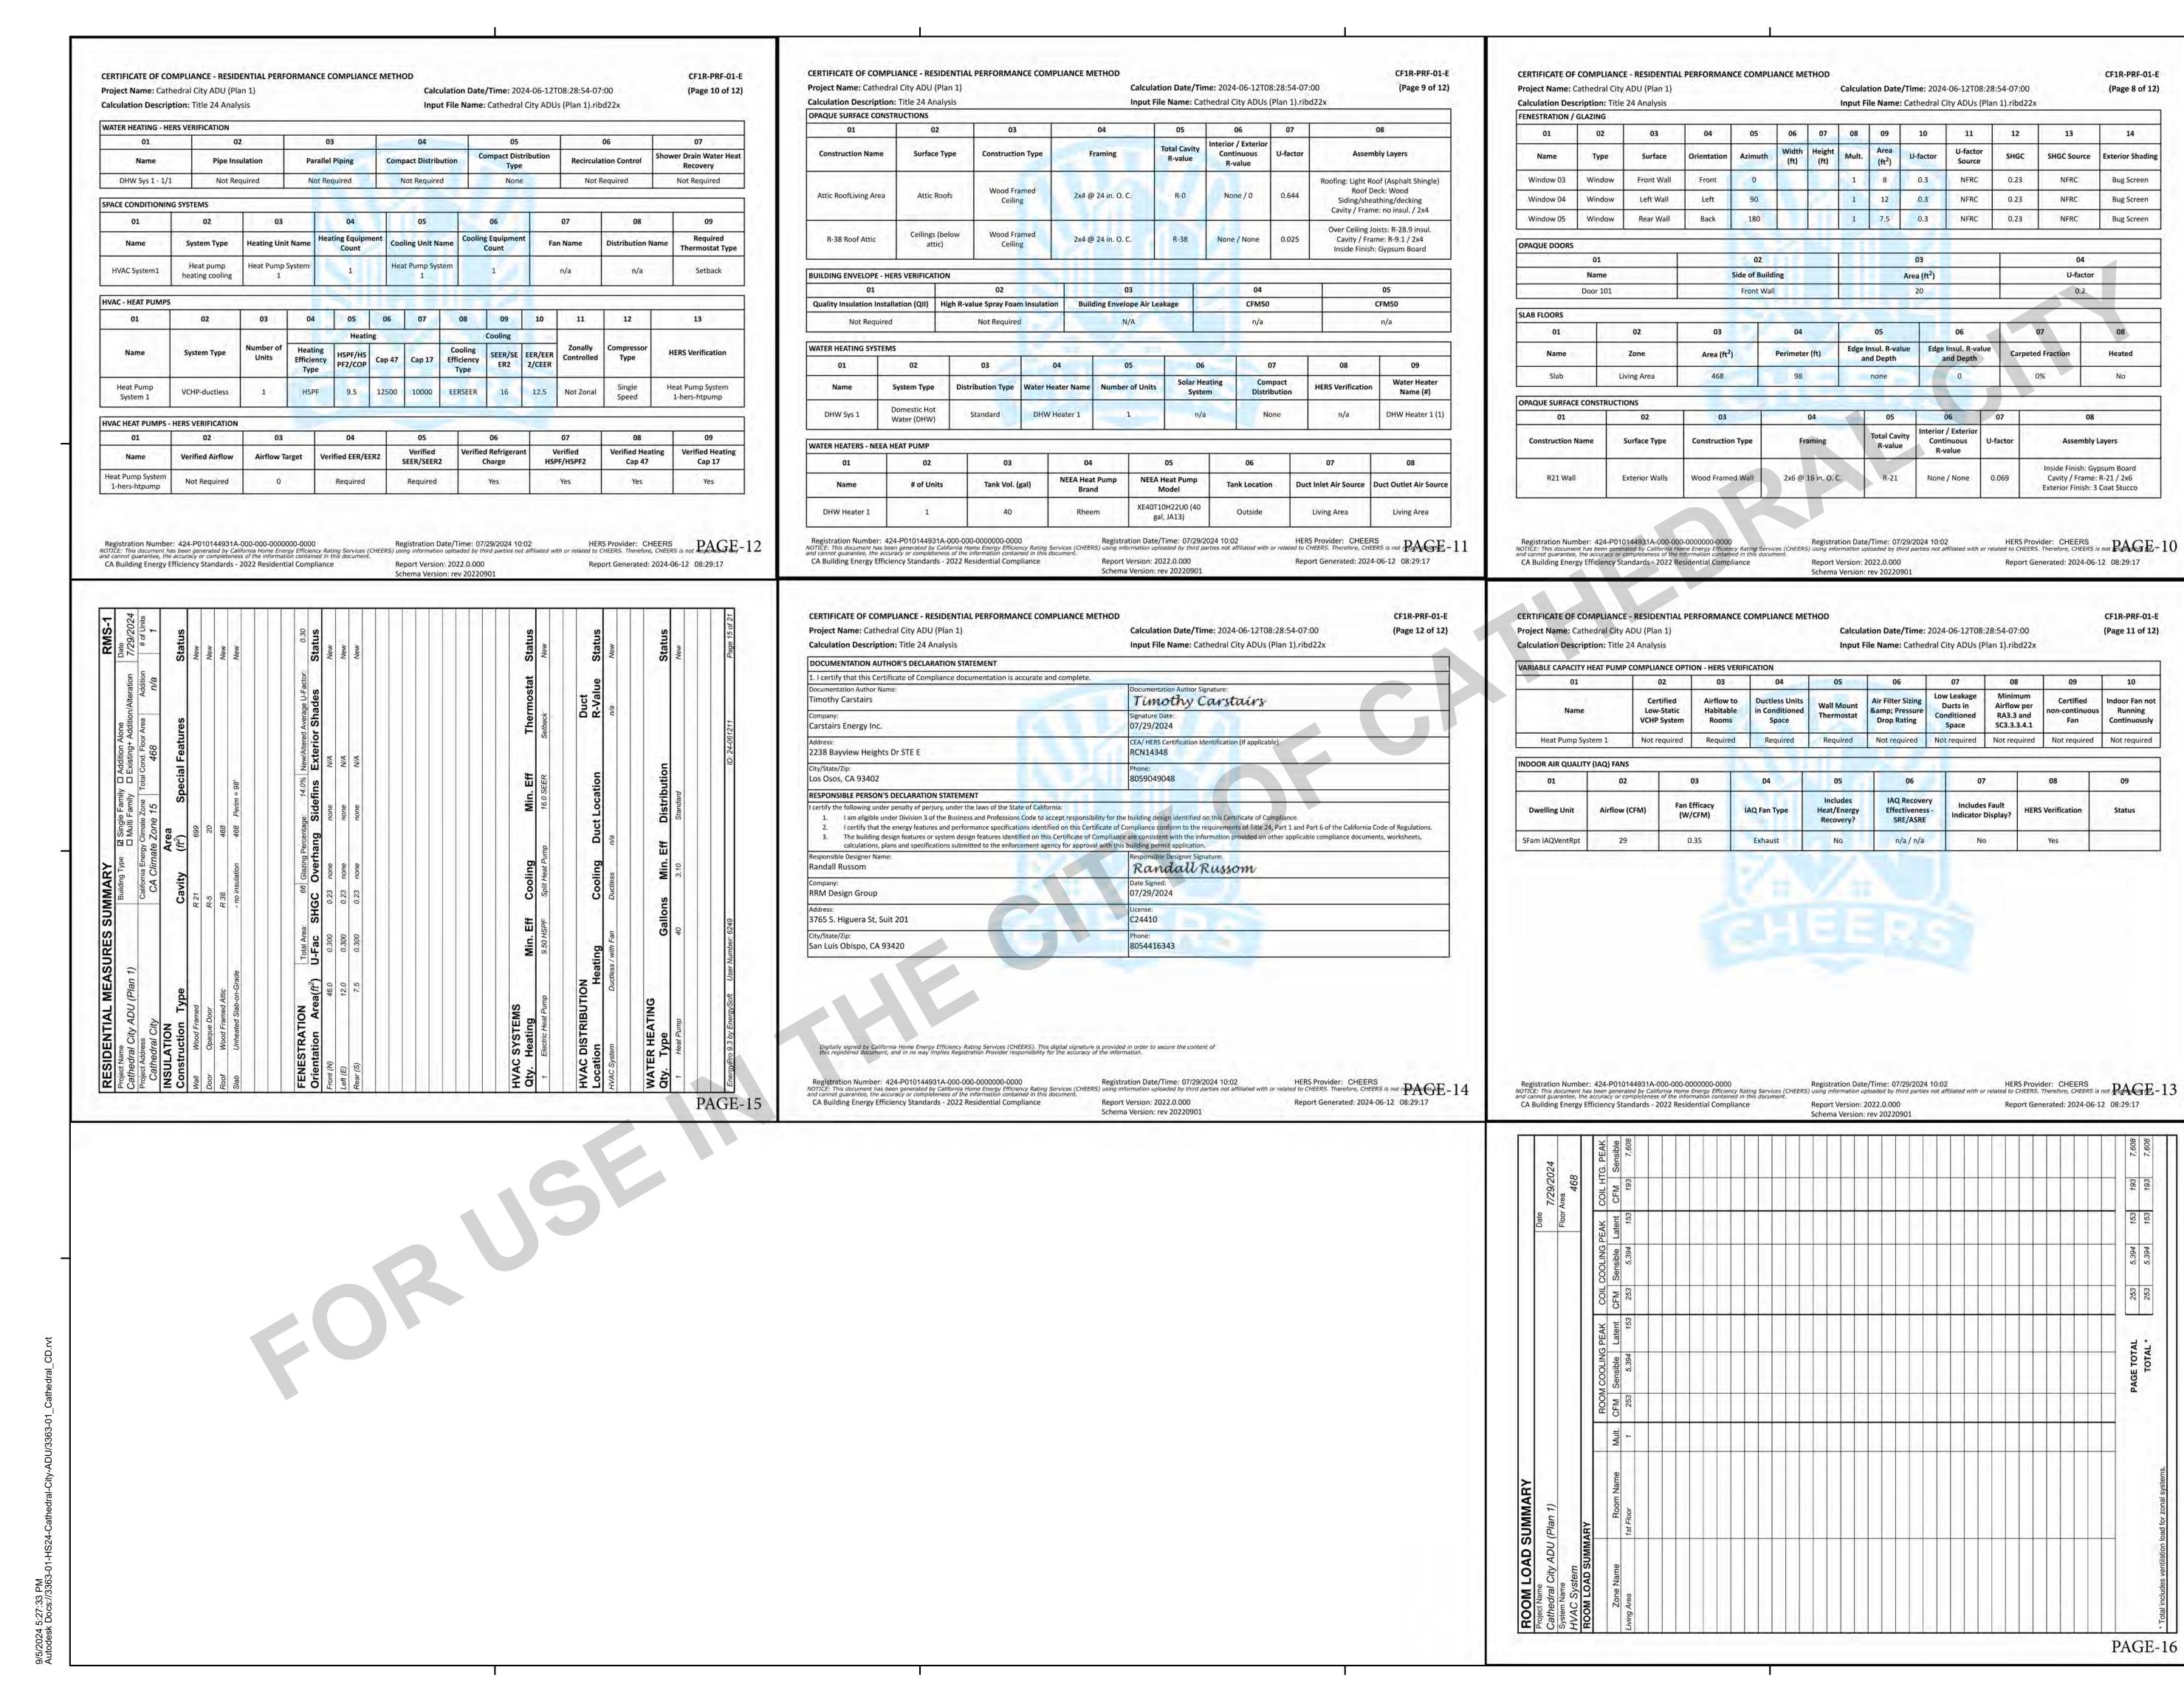

Cathedral City

THESE PLANS ARE PROVIDED BY THE CITY OF CATHEDRAL CITY AS PART OF THE PRE-APPROVED ADU PROGRAM AND ARE PUBLIC DOMAIN. THERE CANNOT BE A CHARGE TO PROVIDE THESE PLANS. NO ALTERATIONS TO THESE PLANS ARE ALLOWED. ALL ALTERATIONS MUST BE DONE UNDER A SEPARATE PERMIT ONCE THE BUILDING PERMIT FOR THE ADU HAS BEEN ISSUED AND FINAL INSPECTION COMPLETED. IF YOU DO NOT HAVE THE CONSTRUCTION KNOWLEDGE AND EXPERIENCE TO CONTRUCT THESE PLANS WITHOUT FURTHER DETAILS, IT IS RECOMMENDED YOU HIRE A CONTRACTOR TO DO THE CONSTRUCTION. THE CITY WILL NOT PROVIDE FURTHER INFORMATION OR DETAILS AND BUILDING INSPECTORS WILL NOT PROVIDE STEP BY STEP INSTRUCTIONS IN THE FIELD.

> 4 CITY

ATHEDRAL U


ENERG

08/08/24

SET

PUBLIC

SHEET T24-102

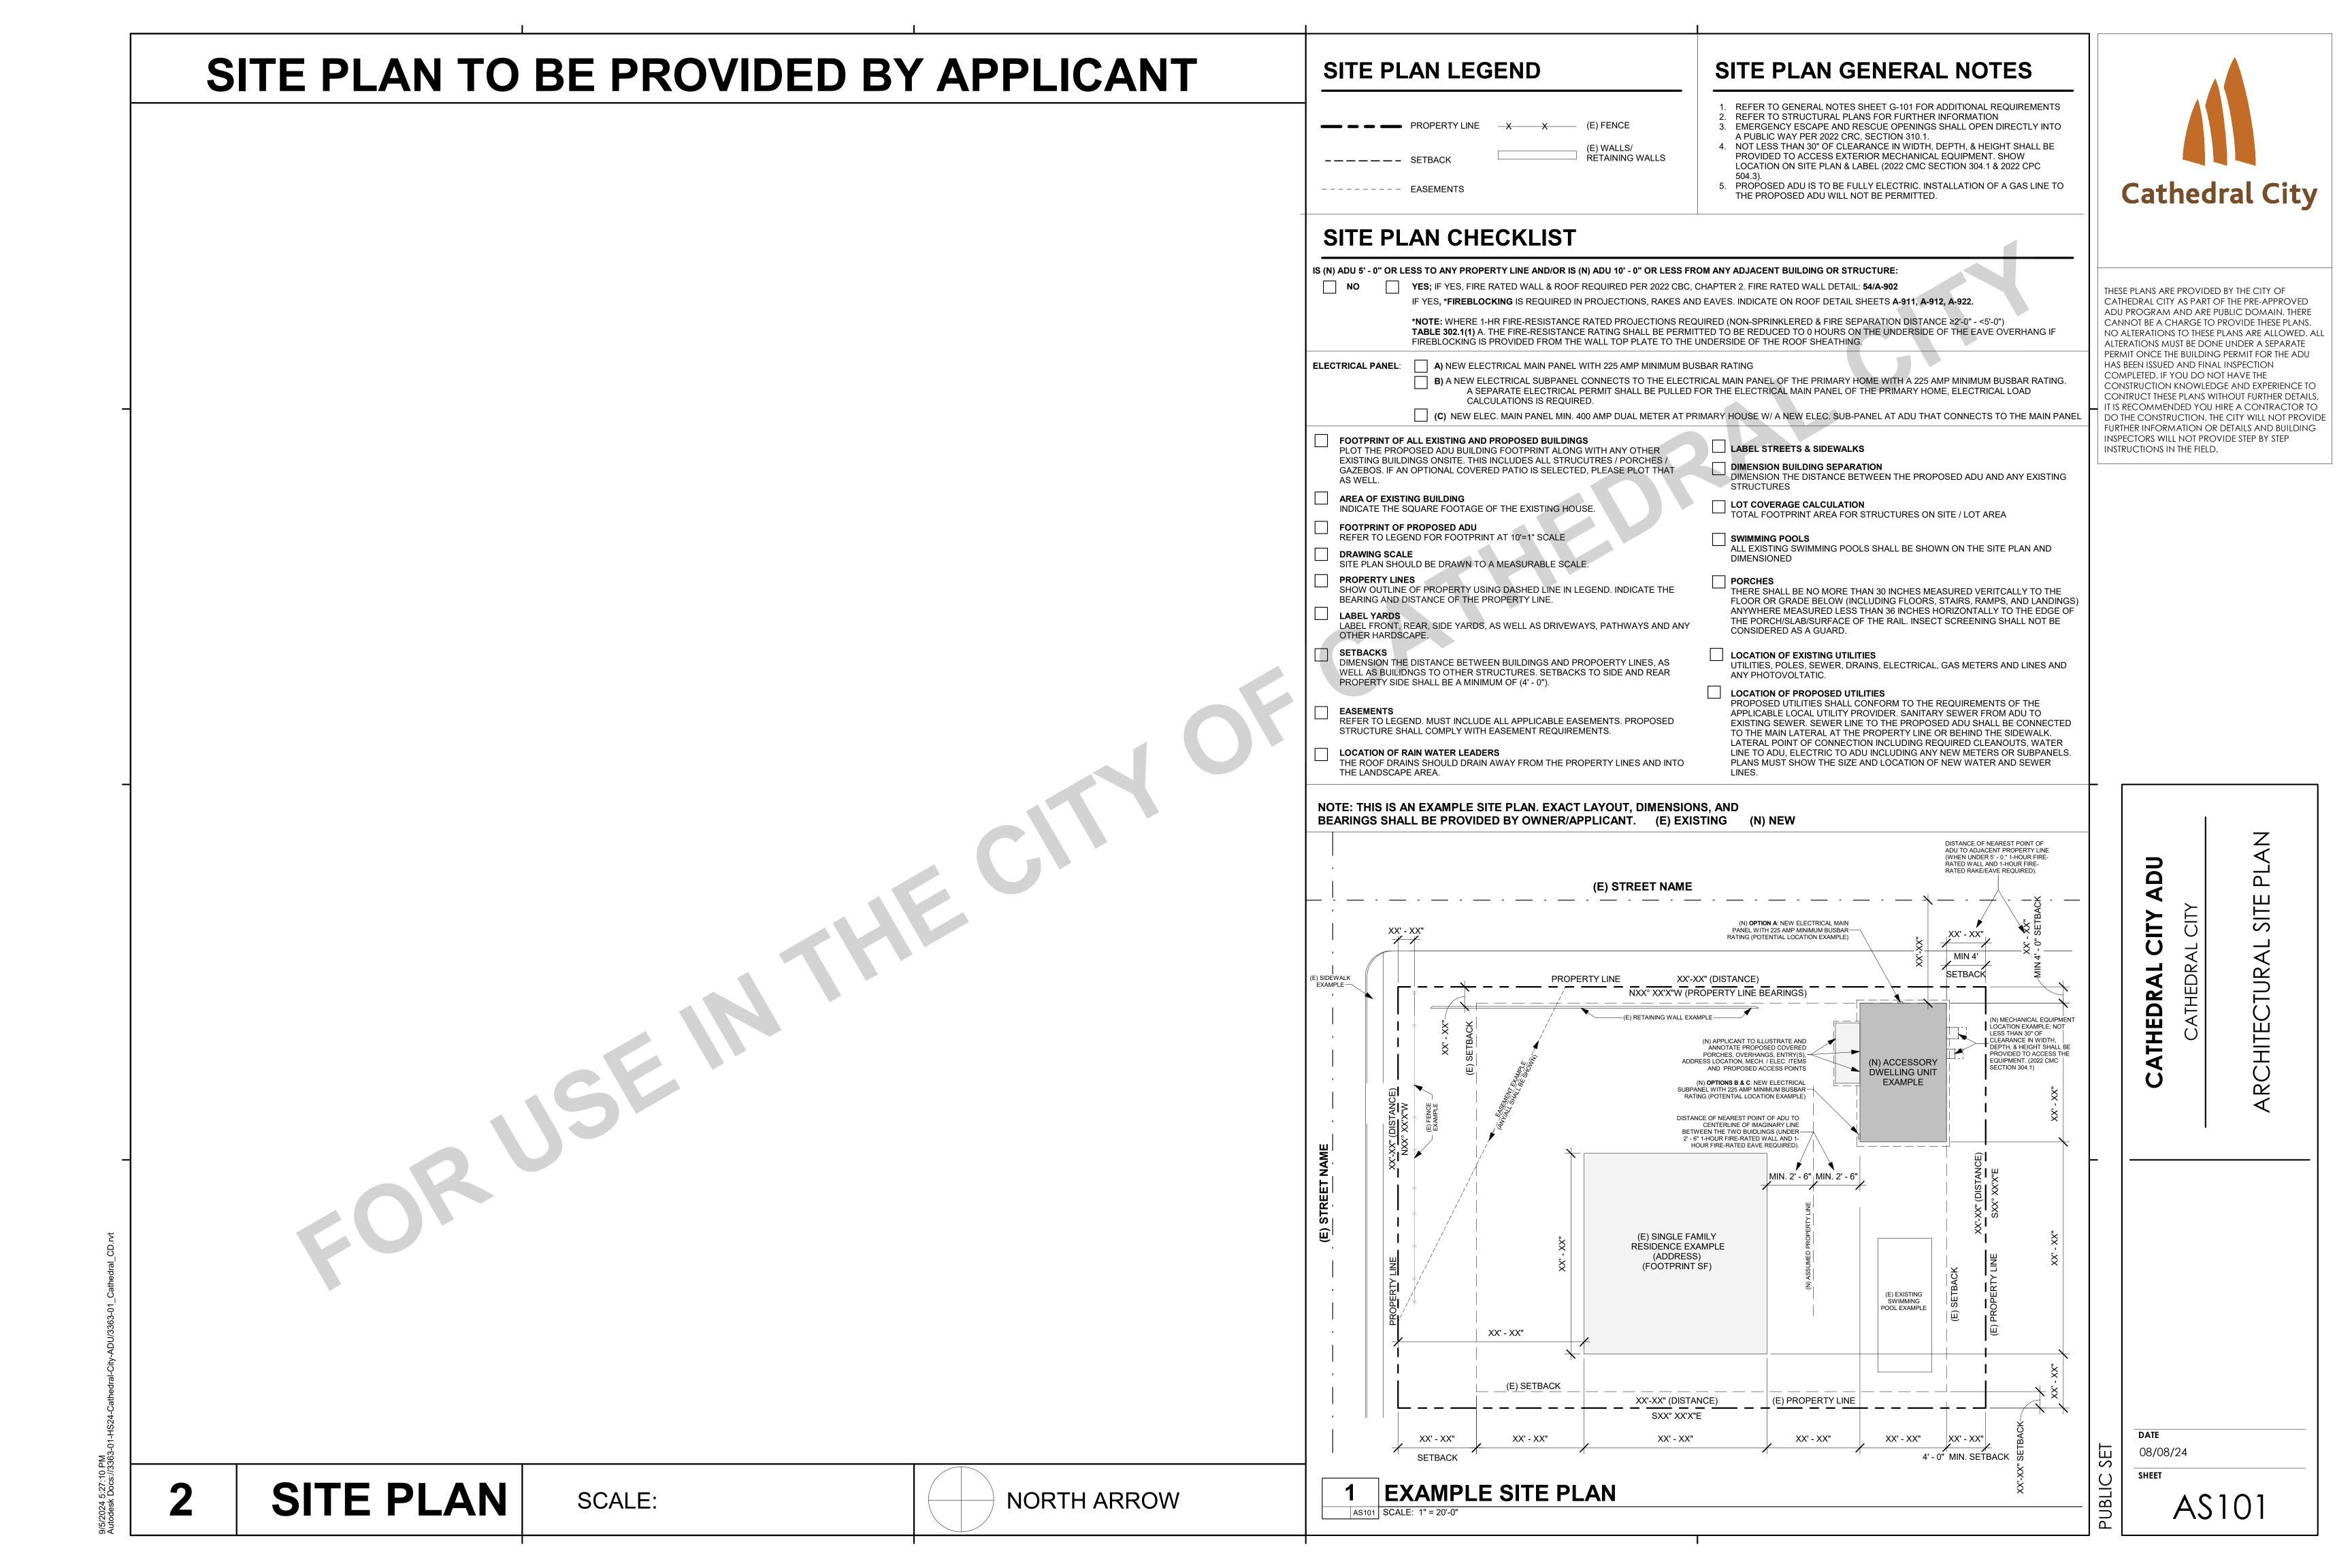





THESE PLANS ARE PROVIDED BY THE CITY OF CATHEDRAL CITY AS PART OF THE PRE-APPROVED ADU PROGRAM AND ARE PUBLIC DOMAIN. THERE CANNOT BE A CHARGE TO PROVIDE THESE PLANS. NO ALTERATIONS TO THESE PLANS ARE ALLOWED. ALL ALTERATIONS MUST BE DONE UNDER A SEPARATE
PERMIT ONCE THE BUILDING PERMIT FOR THE ADU
HAS BEEN ISSUED AND FINAL INSPECTION
COMPLETED. IF YOU DO NOT HAVE THE
CONSTRUCTION KNOWLEDGE AND EXPERIENCE TO
CONTRUCT THESE PLANS WITHOUT FURTHER DETAILS, IT IS RECOMMENDED YOU HIRE A CONTRACTOR TO DO THE CONSTRUCTION. THE CITY WILL NOT PROVIDE FURTHER INFORMATION OR DETAILS AND BUILDING INSPECTORS WILL NOT PROVIDE STEP BY STEP INSTRUCTIONS IN THE FIELD.

PLAN 1 - MEDITERRANEAN




ADU CATHEDRAL CITY

1 RENDERINGS

DATE 08/08/24

PUBLIC A1-100

PLAN 1 - DESERT MODERN

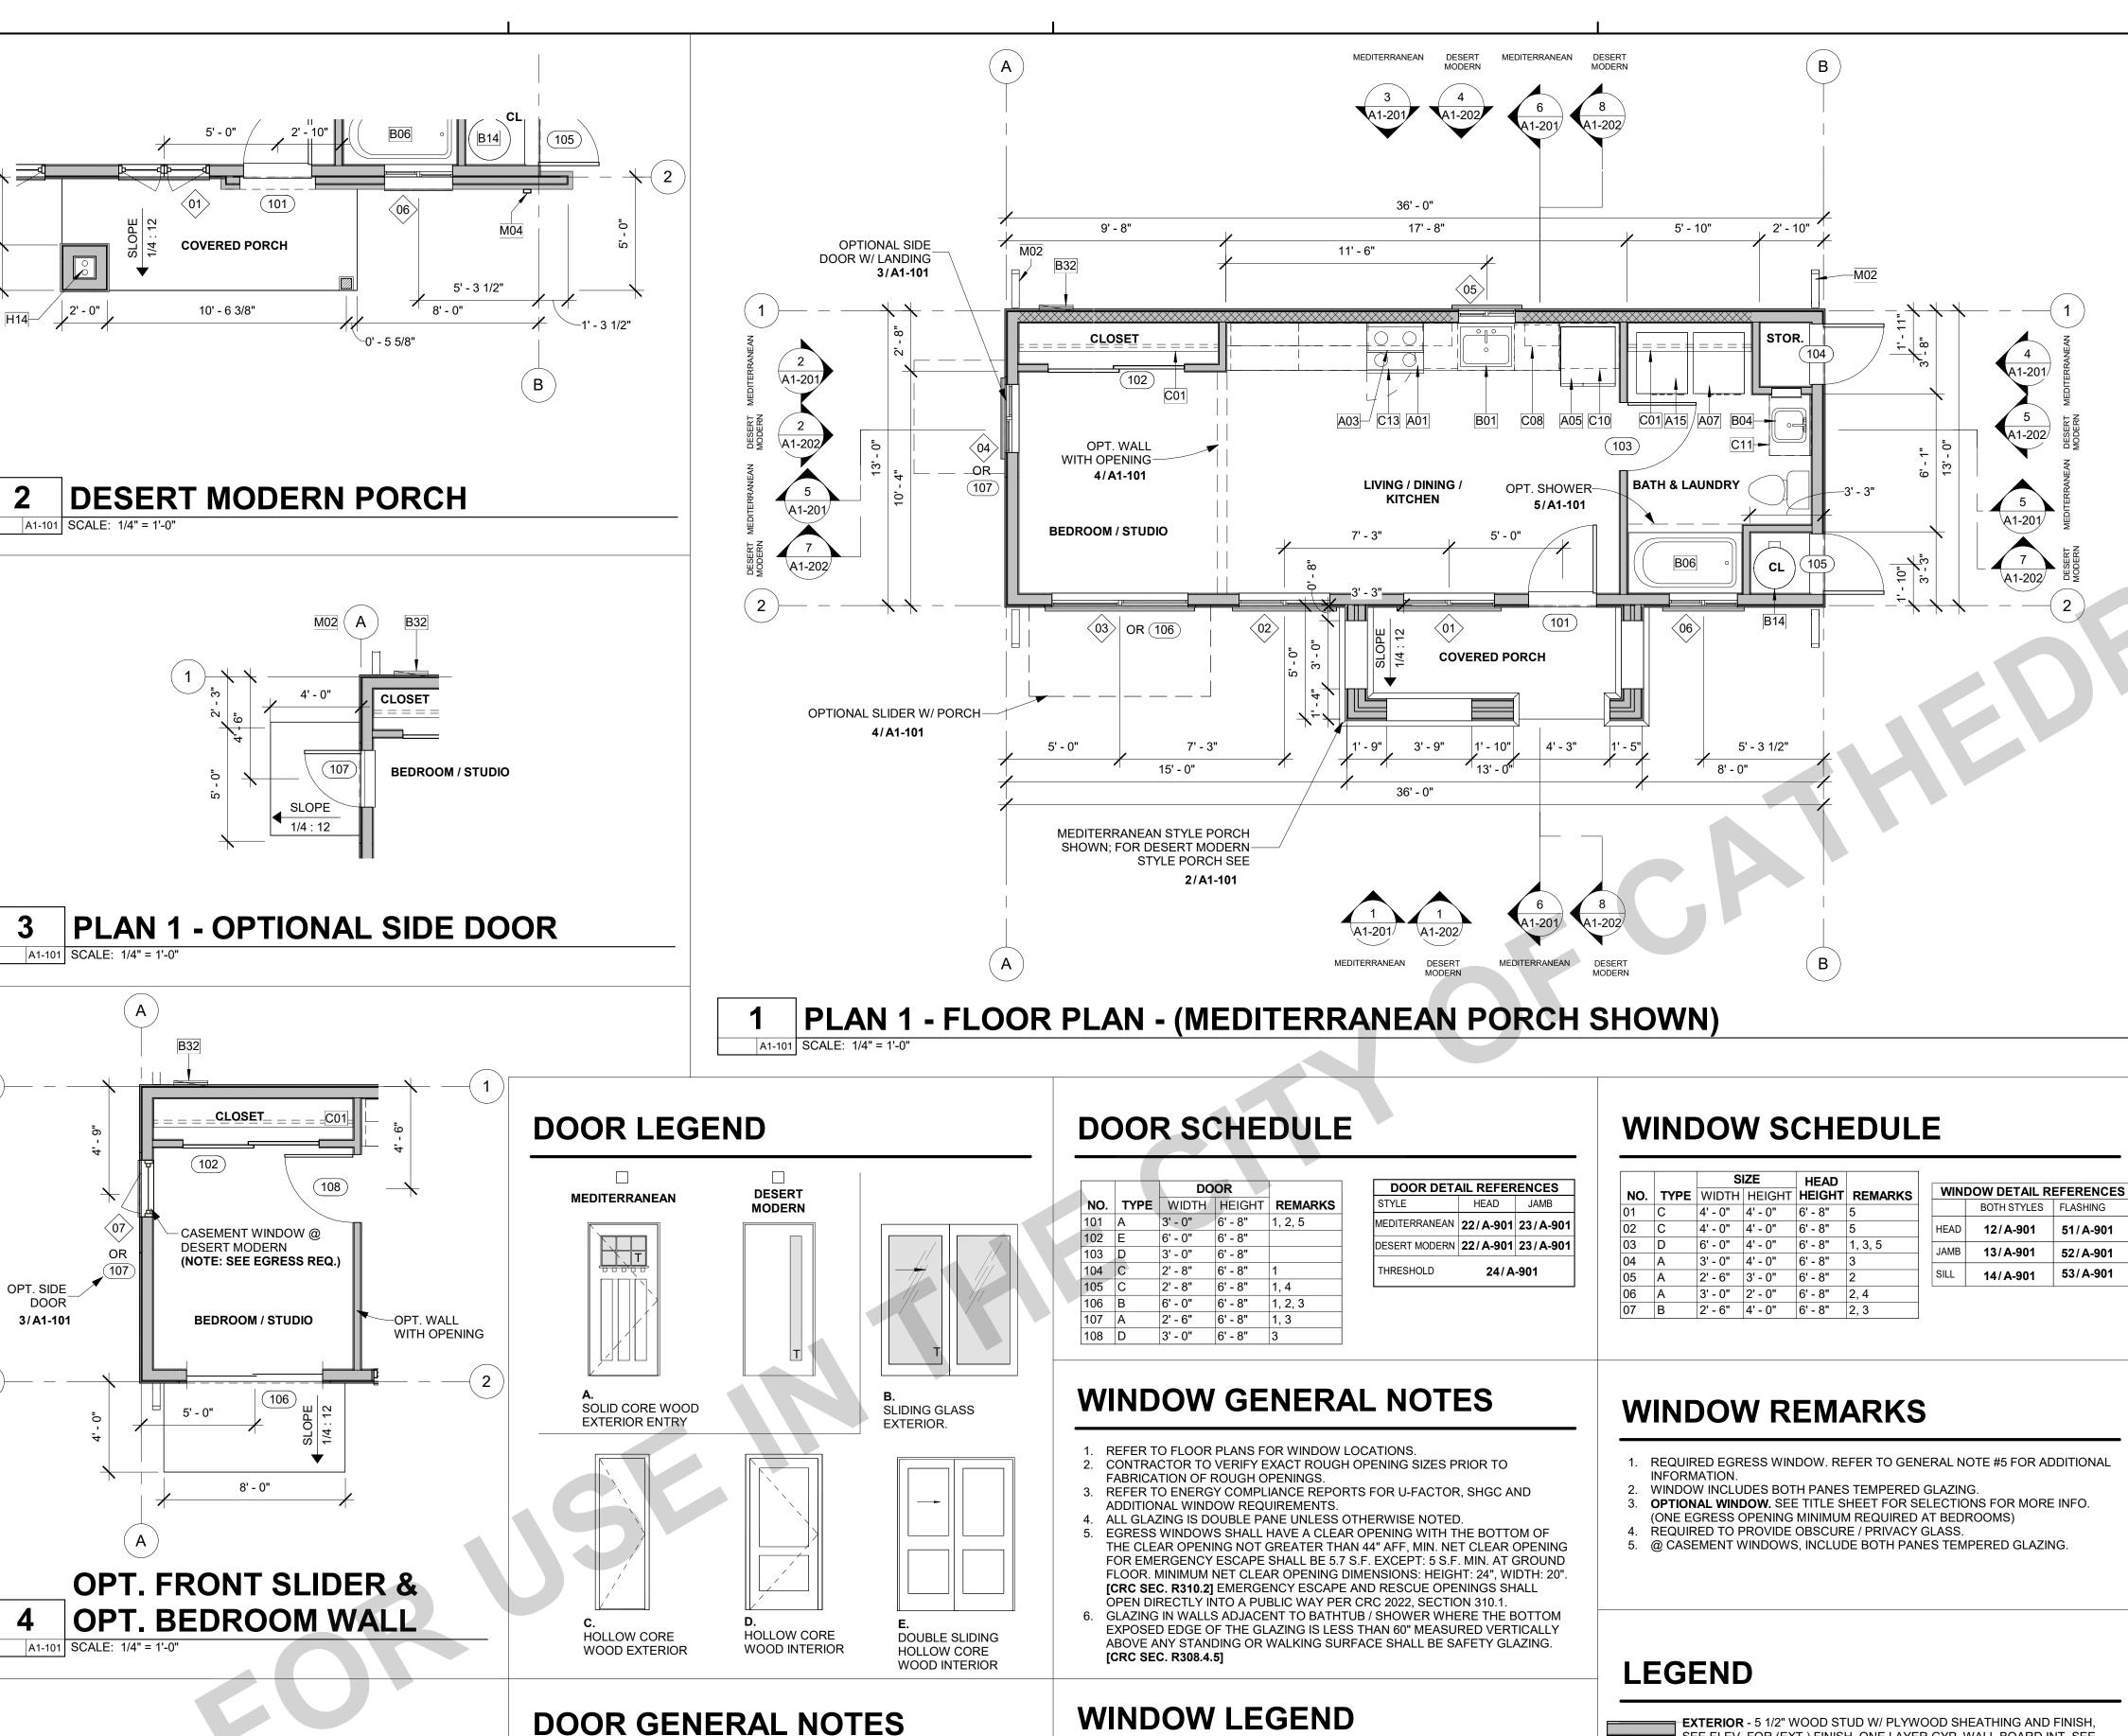

DESERT MODERN

SINGLE

CASEMENT

TRIPLE

CASEMENT

EQ EQ EQ

 \times \times

HORIZONTAL

FQ FQ

SLIDER

DOUBLE

CASEMENT

MEDITERRANEAN

A, B, C, D

HORIZONTAL SLIDER

- GLAZING IN DOORS SHALL BE TEMPERED PER **SECTION R308.4.1**. PANES
- INDICATED IN DOOR LEGEND WITH (T). REFER TO GENERAL NOTES SHEET G-101 FOR ADDITIONAL REQUIREMENTS.
- REFER TO PLANS FOR LOCATION OF DOORS. 4. VERIFY ROUGH OPENING SIZE WITH DOOR MANUFACTURER SPECIFICATIONS
- PRIOR TO CONSTRUCTION.
- CONTRACTOR TO VERIFY ACTUAL DOOR SIZE TO FIT FINISH OPENING PRIOR TO FABRICATION OF DOOR AND FINISH OPENING
- FIRE RATED DOORS SHALL BE SOLID WOOD OR SOLID HONEYCOMB CORE STEEL DOOR 1-3/8" THICK OR COMPLIANT WITH CRC SECTION R302.5.1. DOORS SHALL BE SELF-CLOSING AND SELF-LATCHING WITH WEATHER

DOOR REMARKS

STRIPPING TO BE TIGHT FITTING

- GLAZING PER DOOR TYPES. REFER TO GENERAL DOOR NOTE #1 OPTIONAL DOOR. SEE TITLE SHEET FOR SELECTIONS FOR MORE INFO. (ONE
- EGRESS OPENING MINIMUM REQUIRED AT BEDROOMS)

REQUIRED OPENING OF NOT LESS THAN 100 IN2 FOR MAKEUP AIR SHALL BE PROVIDED IN THE DOOR OR BY APPROVED MEANS. [CMC SEC. R504.4.1]

EXTERIOR - 5 1/2" WOOD STUD W/ PLYWOOD SHEATHING AND FINISH, $^{f J}$ SEE ELEV. FOR (EXT.) FINISH. ONE LAYER GYP. WALL BOARD INT. SEE T24 FOR INSULATION.

EXTERIOR - 5 1/2" WOOD STUD W/ PLYWOOD SHEATHING AND FINISH

ON BOTH SIDES, SEE ELEV. FOR (EXT.) FINISH. SEE T24 FOR INSUL. **EXTERIOR**- DOUBLE 3 1/2" WOOD STUD W/ PLYWOOD SHEATHING (WITH 2"

AIRSPACE) AND FINISH ON BOTH SIDES, SEE ELEVATION FOR FINISH. INTERIOR - 3 1/2" WOOD STUD W/ ONE LAYER GYP. WALL BOARD EACH SIDE.

XXXXXXXXXX ADD BLOCKING AS NEEDED IN THESE LOCATIONS PER DETAIL: 44/A-901

NOTE: SEE MANUFACTURER PRODUCT LISTINGS FOR (A) IMPROVED ACOUSTIC / SOUND PERFORMANCE OPTIONS (AND/OR) (B) IMPROVED MOISTURE / MOLD / MILDEW-RESISTANT PERFORMANCE OPTIONS. SEE COVER SHEET FOR SELECTIONS AND

NOTE: 5/8" GYP ATTACHED DIRECTLY TO STUDS IS ASSUMED U.N.O.; VERIFY PRODUCT SELECTIONS & REQUIREMENTS, THICKNESS, AND LOCATIONS ON PLANS BEFORE CONSTRUCTION. COORDINATE PRODUCT SLECTIONS AND REQUIREMENTS. INSTALL PER MANUFACTURER'S SPECIFICATIONS.

ANNOTATE LOCATIONS OF IMPROVEMENTS.

NOTE: SEE GYPSUM.ORG FOR MORE INFORMATION. SOME POTENTIAL PRODUCTS CAN BE FOUND (BUT ARE NOT LIMITED TO) THE FOLLOWING MANUFACTURERS: CERTAINTEED.COM, PABCOGYPSUM.COM, GOLDBONDBUILDING.COM.

FLOOR PLAN GENERAL NOTES

- REFER TO GENERAL NOTES SHEET G-101 FOR ADDITIONAL REQUIREMENTS. REFER TO STRUCTURAL PLANS FOR FURTHER INFORMATION. REFER TO ELECTRICAL PLANS FOR FURTHER INFORMATION IF PROVIDED. REFER TO MECHANICAL PLANS, DRAWINGS OR REPORTS FOR FURTHER
- 5. ALL FURNITURE AND EQUIPMENT IS BY OWNER AND IS SHOWN FOR
 - COORDINATION PURPOSES ONLY.
- DIMENSIONS ARE TO FACE OF FRAMING UNLESS SPECIFICALLY NOTED PROVIDE ADEQUATE BLOCKING IN WALLS FOR CABINETS AND OTHER WALL
- MOUNTED ACCESSORIES INCLUDING BUT NOT LIMITED TO HANDRAILS, SHELVING AND BATHROOM FIXTURES. DOOR AND WINDOW DIMENSIONS ARE CENTERED AT OPENINGS
- WHERE DOOR IS LOCATED WITHOUT DIMENSION AT THE CORNER OF A ROOM IT SHALL BE 4" FROM FACE OF FRAMING OF ADJACENT WALL TO ROUGH DOOR OPENING.
- 10. WHERE RECESSED FIXTURES OCCUR IN WALLS OR HORIZONTAL ASSEMBLIES, THE FIRE RATING OF THOSE ASSEMBLIES SHALL BE
- 11. AT ALL PENETRATIONS AND INTERSECTIONS OF FIRE-RATED PARTITIONS, PROVIDE FIRE SEALANT AND/OR FIRE STOPPING TO MAINTAIN CONTINUITY OF PARTITION RATING.

OTHER CONSTRUCTION MATERIALS APPROVED BY THE ENFORCING

12. PER CRC R311.3 FLOORS OR LANDINGS AT EXTERIOR DOORS SHALL BE AT LEAST AS WIDE AS DOOR SERVED AND SHALL PROVIDE A LENGTH IN THE DIRECTION OF TRAVEL EQUAL TO 36 INCHES MINIMUM. SLOPE OF EXTERIOR LANDINGS SHALL NOT EXCEED 1/4" PER FOOT (2% SLOPE). 13. PER CRC 327.1.1 REINFORCEMENT FOR GRAB BARS SHALL BE PROVIDED IN

AT LEAST ONE BATHROOM. 1. REINFORCEMENT SHALL BE SOLID LUMBER OR

AGENCY. 2. REINFORCEMENT SHALL NOT BE LESS THAN 2X8 INCH NOMINAL LUMBER OR OTHER MATERIAL PROVIDING EQ. HT. AND CAPACITY. REINFORCEMENT ABOVE THE FINISHED FLOOR FLUSH WITH THE WALL BOTH SIDE WALLS OF THE FIXTURE, OR ONE SIDE WALL AND THE BACK WALL. 4. SHOWER REINFORCEMENT SHALL BE CONTINUOUS WHERE WALI REINFORCEMENT SHALL BE CONTINUOUS ON EACH END OF THE BATHTUB AND THE BACK WALL, ADDITIONALLY, BACK WALL REINFORCEMENT FOR A LOWER GRAB BAR SHALL BE PROVIDED WITH THE BOTTOM EDGE LOCATED NO MORE THAN 6 INCHES ABOVE THE BATHTUB RIM. REFER TO DETAILS

PLUMBING NOTES

34/A-902, 41/A-902, & 42/902.

- 1. WATER HEATER (REFER TO BUILDING ENERGY ANALYSIS REPORT): A. ALL DOMESTIC HOT WATER PIPING SHALL BE INSULATED. (2022 CPC
- PIPES UP TO 2 INCHES IN DIAMETER: INSULATION WALL THICKNESS NOT
- LESS THAN DIAMETER OF PIPE. (2022 CPC 609.12.2) PIPES GREATER THAN 2 INCHES IN DIAMETER: INSULATION WALL THICKNESS NOT LESS THAN 2 INCHES. (2022 CPC 609.12.2)
- REQUIRED TO HAVE PIPE INSULATION FOR THE DISTANCE OF THE
- FRAMING PENETRATION. (2022 CPC 609.12.2) 2. HOT WATER PIPING BETWEEN THE FIXTURE CONTROL VALVE OR SUPPLY STOP AND THE FIXTURE OR APPLIANCE SHALL NOT BE
- PROVIDE A TEMPERATURE AND PRESSURE RELIEF VALVE WITH A FULL SIZE DRAIN OF GALVANIZED STEEL OR HARD DRAWN COPPER TO THE OUTSIDE OF THE BUILDING WITH THE END OF THE PIPE PROTRUDING 6" MINIMUM @ 2' MAX. ABOVE GRADE POINTING DOWNWARD TO THE TERMINATION - UNTHREADED.

REQUIRED TO BE INSULATED. (2022 CPC 609.12.2)

- COMBUSTION AIR PER MANUFACTURE REQUIREMENTS.
- CLEARANCES PER MANUFACTURE REQUIREMENTS. GROUND PLUMBING SCHEMATIC TO BE SITE SPECIFIC AND SHALL BE THE RESPONSIBILITY OF THE CONTRACTOR

KEYNOTES

- 30" WIDE FREE STANDING ELECTRIC RANGE OVEN. VENT TO EXTERIOR, STAINLESS STEEL
- 30" WIDE BUILT-IN MICROWAVE WITH RANGE VENT, STAINLESS
- REFRIGERATOR LOCATION. PROVIDE 42" SPACE WITH ROUGH
- PLUMBING FOR ICE MAKER (RECESS IN WALL). CLOTHES DRYER LOCATION W/ RECESSED DRYER VENT BOX.
- PROVIDE DRYER VENT. VENT TO OUTSIDE AIR. WASHING MACHINE LOCATION. PROVIDE WASTE AND WATER IN
- RECESSED WALL BOX. 30" SINGLE COMPARTMENT UNDER-MOUNT KITCHEN SINK W/
- GARBAGE DISPOSAL. REFER TO WATER EFFICIENCY REQUIREMENTS ON CALGREEN CODE NOTES SHEET.
- LAVATORY SINK. REFER TO WATER EFFICIENCY REQUIREMENTS ON CALGREEN CODE NOTES SHEETS.
- WATER CLOSET. REFER TO WATER EFFICIENCY REQUIREMENTS ON CALGREEN CODE NOTES SHEETS. WATER CLOSET SHALL NOT BE
- SET CLOSER THAN 15" FROM ITS CENTER TO A SIDE WALL OR **OBSTRUCTION PER CPC, SECTION 402.5.** 32" x 60" x 72" TUB AND SHOWER COMBINATION. MODEL BY
- INTERIOR 50 GALLON TANK WATER HEATER. REFER TO TITLE 24 FOR ADDITIONAL INFORMATION.

BUILDER. PROVIDE SHOWER ROD.

- 100 AMP SERVICE, CONFIRM WITH EXISTING SERVICE. 78" X 36" SHOWER. TILE FLOOR. TILE WALLS AT 84" AFS. PROVIDE
- GLASS SHOWER ENCLOSURE
- SINGLE WOOD SHELF AND POLE
- C08 12" DEEP UPPER CABINET C10 24" DEEP UPPER CABINET 22" DEEP VANITY
- 36" HIGH BASE CABINET AND COUNTERTOP C13 DRAIN WITH OVERFLOW SYSTEM (CONCEALED) DRAIN TO AWAY FROM BUILDNG & TIE INTO SITE DRAINAGE
- DOWNSPOUT TO SPLASH BLOCK BELOW. SEE DETAIL 12/A-902. M04 OVERFLOW SCUPPER. 4" x 10" OPENING PER 2016 CPC 1101.12.2.1.

08/08/24

A1-101

Cathedral City

THESE PLANS ARE PROVIDED BY THE CITY OF

CATHEDRAL CITY AS PART OF THE PRE-APPROVED

ADU PROGRAM AND ARE PUBLIC DOMAIN. THERE

CANNOT BE A CHARGE TO PROVIDE THESE PLANS.

ALTERATIONS MUST BE DONE UNDER A SEPARATE

PERMIT ONCE THE BUILDING PERMIT FOR THE ADU

CONSTRUCTION KNOWLEDGE AND EXPERIENCE TO

CONTRUCT THESE PLANS WITHOUT FURTHER DETAILS,

IT IS RECOMMENDED YOU HIRE A CONTRACTOR TO DO THE CONSTRUCTION. THE CITY WILL NOT PROVIDE

FURTHER INFORMATION OR DETAILS AND BUILDING

INSPECTORS WILL NOT PROVIDE STEP BY STEP

HAS BEEN ISSUED AND FINAL INSPECTION

COMPLETED. IF YOU DO NOT HAVE THE

INSTRUCTIONS IN THE FIELD.

ATHEDR,

U


NO ALTERATIONS TO THESE PLANS ARE ALLOWED. ALI

SHEET

BATH & LAUNDRY


PLAN 1 - OPT. SHOWER

A1-101 SCALE: 1/4" = 1'-0"

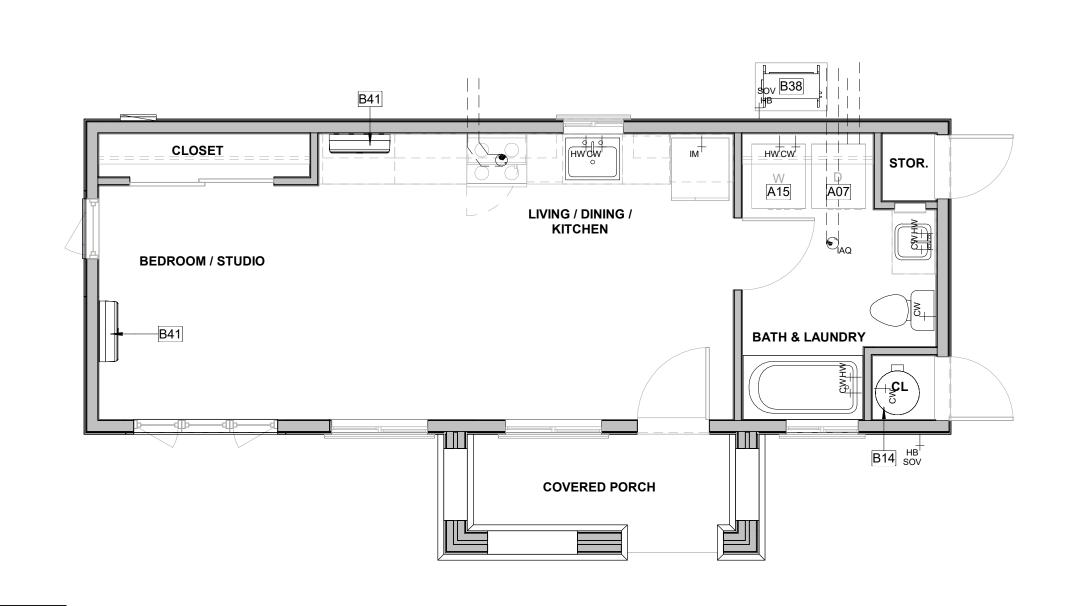

MECHANICAL PLAN - PLAN 1

A1-111 SCALE: 1/4" = 1'-0'

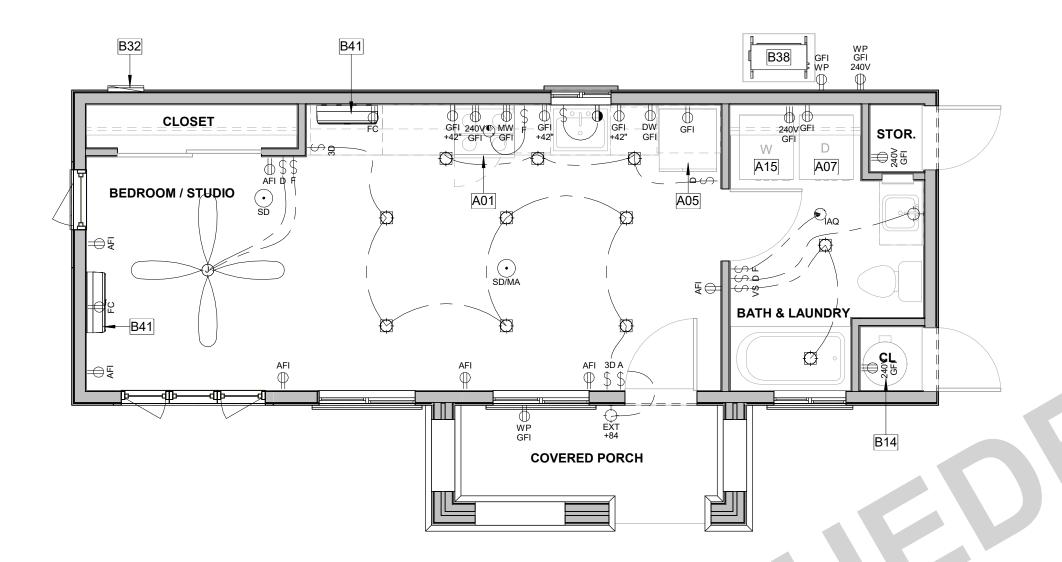

ELECTRICAL PLAN - PLAN 1

A1-111 SCALE: 1/4" = 1'-0"

VENTILATION SUMMARIES

ATHROOM	OPTION A	OPTION B
BATHROOM FAN FLOW (cfm)	50 CFM	50 CFM
DUCT TYPE	FLEX DUCT	SMOOTH DUC
DUCT SIZE (in)	4"	4"
MAX. ALLOWABLE DUCT LENGTH (ft)	70'	105'
THIS EXHAUST FAN IS REQUIRED TO BE RATED F	OR SOUND AT A MAX.	OF 3 SONES.
ITOLIFAL	OPTION A	OPTION B
<u>ITCHEN</u>	OF HON A	OF HOM B
KITCHEN FAN FLOW (cfm)	100 CFM	50 CFM
	100 CFM	50 CFM
KITCHEN FAN FLOW (cfm)	100 CFM FLEX DUCT	50 CFM
KITCHEN FAN FLOW (cfm) DUCT TYPE	100 CFM FLEX DUCT 5"	50 CFM SMOOTH DUC

	THIS EXHAUST FAN IS REQUIRED TO BE RATED FOR	SOUND AT A MAX. OF	3 SONES.
HO	LE BUILDING VENTILATION	OPTION A	OPTION B
	PER ASHRAE STANDARD 62.2, CEC EQUATION	N 150.0-B	
	BUILDING FAN FLOW (cfm)	50 CFM	50 CFM
	DUCT TYPE	FLEX DUCT	SMOOTH DUCT
	DUCT SIZE (in)	4"	4"
	MAX. ALLOWABLE DUCT LENGTH (ft)	70'	105'
	THIS EXHAUST FAN IS REQUIRED TO BE RATED FOR S	SOUND AT A MAX. OF	1 SONE.
	THIS EXHAUST FAN IS REQUIRED TO OPERATE CONT	INUOUSLY TO ENSUR	Ε
	CONTINUOUSLY TO ENSURE INDOOR AIR QUALITY.		

WHOLE DWELLING UNIT MECHANICAL VENTILATION PER SECTION 150.0(O)(C)(i) [ASHRAE 62.2:4.1.2] **1 BED** - MINIUM CUBIC FEET PER MINUTE (CFM) (Equation 150.0-B) Qtot = 0.03Afloor + 7.5(Nbr + 1).03(468 sf) + 7.5 (1) = 21.54 CFM < 50 CFM

EFFECTIVE ANNUAL AVERAGE INFILTRATION RATE

a. 1. (Equation 150.0-C) Q50 = Vdu (x) 2 ACH50 / 60minutes a. 2. (Equation 150.0-D) Q50 = Vdu (x) Verified ACH50 / 60minutes b. (Equation 150.0-E) Qtot = $0.052 (x) Q50 x wsf x [H/Hr]^z [ASHRAE 62.2:4.1.2.1]$

REQUIRED MECHANICAL VENTILATION RATE AND REQUIRED MECHANICAL VENTILATION RATE PER 150.0(O)(C)(iii) (Equation 150.0-F) Qfan = Qtot (-) ϕ (Qinf (x) Aext)

KEYNOTES

BATH & LAUNDRY

COVERED PORCH

CL \

- A01 30" WIDE FREE STANDING ELECTRIC RANGE OVEN. VENT TO EXTERIOR. STAINLESS STEEL.
- A05 REFRIGERATOR LOCATION. PROVIDE 42" SPACE WITH ROUGH PLUMBING FOR ICE MAKER (RECESS IN WALL).
- A07 CLOTHES DRYER LOCATION W/ RECESSED DRYER VENT BOX. PROVIDE DRYER VENT. VENT TO OUTSIDE AIR.
- A15 WASHING MACHINE LOCATION. PROVIDE WASTE AND WATER IN RECESSED
- WALL BOX.
- B14 INTERIOR 50 GALLON TANK WATER HEATER. REFER TO TITLE 24 FOR
- ADDITIONAL INFORMATION.

B32 100 AMP SERVICE, CONFIRM WITH EXISTING SERVICE.

- B38 MULTI-ZONE HEAT PUMP CONDENSER UNIT. REFER TO PLANS FOR LOCATION OF INDOOR FAN COIL UNITS. REFER TO TITLE 24 FOR ADDITIONAL INFORMATION. PROVIDE CONCRETE PAD MIN. 6" LARGER THAN UNIT IN EACH DIRECTION, 3" MIN. ABOVE GRADE. PROVIDE PROTECTION PER CPC 507.25 & CMC 305.1.1, SEE GENERAL MEP NOTES 7 & 8 ON SHEET A-111 FOR MORE INFO. SEE DETAIL 53/A-902.
- B41 FAN COIL @ 80" A.F.F. TO BOTTOM OF UNIT, PROVIDE DEDICATED WALL OUTLET, INSTALL PER MANUFACTERER'S SPECIFICATIONS, REFER TO PLANS FOR LOCATION OF OUTDOOR CONDENSING UNIT. REFER TO TITLE 24 FOR ADDITIONAL INFORMATION.

LEGEND

\$ 3	ELECTRICAL SWITCH ELECTRICAL SWITCH-THREE WAY	SMC MINI ALL	E: IONIZATION DIKE DETECTOR 10' MUM FROM STOVE, OTHERS 20'MIN ARANCE	AFI GFI 240V	DUPLEX OUTLET ARC-FAULT CIRCUIT INTERRUPTER DUPLEX OUTLET
VS				\bigoplus	240 VOLTS
\$	ELECTRICAL SWITCH- VACANCY SENSOR	SD	SMOKE DETECTOR/ALARM	WP GFI 240V	DUPLEX OUTLET WATERPROOF 240 VOLTS
D \$	ELECTRICAL	SD/MA	COMBINATION SMOKE/CARBON	GFI	
\	SWITCH-DIMMER	SD/MA	MONOXIDE	φ	DUPLEX OUTLET GROUND FAULT
F	ELECTRICAL SWITCH-FAN	①	ELECTRICAL JUNCTION BOX		INTERRUPTER
A \$	ASTRONOMICAL				
Ψ	TIME OR MOTION SENSOR SWITCH (AT LEAST 1 REQ.)			GFI WP	DUPLEX OUTLET WATERPROOF GROUND FAULT INTERRUPTER
	EXHAUST FAN				INTERRUPTER
IAQ	INDOOR AIR QUALITY FAN			Φ	DUPLEX OUTLET AFCI-HALF HOT
_			/ \		DUDI EV QUELET

GFI DUPLEX OUTLET PENDANT LIGHT MW MICROWAVE HIGH-EFFICACY GROUND FAULT INTERRUPTER WALL MOUNTED **CEILING FAN OPTIONAL** HIGH-EFFICACY DUPLEX OUTLET (PRE WIRE FOR CEILING LIGHT DISH WASHER FAN ONLY) **GROUND FAULT EXTERIOR WALL** INTERRUPTER MOUNTED HIGH-

EFFICACY LIGHT W/ DUPLEX OUTLET PHOTO SENSOR RANGE HOOD ELECTRICAL RECESSED cw COLD WATER WIRING HIGH- EFFICACY STUB OUT DOWNLIGHT HW HOT WATER STUB

OUT RECESSED HIGH- EFFICACY VP DOWNLIGHT-VAPOR PROOF HB WATER HOSE BIBB SOV WATER HOSE BIBB WITH SHUT OF 22"X30" MIN. ATTIC VALVE ACCESS PANEL (WHERE

NOTE: IONIZATION SMOKE DETECTOR 10' MINIMUM FROM STOVE, ALL OTHERS 20'MIN CLEARANCE

FLOOR FINISH LEGEND







MINISPLIT UNIT +80"

TO BOTTOM OF UNIT

PROVIDE POWER

TO MINISPLIT

OUTLET

PROVIDE DEDICATED

GENERAL MEP NOTES

- REFER TO ELECTRICAL NOTES ON SHEET G-101.
- 2. REFER TO MECHANICAL NOTES ON SHEET G-101. REFER TO PLUMBING NOTES ON SHEET G-101.
- REFER TO TITLE 24 COMPLIANCE NOTES ON SHEET G-101. 5. EXTERNALLY MOUNTED HEATING/COOLING UNITS SHALL BE SCREENED IF
- THEY ARE VISIBLE FROM A PUBLIC STREET. 6. ENVIRONMENTAL AIR DUCT EXHAUST SHALL TERMINATE NOT LESS THAN 3 FT FROM WALL OPENINGS. CMC 502.2.2.1.
- APPLIANCES NOT LISTED FOR OUTDOOR INSTALLATION BUT INSTALLED OUTDOORS SHALL BE PROVIDED WITH PROTECTION TO THE DEGREE THAT THE ENVIRONMENT REQUIRES. APPLIANCES LISTED FOR OUTDOOR INSTALLATION SHALL BE PERMITTED TO BE INSTALLED WITHOUT PROTECTION IN ACCORDANCE WITH THE PROVISIONS OF ITS LISTING AND THE MANUFACTURER'S INSTALLATION INSTRUCTIONS PER CPC 507.25 PROTECTION OF OUTDOOR APPLIANCES.
- APPLIANCES INSTALLED IN GARAGES, WAREHOUSES, OR OTHER AREAS SUBJECT TO MECHANICAL DAMAGE SHALL BE AT LEAST 18" ABOVE THE FLOOR AND GUARDED AGAINST SUCH DAMAGE BY BEING INSTALLED BEHIND PROTECTIVE BARRIERS OR BY BEING ELEVATED OR LOCATED OUT OF THE NORMAL PATH OF VEHICLES PER CMC 305.1.1 PHYSICAL DAMAGE. INSTALLED AIR CONDITIONER AND HEAT PUMP SYSTEMS SHALL HAVE A
- CLEARANCE OF AT LEAST FIVE (5) FEET FROM THE OUTLET OF ANY DRYER VENT. CENC2022 150.0 (H) 3. 10. INSTALLED AIR CONDITIONER AND HEAT PUMP SYSTEMS SHALL BE EQUIPPED WITH LIQUID LINE DRIERS IF REQUIRED, AS SPECIFIC BY MANUFACTURER'S INSTRUCTIONS. CENC2022 150.0 (H) 3. SEE DETAIL
- PLUMBING NOTES
- 1. WATER HEATER (REFER TO BUILDING ENERGY ANALYSIS REPORT): ALL DOMESTIC HOT WATER PIPING SHALL BE INSULATED. (2022 CPC
 - PIPES UP TO 2 INCHES IN DIAMETER: INSULATION WALL THICKNESS NOT LESS THAN DIAMETER OF PIPE. (2022 CPC 609.12.2) PIPES GREATER THAN 2 INCHES IN DIAMETER: INSULATION WALL THICKNESS NOT LESS THAN 2 INCHES. (2022 CPC 609.12.2)
 - 1. PIPING THAT PENETRATES FRAMING MEMBERS SHALL NOT BE REQUIRED TO HAVE PIPE INSULATION FOR THE DISTANCE OF THE FRAMING PENETRATION. (2022 CPC 609.12.2) 2. HOT WATER PIPING BETWEEN THE FIXTURE CONTROL VALVE OR
- SUPPLY STOP AND THE FIXTURE OR APPLIANCE SHALL NOT BE REQUIRED TO BE INSULATED. (2022 CPC 609.12.2) B. PROVIDE A TEMPERATURE AND PRESSURE RELIEF VALVE WITH A FULL SIZE DRAIN OF GALVANIZED STEEL OR HARD DRAWN COPPER TO THE OUTSIDE OF THE BUILDING WITH THE END OF THE PIPE PROTRUDING 6"
- MINIMUM @ 2' MAX. ABOVE GRADE POINTING DOWNWARD TO THE TERMINATION - UNTHREADED. COMBUSTION AIR PER MANUFACTURE REQUIREMENTS.
- . CLEARANCES PER MANUFACTURE REQUIREMENTS.
- GROUND PLUMBING SCHEMATIC TO BE SITE SPECIFIC AND SHALL BE THE RESPONSIBILITY OF THE CONTRACTOR

ELECTRICAL NOTES

- 1. CONFORM WITH CURRENT CEC, NFPA, MFR'S, AND LOCAL REQUIREMENTS. ELECTRICAL SYSTEM GROUND TO BE PROVIDED PER NEC ARTICLE 250-81. ALL MATERIALS TO BE U.L. LABELED.
- 4. METER: "SQUARE D", 120 VOLT/ 240 VOLT, 1 AND 3 WIRE GROUND OR EQUAL. ELECTRICAL SUB PANEL: FLUSH MOUNT, 30" CLEARANCE. 100 AMP. 6. CONDUCTORS: TW, THW, COPPER, MINIMUM 14 AT LIGHTING, 12 AT OTHER
- 7. ALL LUMINARIES SHALL COMPLY WITH 2022 CENC SECTION 150.0 (K) AND TABLE 150.0-A AS REFERENCED IN ENERGY NOTES, LUMINAIRE REQUIREMENTS SHEET G-101.
- 8. ALL ELECTRICAL OUTLETS INSTALLED IN BATHROOMS, GARAGES, BASEMENTS, CRAWL SPACES, OUTDOORS, KITCHEN COUNTERS, AND AT WET BAR SINKS SHALL HAVE GROUND-FAULT CIRCUIT-INTERRUPTER PROTECTION IN COMPLIANCE WITH NEC Art. 210-8, CONSISTING OF 125 VOLT, SINGLE-PHASE, 15- AND 20- AMPERE RECEPTACLES. 9. ALL BATHROOM RECEPTACLE OUTLETS SHALL BE SUPPLIED BY A MINIMUM
- OF ONE 120-VOLT, 20-AMPERE BRANCH CIRCUIT. SUCH CIRCUITS SHALL HAVE NO OTHER OUTLETS. THIS DEDICATED CIRCUIT MAY SERVE MORE THAN ONE BATHROOM. (2022 CEC 210.11(C)) 10. THERMOSTAT SHALL BE A PROGRAMMABLÉ TYPE, HONEYWELL TH8320 OR
- 11. CEILING-SUSPENDED (PADDLE) FANS SHALL BE SUPPORTED INDEPENDENTLY OF AN OUTLET BOX OR BY LISTED OUTLET BOX OR OUTLET BOX SYSTEMS IDENTIFIED FOR THE USE AND INSTALLED IN ACCORDANCE
- WITH 2022 CEC 314.27(C) (2022 CEC 422.18). 12. ALL LUMINARIES, LAMPHOLDERS, AND RETROFIT KITS SHALL BE LISTED (2022 CEC 410.6).
- 13. ALL 120-VOLT, SINGLE PHASE 15- AND 20- AMPERE BRANCH CIRCUITS SUPPLYING OUTLETS INSTALLED IN DWELLING UNIT KITCHENS, FAMILY ROOMS, LIVING ROOMS, DINING ROOMS, PARLORS, LIBRARIES, DENS, BEDROOMS, SUNROOMS, RECREATION ROOMS, CLOSETS, HALLWAYS OR SIMILAR ROOMS OR AREAS SHALL BE PROTECTED BY A LISTED ARC-FAULT CIRCUIT INTERRUPTER, COMBINATION-TYPE, INSTALLED TO PROVIDE PROTECTION OF THE BRANCH CIRCUIT. (2022 CEC 210-12(A)).
- 14. ALL NON-LOCKING TYPE 125-VOLT, 15 AND 20 AMPERE RECEPTACLES IN A DWELLING UNIT SHALL BE LISTED TAMPER-RESISTANT RECEPTACLES. EXCEPTIONS: (1) RECEPTACLES MORE THAN 5'6" ABOVE THE FLOOR, (2) RECEPTACLES PART OF A LUMINAIRE OR APPLIANCE, (3) A SINGLE RECEPTACLE OR A DUPLEX RECEPTACLE FOR TWO APPLIANCES THAT ARE NOT EASILY MOVED AND LOCATED WITHIN DEDICATED SPACE AND ARE CHORD-AND-PLUG CONNECTED AS PER CEC 400.10, AND (4) NON-GROUNDING RECEPTACLES USED FOR REPLACEMNETS AS PERMITTED IN CEC 406.4(D)(2)(A).
- 15. HIGH EFFICACY LUMINAIRES OTHER THAN OUTDOOR HID LIGHTING CONTAIN ONLY ONLY HIGH EFFICACY LAMPS AS OUTLINED IN TABLE 150-C OF THE RESIDENTIAL ENERGY CODE AND NOT CONTAIN A MEDIUM SCREW BASE
- 16. BALLAST FOR LAMPS 13 WATTS OR GREATER SHALL BE ELECTRONIC AND HAVE AN OUTPUT FREQUENCY NO LESS THAT 20 kHz.
- 17. SMOKE DETECTORS SHALL RECEIVE THEIR PRIMARY POWER FROM THE BUILDING WIRING AND PROVIDED WITH A BATTERY BACK-UP. ALL SMOKE DETECTORS SHALL BE INTERCONNECTEED. ALL SMOKE DETECTORS SHALL MAINTAIN A MINIMUM 3 FOOT CLEARANCE TO HVAC SUPPLY OR RETURN AIR
- 18. CARBON MONOXIDE ALARMS SHALL RECEIVE THEIR PRIMARY POWER FROM THE BUILDING WIRING AND PROVIDED WITH A BATTERY BACK-UP. ALL
- CARBON MONOXIDE ALARAMS SHALL BE INTERCONNECTEED. 19. EXHAUST FANS WILL BE CONTROLLED BY A HUMIDISTAT PER THE GREEN BUILDING STANDARDS CODE SECTION 4.506. EXHAUST FANS MUST BE
- SWITCHED SEPARATELY FROM LIGHTS (2022 CEnC 150.0(k)2G). 20. IN ADDITION TO THE NUMBER OF BRANCH CIRCUTS REQUIRED BY OTHER PARTS OF THE CODE, TWO OR MORE 20-AMPERE SMALL-APPLIANCE BRANCH CIRCUTS SHALL BE PROVIDED FOR ALL RECEPTACLE OUTLETS IN THE KITCHEN, PANTRY, BREAKFAST ROOM, DINING ROOM, OR SIMILAR AREA PER 2022 CEC, ARTICLE 210.11 (C)(1). THE CIRCUTS SHALL HAVE NO OTHER OUTLETS PER 2022 CEC, ARTICLE 210.52(B).
- 21. IN ADDITION TO THE NUMBER OF BRANCH CIRCUTS REQUIRED BY OTHER PARTS OF THE CODE, AT LEAST ONE ADDITIONAL 20-AMPERE BRANCH CIRCUT SHALL BE PROVIDED TO SUPPLY THE LAUNDRY RECEPTACLE OUTLET(S) REQUIRED BY 2022 CEC, ARTICLE 210.52 (F). THIS CIRCUT SHALL HAVE NO OTHER OUTLETS PER 2022 CEC, ARTICLE 201.11(C)(2).

Cathedral City

THESE PLANS ARE PROVIDED BY THE CITY OF CATHEDRAL CITY AS PART OF THE PRE-APPROVED ADU PROGRAM AND ARE PUBLIC DOMAIN. THERE CANNOT BE A CHARGE TO PROVIDE THESE PLANS. NO ALTERATIONS TO THESE PLANS ARE ALLOWED. ALI ALTERATIONS MUST BE DONE UNDER A SEPARATE PERMIT ONCE THE BUILDING PERMIT FOR THE ADU HAS BEEN ISSUED AND FINAL INSPECTION COMPLETED. IF YOU DO NOT HAVE THE CONSTRUCTION KNOWLEDGE AND EXPERIENCE TO CONTRUCT THESE PLANS WITHOUT FURTHER DETAILS, IT IS RECOMMENDED YOU HIRE A CONTRACTOR TO DO THE CONSTRUCTION. THE CITY WILL NOT PROVIDE FURTHER INFORMATION OR DETAILS AND BUILDING INSPECTORS WILL NOT PROVIDE STEP BY STEP INSTRUCTIONS IN THE FIELD.

FINIS

4

ATHEDR,

 ∞


08/08/24

SHEET

FINISH PLAN - PLAN 1 A1-111 SCALE: 1/4" = 1'-0"

CLOSET

BEDROOM / STUDIO

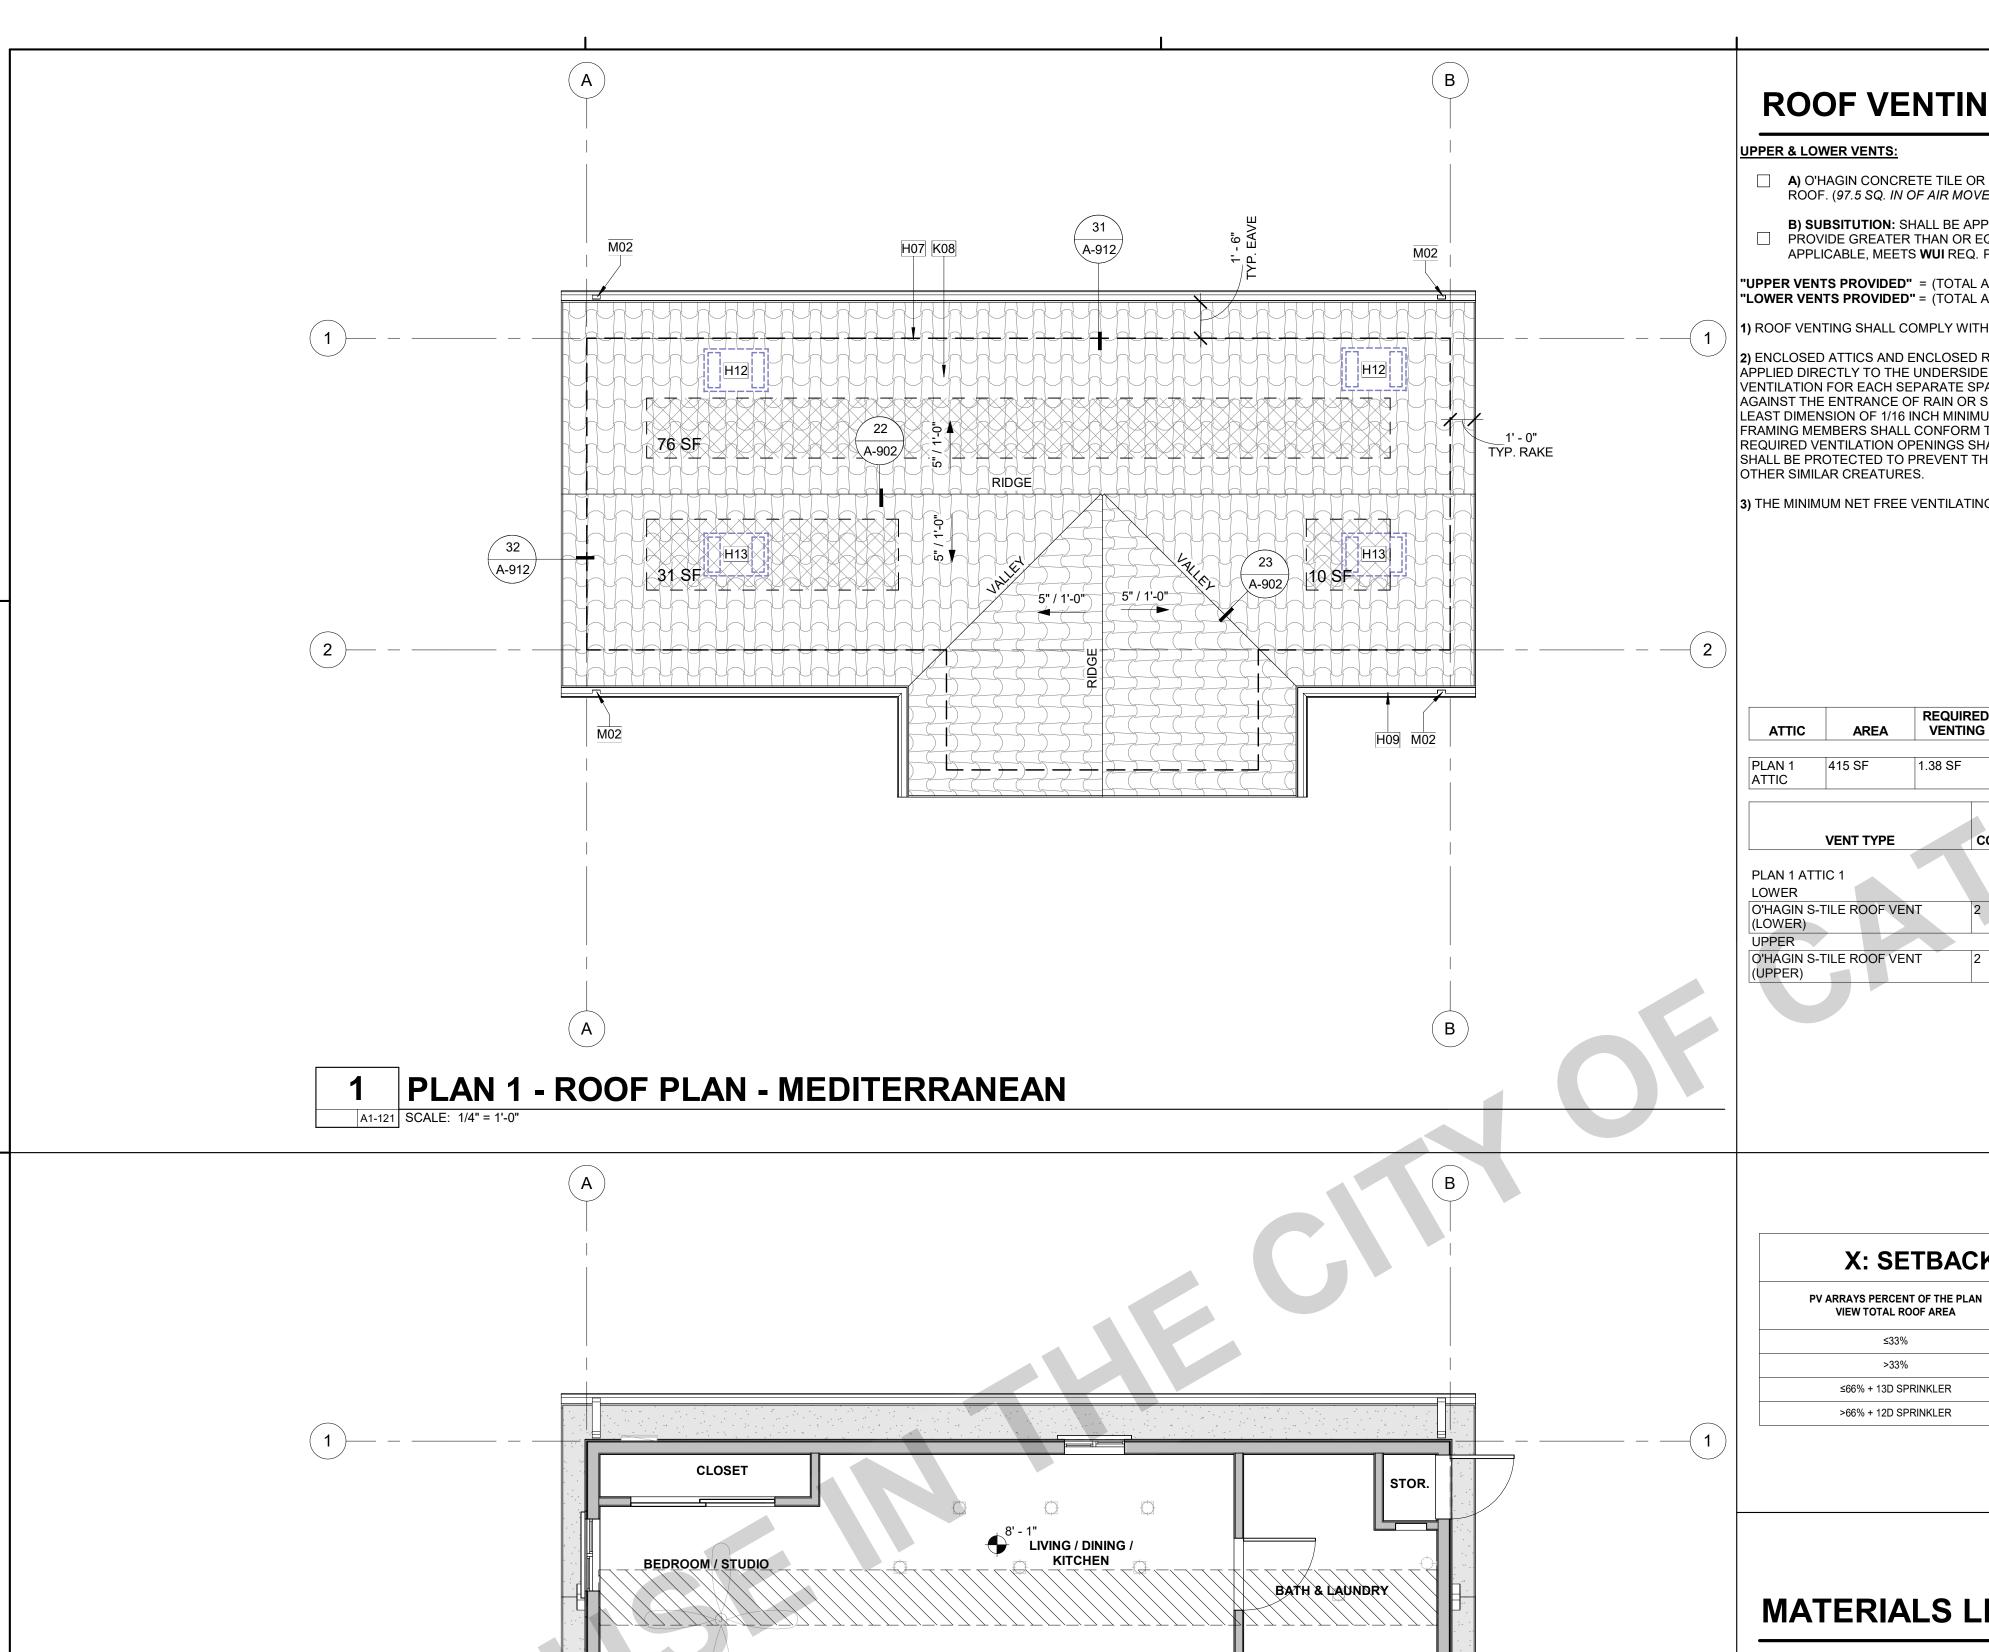

ROOF VENTING CALCULATION

UPPER & LOWER VENTS:

- A) O'HAGIN CONCRETE TILE OR CLAY TILE PROFILE (S) W/ FINISH TO MATCH ROOF. (97.5 SQ. IN OF AIR MOVEMENT PER VENT= 97.5 SQ.IN. / 144 = 0.68 SF)
- B) SUBSITUTION: SHALL BE APPROVED BY OWNER/APPLICANT; SHALL PROVIDE GREATER THAN OR EQUAL AIR MOVEMENT PER VENT. WHEN APPLICABLE, MEETS WUI REQ. PRODUCT LISTING:

"UPPER VENTS PROVIDED" = (TOTAL ATTIC AREA/300) * (0.5) / (0.5 SF) "LOWER VENTS PROVIDED" = (TOTAL ATTIC AREA/300) * (0.5) / (0.5 SF)

I) ROOF VENTING SHALL COMPLY WITH CRC R806 & CRC 337

2) ENCLOSED ATTICS AND ENCLOSED RAFTER SPACES FORMED WHERE CEILINGS ARE APPLIED DIRECTLY TO THE UNDERSIDE OF ROOF RAFTERS SHALL HAVE CROSS VENTILATION FOR EACH SEPARATE SPACE BY VENTILATING OPENINGS PROTECTED AGAINST THE ENTRANCE OF RAIN OR SNOW. VENTILATION OPENINGS SHALL HAVE A LEAST DIMENSION OF 1/16 INCH MINIMUM AND 1/4 INCH MAXIMUM. OPENINGS IN ROOF FRAMING MEMBERS SHALL CONFORM TO THE REQUIREMENTS OF SECTION R802.7. REQUIRED VENTILATION OPENINGS SHALL OPEN DIRECTLY TO THE OUTSIDE AIR AND SHALL BE PROTECTED TO PREVENT THE ENTRY OF BIRDS, RODENTS, SNAKES AND OTHER SIMILAR CREATURES.

3) THE MINIMUM NET FREE VENTILATING AREA SHALL COMPLY WITH CRC R806.2.

REQUIRED ATTIC UPPER VENTING LOWER VENTING VENTING (NFA) REQUIRED (NFA) REQUIRED (NFA) NET FREE PROVIDED AREA PER NET FREE **VENT TYPE** COUNT VENT LENGTH VENT AREA

O'HAGIN S-TILE ROOF VENT 2' - 8" 0.68 SF 1.35 SF O'HAGIN S-TILE ROOF VENT 1.35 SF 0.68 SF 2' - 8"

X: SETBACK AT RIDGE TABLE

2.71 SF

HORIZONTAL RIDGE SETBACK

18" BOTH SIDES OF RIDGE

36" BOTH SIDES OF RIDGE

18" BOTH SIDES OF RIDGE

36" BOTH SIDES OF RIDGE

ROOF PLAN GENERAL NOTES

- REFER TO GENERAL NOTES SHEET G-101 FOR ADDITIONAL REQUIREMENTS.
- INCLUDING MEMBER SIZES AND CONNECTION HARDWARE. PROVIDE A MINIMUM OF 1 INCH OF AIRSPACE BETWEEN THE INSULATION AND ROOF SHEATHING.

2. REFER TO STRUCTURAL PLANS FOR ROOF FRAMING INFORMATION

- 4. WHERE THE ROOF PROFILE ALLOWS A SPACE BETWEEN THE ROOF COVERING AND DECKING, THE SPACES SHALL BE CONSTRUCTED TO PREVENT THE INTRUSION OF FLAMES AND EMBERS, BE FIRESTOPPED WITH APPROVED MATERIALS OR HAVE ONE LAYER OF MINIMUM 72 POUND MINERAL-SURFACED NONPERFORATED CAP SHEET OVER THE COMBUSTIBLE DECKING.
- 5. ALL ROOFING MATERIALS TO BE INSTALLED PER MANUFACTURER'S SPECIFICATIONS.
- 6. OVERHANG DIMENSIONS ARE FROM FACE OF EXTERIOR WALL FRAMING TO
- ROOF COVERINGS SHALL BE APPLIED IN ACCORDANCE WITH (CRC R905), AND MANUFACTURER'S INSTALLATION INSTRUCTIONS. ROOF COVERINGS SHALL BE INSTALLED TO RESIST THE COMPONENT AND CLADDING LOADS SPECIFIED IN R301.2.1(1), AND ADJUSTED FOR HEIGHT AND EXPOSURE IN
- ACCORDANCE WITH TABLE R301.2.1(2). 8. ROOF UNDERLAYMENTS SHALL BE IN ACCORDANCE WITH WITH SECTION
- R905.1.1, TABLE R905.1.1(2), AND TABLE R905.1.1(1). ROOF VENTS SHALL BE APPLIED PER MANUFACTURER'S SPECIFICATIONS. FURNISHED DIMENSIONS FOR VENTS ARE GUIDES ONLY. INSTALL PER MANUFACTURERS SPECIFICATIONS AND ADJUST TO ACCOMMODATE TRUSS LOCATIONS, PLUMBING VENTS, AND SOLAR COLLECTORS. ENCLOSED ATTICS AND ENCLOSED RAFTER SPACES FORMED WHERE

CEILINGS ARE APPLIED DIRECTLY TO THE UNDERSIDE OF ROOF RAFTERS

SHALL HAVE CROSS VENTILATION FOR EACH SEPARATE SPACE BY

VENTILATING OPENINGS PROTECTED AGAINST THE ENTRANCE OF RAIN OR SNOW. VENTILATION OPENINGS SHALL HAVE A LEAST DIMENSION OF 1/16 INCH (1.6 MM) MINIMUM AND 1/4 INCH (6.4 MM) MAXIMUM. VENTILATION OPENINGS HAVING A LEAST DIMENSION LARGER THAN 1/4 INCH (6.4 MM) SHALL BE PROVIDED WITH CORROSION-RESISTANT WIRE CLOTH SCREENING, HARDWARE CLOTH, PERFORATED VINYL OR SIMILAR MATERIAL WITH OPENINGS HAVING A LEAST DIMENSION OF 1/16 INCH (1.6 MM) MINIMUM AND 1/4 INCH (6.4 MM) MAXIMUM. OPENINGS IN ROOF FRAMING MEMBERS SHALL CONFORM TO THE REQUIREMENTS OF SECTION R802.7. REQUIRED VENTILATION OPENINGS SHALL OPEN DIRECTLY TO THE OUTSIDE AIR AND

SNAKES AND OTHER SIMILAR CREATURES (CRC R806). 10. THE MINIMUM NET FREE VENTILATING AREA SHALL COMPLY WITH CRC

SHALL BE PROTECTED TO PREVENT THE ENTRY OF BIRDS, RODENTS,

11. IN THE INSTANCE OF UPPER VENTS, VENTS SHALL BE LOCATED NO MORE THAN 3 FT BELOW THE RIDGE OR HIGHEST POINT OF THE SPACE, MEASURED VERTICALLY. CRC R806.2.

RCP GENERAL NOTES

- REFER TO GENERAL NOTES SHEET G-102 FOR ADDITIONAL REQUIREMENTS. HEIGHT OF CEILINGS SHALL BE MEASURED FROM TOP OF SLAB OR FLOOR
- TO FINISH FACE OF GWB, U.N.O. REFER TO DETAILS FOR FLOOR/CEILING ASSEMBLIES.
- REFER TO ELECTRICAL PLANS FOR LIGHT FIXTURE AND EXHAUST
- DIMENSIONS ARE TO THE FACE OF FRAMING UNLESS OTHERWISE NOTED. 6. SOFFITS ARE TO BE HELD TIGHT TO UNDERSIDE OF MECHANICAL
- EQUIPMENT.

KEYNOTES

BUILDING LINE BELOW

- GUTTER. CONNECT TO DOWNSPOUT. PROVIDE MEANS TO PREVENT ACCUMULATION OF LEAVES AND DEBRIS IN GUTTER PER
- ATTIC VENT (LOW); LOWER VENTILATORS SHALL BE LOCATED IN THE BOTTOM ONE-THIRD OF THE ATTIC SPACE PER R806.2 EXCEPTION 2. PROVIDE DAMPER TO PROVIDE 1" CLR. AIRSPACE WHERE REQ. PAINT FINISH TO MATCH ROOF COLOR. SEE VENTING
- ATTIC VENT (HIGH): UPPER VENTILATORS SHALL BE LOCATED NOT MORE THAN 3 FEET BELOW THE RIDGE OR HIGHEST POINT OF THE SPACE, MEASURED VERTICALLY. PAINT FINISH TO MATCH ROOF
- COLOR, SEE VENTING CALCS. S-TYPE CLAY ROOF TILE, ROOF REFLECTANCE (0.1) MIN. ROOF EMITTANCE (0.85) MIN. SEE MATERIALS LEGEND FOR MORE
- DOWNSPOUT TO SPLASH BLOCK BELOW. SEE DETAIL 12/A-902.

MATERIALS LEGEND

OWNER/APP. TO PROVIDE MANUFACTURER, COLOR/FINISH SPECIFICATIONS

VIEW TOTAL ROOF AREA

>33%

≤66% + 13D SPRINKLER

>66% + 12D SPRINKLER

GRAPHICS LEGEND:

ROOFING; SEE G-001 FOR SELECTION & MATERIALS LEGEND ON ELEVATION SHEET FOR MORE INFORMATION.

S-TILE MASONRY ROOF TILE. ROOF REFLECTANCE (0.1) MIN. ROOF EMITTANCE (0.85) MIN. SEE MATERIALS LEGEND ON ELEVATION SHEET FOR MORE INFORMATION.

INTERIOR CEILING FINISH, TYP. 5/8" GYP. INSTALL PER MFR RECOMMENDATIONS

SEE G-001 FOR OPTION SELECTION: A) IMPROVED SOUND B) MOISTURE/MOLD/MILDEW-RESISTANT PERFORMANCE PRODUCTS.

NOTE: VISIT GYPSUM.ORG FOR MORE INFORMATION. **EXTERIOR SOFFITS, RAKES, & EAVES; SEE G-001 FOR MATERIAL**

SELECTION AND CORRESPONDING DETAILS FOR MORE INFORMATION. OPTIONS A & D) TOUNGE & GROOVED (SOLID SAWN LUMBER) **OPTIONS B & E) FIBER CEMENT**

OPTIONS C & F) EXT. GRADE FIRE RETARDANT TREATED SHEATHING

(LABEL SELECTION ON REFLECTED CEILING PLAN)

- 2. INSTALL ALL MATERIALS, FASTENERS, & COMPONENTS PER MANUFACTURER'S
- INSTALL ADDITIONAL BLOCKING AS NEEDED TO MEET ATTACHMENT

ROOF PLAN & RCP LEGEND

CEILING HEIGHT (SEE PLAN FOR ACTUAL HEIGHTS)

ROOF SLOPE (REFER TO PLANS FOR ACTUAL SLOPE)

22"X30" MIN. ATTIC ACCESS PANEL (WHERE REQ.)



CONCEALED ROOF VENT, SEE ROOF VENTING CALCULATIONS



 
OUTLINE OF WALL BELOW

GUTTER, CONNECT TO DOWNSPOUT; SEE DETAIL:



-APPROXIMATE LOCATION OF DOWNSPOUT/LEADER TO ROOF OR SPLASHBLOCK BELOW; SEE DETAILS:

NO PV REQUIRED PER T24 - POTENTIAL PV AREAS SHOWN



AREA OF ATTIC WITH 30" HEIGHT OR GREATER. 22" X 30" CLEAR OPENING ACCESS REQUIRED IF TOTAL AREA GREATER THAN 30 SQ. FT. PER CRC R807.1

ROOF DRAIN AND OVERFLOW; SEE DETAIL:

08/08/24 SHEET

SET

NOTES: 1. SOFFIT MATERIALS TO MEET REQ. OF CRC 337 & CRC 704. SPECIFICATIONS & RECOMMENDATIONS REQUIREMENTS PER CRC TABLE R702.3.5 3 PLAN 1 - GROUND FLOOR RCP - MEDITERRANEAN

CL

4 ATHEDR,

Cathedral City

THESE PLANS ARE PROVIDED BY THE CITY OF

CATHEDRAL CITY AS PART OF THE PRE-APPROVED

ADU PROGRAM AND ARE PUBLIC DOMAIN. THERE

CANNOT BE A CHARGE TO PROVIDE THESE PLANS.

ALTERATIONS MUST BE DONE UNDER A SEPARATE

PERMIT ONCE THE BUILDING PERMIT FOR THE ADU

CONSTRUCTION KNOWLEDGE AND EXPERIENCE TO

CONTRUCT THESE PLANS WITHOUT FURTHER DETAILS,

IT IS RECOMMENDED YOU HIRE A CONTRACTOR TO

DO THE CONSTRUCTION. THE CITY WILL NOT PROVIDE

FURTHER INFORMATION OR DETAILS AND BUILDING


INSPECTORS WILL NOT PROVIDE STEP BY STEP

HAS BEEN ISSUED AND FINAL INSPECTION

COMPLETED. IF YOU DO NOT HAVE THE

INSTRUCTIONS IN THE FIELD.

NO ALTERATIONS TO THESE PLANS ARE ALLOWED. ALI

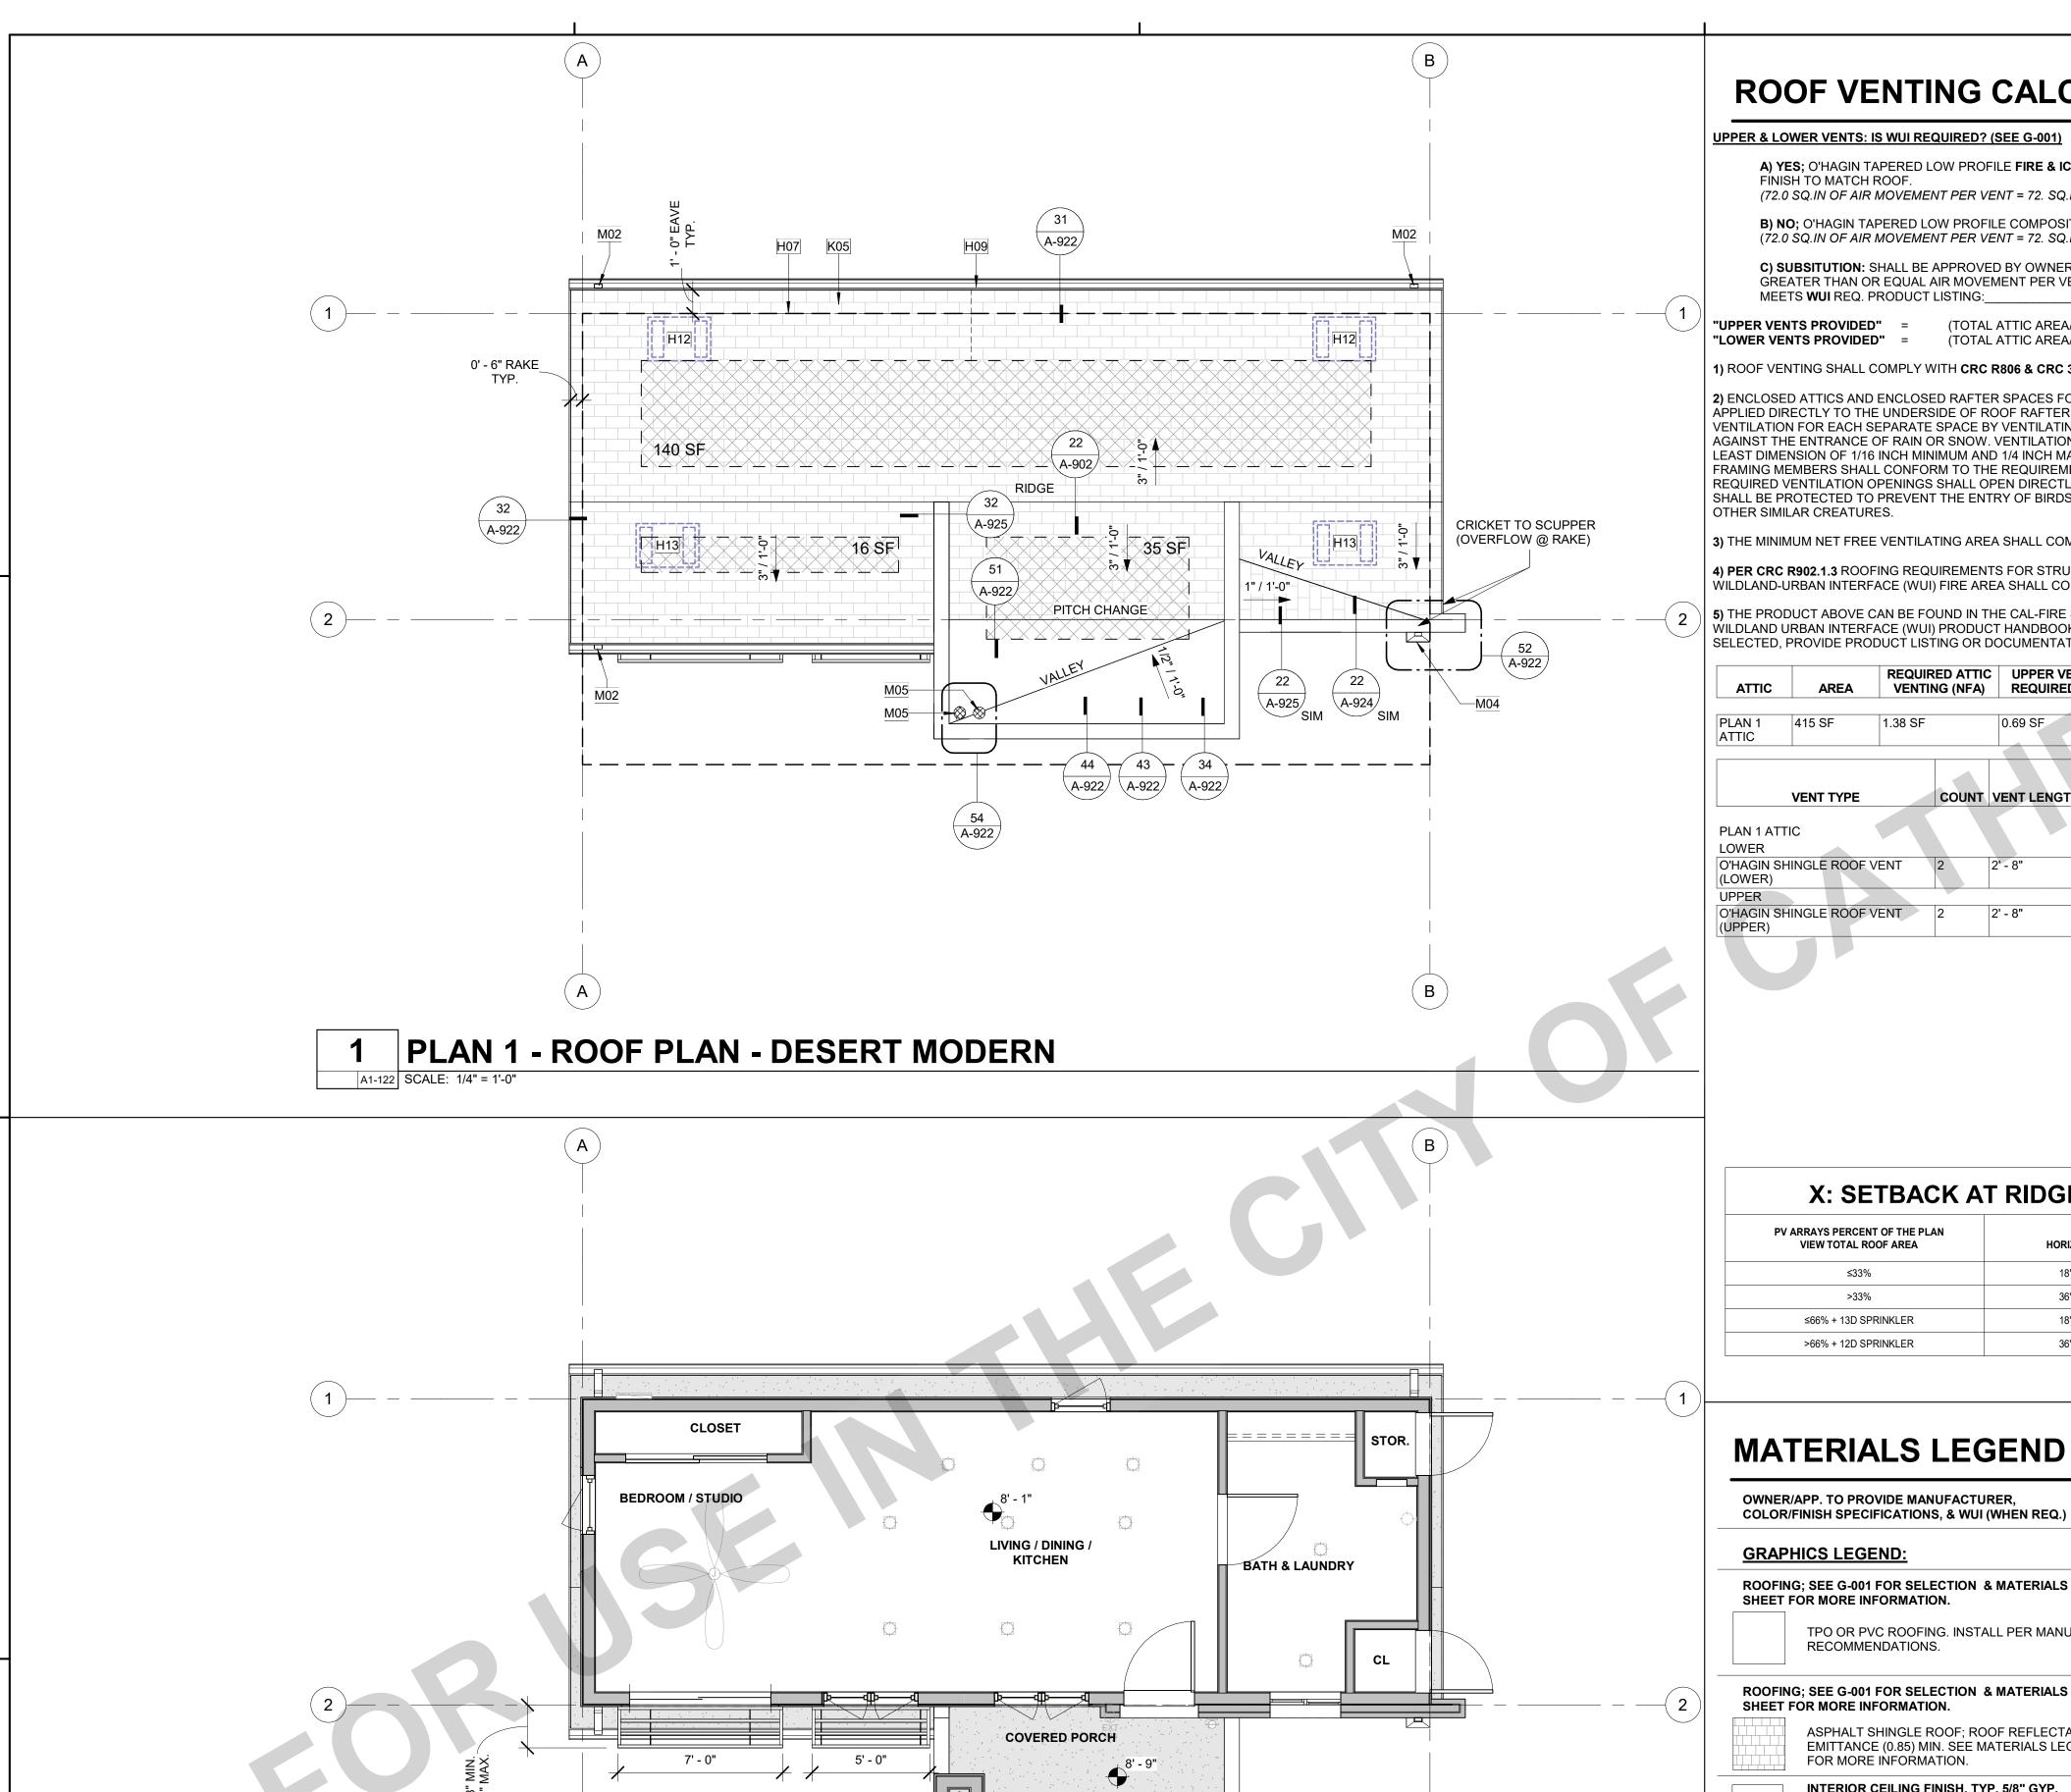

ROOF VENTING CALCULATION

UPPER & LOWER VENTS: IS WUI REQUIRED? (SEE G-001)

A) YES; O'HAGIN TAPERED LOW PROFILE FIRE & ICE COMPOSITION SHINGLE FINISH TO MATCH ROOF.

(72.0 SQ.IN OF AIR MOVEMENT PER VENT = 72. SQ.IN. / 144 = 0.5 SF)

B) NO; O'HAGIN TAPERED LOW PROFILE COMPOSITION SHINGLE. (72.0 SQ.IN OF AIR MOVEMENT PER VENT = 72. SQ.IN. / 144 = 0.5 SF)

C) SUBSITUTION: SHALL BE APPROVED BY OWNER/APPLICANT; SHALL PROVIDE GREATER THAN OR EQUAL AIR MOVEMENT PER VENT. WHEN APPLICABLE,

"UPPER VENTS PROVIDED" = (TOTAL ATTIC AREA/300) * (0.5) / (0.5 SF) (TOTAL ATTIC AREA/300) * (0.5) / (0.5 SF)

1) ROOF VENTING SHALL COMPLY WITH CRC R806 & CRC 337.

2) ENCLOSED ATTICS AND ENCLOSED RAFTER SPACES FORMED WHERE CEILINGS ARE APPLIED DIRECTLY TO THE UNDERSIDE OF ROOF RAFTERS SHALL HAVE CROSS VENTILATION FOR EACH SEPARATE SPACE BY VENTILATING OPENINGS PROTECTED AGAINST THE ENTRANCE OF RAIN OR SNOW. VENTILATION OPENINGS SHALL HAVE A LEAST DIMENSION OF 1/16 INCH MINIMUM AND 1/4 INCH MAXIMUM. OPENINGS IN ROOF FRAMING MEMBERS SHALL CONFORM TO THE REQUIREMENTS OF SECTION R802.7. REQUIRED VENTILATION OPENINGS SHALL OPEN DIRECTLY TO THE OUTSIDE AIR AND SHALL BE PROTECTED TO PREVENT THE ENTRY OF BIRDS, RODENTS, SNAKES AND OTHER SIMILAR CREATURES.

3) THE MINIMUM NET FREE VENTILATING AREA SHALL COMPLY WITH CRC R806.2.

4) PER CRC R902.1.3 ROOFING REQUIREMENTS FOR STRUCTURES LOCATED IN A WILDLAND-URBAN INTERFACE (WUI) FIRE AREA SHALL COMPLY WITH SECTION R337.5.

5) THE PRODUCT ABOVE CAN BE FOUND IN THE CAL-FIRE STATE FIRE MARSHAL LISTED WILDLAND URBAN INTERFACE (WUI) PRODUCT HANDBOOK. IF ALTERNATIVE PRODUCT SELECTED, PROVIDE PRODUCT LISTING OR DOCUMENTATION TO VERIFY COMPLIANCE.

ATTIC	AREA		RED ATTIC NG (NFA)	UPPER VEN			R VENTING IRED (NFA)
PLAN 1 ATTIC	415 SF	1.38 SF		0.69 SF		0.69 SF	
	•	•					
	VENT TYPE		COUNT	VENT LENGTH	ARE	FREE A PER ENT	PROVIDED NET FREE AREA
PLAN 1 ATT	10						
	IC						
LOWER							
O'HAGIN SH (LOWER)	HINGLE ROOF V	ENT	2	2' - 8"	0.50 S	F	1.00 SF
UPPER							
O'HAGIN SI (UPPER)	HINGLE ROOF V	ENT	2	2' - 8"	0.50 S	F	1.00 SF
					'		2.00 SF

X: SETBACK AT RIDGE TABLE

HORIZONTAL RIDGE SETBACK

18" BOTH SIDES OF RIDGE

36" BOTH SIDES OF RIDGE

18" BOTH SIDES OF RIDGE

36" BOTH SIDES OF RIDGE

ROOF PLAN GENERAL NOTES

- REFER TO GENERAL NOTES SHEET G-101 FOR ADDITIONAL REQUIREMENTS. 2. REFER TO STRUCTURAL PLANS FOR ROOF FRAMING INFORMATION INCLUDING MEMBER SIZES AND CONNECTION HARDWARE.
- PROVIDE A MINIMUM OF 1 INCH OF AIRSPACE BETWEEN THE INSULATION AND ROOF SHEATHING.
- 4. WHERE THE ROOF PROFILE ALLOWS A SPACE BETWEEN THE ROOF COVERING AND DECKING, THE SPACES SHALL BE CONSTRUCTED TO PREVENT THE INTRUSION OF FLAMES AND EMBERS, BE FIRESTOPPED WITH APPROVED MATERIALS OR HAVE ONE LAYER OF MINIMUM 72 POUND MINERAL-SURFACED NONPERFORATED CAP SHEET OVER THE COMBUSTIBLE DECKING.
- 5. ALL ROOFING MATERIALS TO BE INSTALLED PER MANUFACTURER'S SPECIFICATIONS.
- 6. OVERHANG DIMENSIONS ARE FROM FACE OF EXTERIOR WALL FRAMING TO
- ROOF EDGE. ROOF COVERINGS SHALL BE APPLIED IN ACCORDANCE WITH (CRC R905), AND MANUFACTURER'S INSTALLATION INSTRUCTIONS. ROOF COVERINGS SHALL BE INSTALLED TO RESIST THE COMPONENT AND CLADDING LOADS SPECIFIED IN R301.2.1(1), AND ADJUSTED FOR HEIGHT AND EXPOSURE IN
- ACCORDANCE WITH TABLE R301.2.1(2). ROOF UNDERLAYMENTS SHALL BE IN ACCORDANCE WITH WITH SECTION
- R905.1.1, TABLE R905.1.1(2), AND TABLE R905.1.1(1). ROOF VENTS SHALL BE APPLIED PER MANUFACTURER'S SPECIFICATIONS. FURNISHED DIMENSIONS FOR VENTS ARE GUIDES ONLY. INSTALL PER MANUFACTURERS SPECIFICATIONS AND ADJUST TO ACCOMMODATE TRUSS LOCATIONS, PLUMBING VENTS, AND SOLAR COLLECTORS. ENCLOSED ATTICS AND ENCLOSED RAFTER SPACES FORMED WHERE CEILINGS ARE APPLIED DIRECTLY TO THE UNDERSIDE OF ROOF RAFTERS SHALL HAVE CROSS VENTILATION FOR EACH SEPARATE SPACE BY

VENTILATING OPENINGS PROTECTED AGAINST THE ENTRANCE OF RAIN OR

SNOW. VENTILATION OPENINGS SHALL HAVE A LEAST DIMENSION OF 1/16 INCH (1.6 MM) MINIMUM AND 1/4 INCH (6.4 MM) MAXIMUM. VENTILATION OPENINGS HAVING A LEAST DIMENSION LARGER THAN 1/4 INCH (6.4 MM) SHALL BE PROVIDED WITH CORROSION-RESISTANT WIRE CLOTH SCREENING, HARDWARE CLOTH, PERFORATED VINYL OR SIMILAR MATERIAL WITH OPENINGS HAVING A LEAST DIMENSION OF 1/16 INCH (1.6 MM) MINIMUM AND 1/4 INCH (6.4 MM) MAXIMUM. OPENINGS IN ROOF FRAMING MEMBERS SHALL CONFORM TO THE REQUIREMENTS OF SECTION R802.7. REQUIRED VENTILATION OPENINGS SHALL OPEN DIRECTLY TO THE OUTSIDE AIR AND

SNAKES AND OTHER SIMILAR CREATURES (CRC R806). 10. THE MINIMUM NET FREE VENTILATING AREA SHALL COMPLY WITH CRC

SHALL BE PROTECTED TO PREVENT THE ENTRY OF BIRDS, RODENTS,

11. IN THE INSTANCE OF UPPER VENTS, VENTS SHALL BE LOCATED NO MORE THAN 3 FT BELOW THE RIDGE OR HIGHEST POINT OF THE SPACE, MEASURED VERTICALLY. CRC R806.2.

RCP GENERAL NOTES

- REFER TO GENERAL NOTES SHEET G-102 FOR ADDITIONAL REQUIREMENTS. 2. HEIGHT OF CEILINGS SHALL BE MEASURED FROM TOP OF SLAB OR FLOOR TO FINISH FACE OF GWB, U.N.O.
- REFER TO DETAILS FOR FLOOR/CEILING ASSEMBLIES.
- 4. REFER TO ELECTRICAL PLANS FOR LIGHT FIXTURE AND EXHAUST
- DIMENSIONS ARE TO THE FACE OF FRAMING UNLESS OTHERWISE NOTED. 6. SOFFITS ARE TO BE HELD TIGHT TO UNDERSIDE OF MECHANICAL

KEYNOTES

EQUIPMENT.

BUILDING LINE BELOW. GUTTER. CONNECT TO DOWNSPOUT, PROVIDE MEANS TO PREVENT ACCUMULATION OF LEAVES AND DEBRIS IN GUTTER PER CRC R327.5.4 ATTIC VENT (LOW); LOWER VENTILATORS SHALL BE LOCATED IN THE BOTTOM ONE-THIRD OF THE ATTIC SPACE PER R806.2 EXCEPTION 2. PROVIDE DAMPER TO PROVIDE 1" CLR. AIRSPACE

> WHERE REQ. PAINT FINISH TO MATCH ROOF COLOR, SEE VENTING ATTIC VENT (HIGH); UPPER VENTILATORS SHALL BE LOCATED NOT MORE THAN 3 FEET BELOW THE RIDGE OR HIGHEST POINT OF THE SPACE, MEASURED VERTICALLY. PAINT FINISH TO MATCH ROOF

COLOR, SEE VENTING CALCS. COMPOSITE ROOF SHINGLES, ROOF REFLECTANCE (0.1) MIN. ROOF

EMITTANCE (0.85) MIN. SEE MATERIALS LEGEND FOR MORE

DOWNSPOUT TO SPLASH BLOCK BELOW. SEE DETAIL 12/A-902. OVERFLOW SCUPPER. 4" x 10" OPENING PER 2016 CPC 1101.12.2.1. COMBINATION ROOF DRAIN WITH OVERFLOW TO CONCEALED LEADERS THAT DAYLIGHT AT BASE OF EXTERIOR. STRAINER DOME REQUIRED. COW TOUNGE AND SPLASH BLOCK PER OWNER/APPLICANT. TIE INTO SITE DRAINAGE. SEE DETAIL 54/A-922 THEDR.

Cathedral City

THESE PLANS ARE PROVIDED BY THE CITY OF

CATHEDRAL CITY AS PART OF THE PRE-APPROVED

ADU PROGRAM AND ARE PUBLIC DOMAIN. THERE

CANNOT BE A CHARGE TO PROVIDE THESE PLANS.

ALTERATIONS MUST BE DONE UNDER A SEPARATE

PERMIT ONCE THE BUILDING PERMIT FOR THE ADU

CONSTRUCTION KNOWLEDGE AND EXPERIENCE TO

CONTRUCT THESE PLANS WITHOUT FURTHER DETAILS,

IT IS RECOMMENDED YOU HIRE A CONTRACTOR TO

DO THE CONSTRUCTION. THE CITY WILL NOT PROVIDE

FURTHER INFORMATION OR DETAILS AND BUILDING

INSPECTORS WILL NOT PROVIDE STEP BY STEP

HAS BEEN ISSUED AND FINAL INSPECTION

COMPLETED. IF YOU DO NOT HAVE THE

INSTRUCTIONS IN THE FIELD.

NO ALTERATIONS TO THESE PLANS ARE ALLOWED. ALL

APPROXIMATE LOCATION OF DOWNSPOUT/LEADER TO ROOF OR SPLASHBLOCK BELOW; SEE DETAILS:

 $\otimes \otimes$ ROOF DRAIN AND OVERFLOW; SEE DETAIL:

AREA OF ATTIC WITH 30" HEIGHT OR GREATER. 22" X 30" CLEAR OPENING ACCESS REQUIRED IF TOTAL AREA GREATER THAN 30 SQ. FT. PER CRC R807.1

NO PV REQUIRED PER T24 - POTENTIAL PV AREAS SHOWN

SHEET

08/08/24

ROOF PLAN & RCP LEGEND

	CEILING HEIGHT (SEE PLAN FOR ACTUAL HEIGHTS)
X:12	ROOF SLOPE (REFER TO PLANS FOR ACTUAL SLOPE)
	22"X30" MIN. ATTIC ACCESS PANEL (WHERE REQ.)
	CONCEALED ROOF VENT, SEE ROOF VENTING CALCULATI
	OUTLINE OF WALL BELOW
	GUTTER, CONNECT TO DOWNSPOUT; SEE DETAIL:

3 PLAN 1 GROUND FLOOR RCP - DESERT MODERN

SEE G-001 FOR OPTION SELECTION: A) IMPROVED SOUND

EXTERIOR SOFFITS, RAKES, & EAVES; SEE G-001 FOR MATERIAL

OPTIONS A & D) TOUNGE & GROOVED (SOLID SAWN LUMBER) OPTIONS B & E) FIBER CEMENT OPTIONS C & F) EXT. GRADE FIRE RETARDANT TREATED

 SOFFIT MATERIALS TO MEET REQ. OF CRC 337 & CRC 704. 2. INSTALL ALL MATERIALS, FASTENERS, & COMPONENTS PER MANUFACTURER'S

. INSTALL ADDITIONAL BLOCKING AS NEEDED TO MEET ATTACHMENT REQUIREMENTS PER CRC TABLE R702.3.5

ROOFING; SEE G-001 FOR SELECTION & MATERIALS LEGEND ON ELEVATION SHEET FOR MORE INFORMATION. TPO OR PVC ROOFING. INSTALL PER MANUFACTUERERS RECOMMENDATIONS.

PV ARRAYS PERCENT OF THE PLAN

VIEW TOTAL ROOF AREA

>33%

≤66% + 13D SPRINKLER

>66% + 12D SPRINKLER

ROOFING; SEE G-001 FOR SELECTION & MATERIALS LEGEND ON ELEVATION

SHEET FOR MORE INFORMATION. ASPHALT SHINGLE ROOF; ROOF REFLECTANCE (0.1) MIN. ROOF EMITTANCE (0.85) MIN. SEE MATERIALS LEGEND ON ELEVATION SHEET FOR MORE INFORMATION.


> INTERIOR CEILING FINISH, TYP. 5/8" GYP. INSTALL PER MFR RECOMMENDATIONS

B) MOISTURE/MOLD/MILDEW-RESISTANT PERFORMANCE PRODUCTS. **NOTE:** VISIT GYPSUM.ORG FOR MORE INFORMATION.

SELECTION AND CORRESPONDING DETAILS FOR MORE INFORMATION.

SHEATHING (LABEL SELECTION ON REFLECTED CEILING PLAN)

SPECIFICATIONS & RECOMMENDATIONS

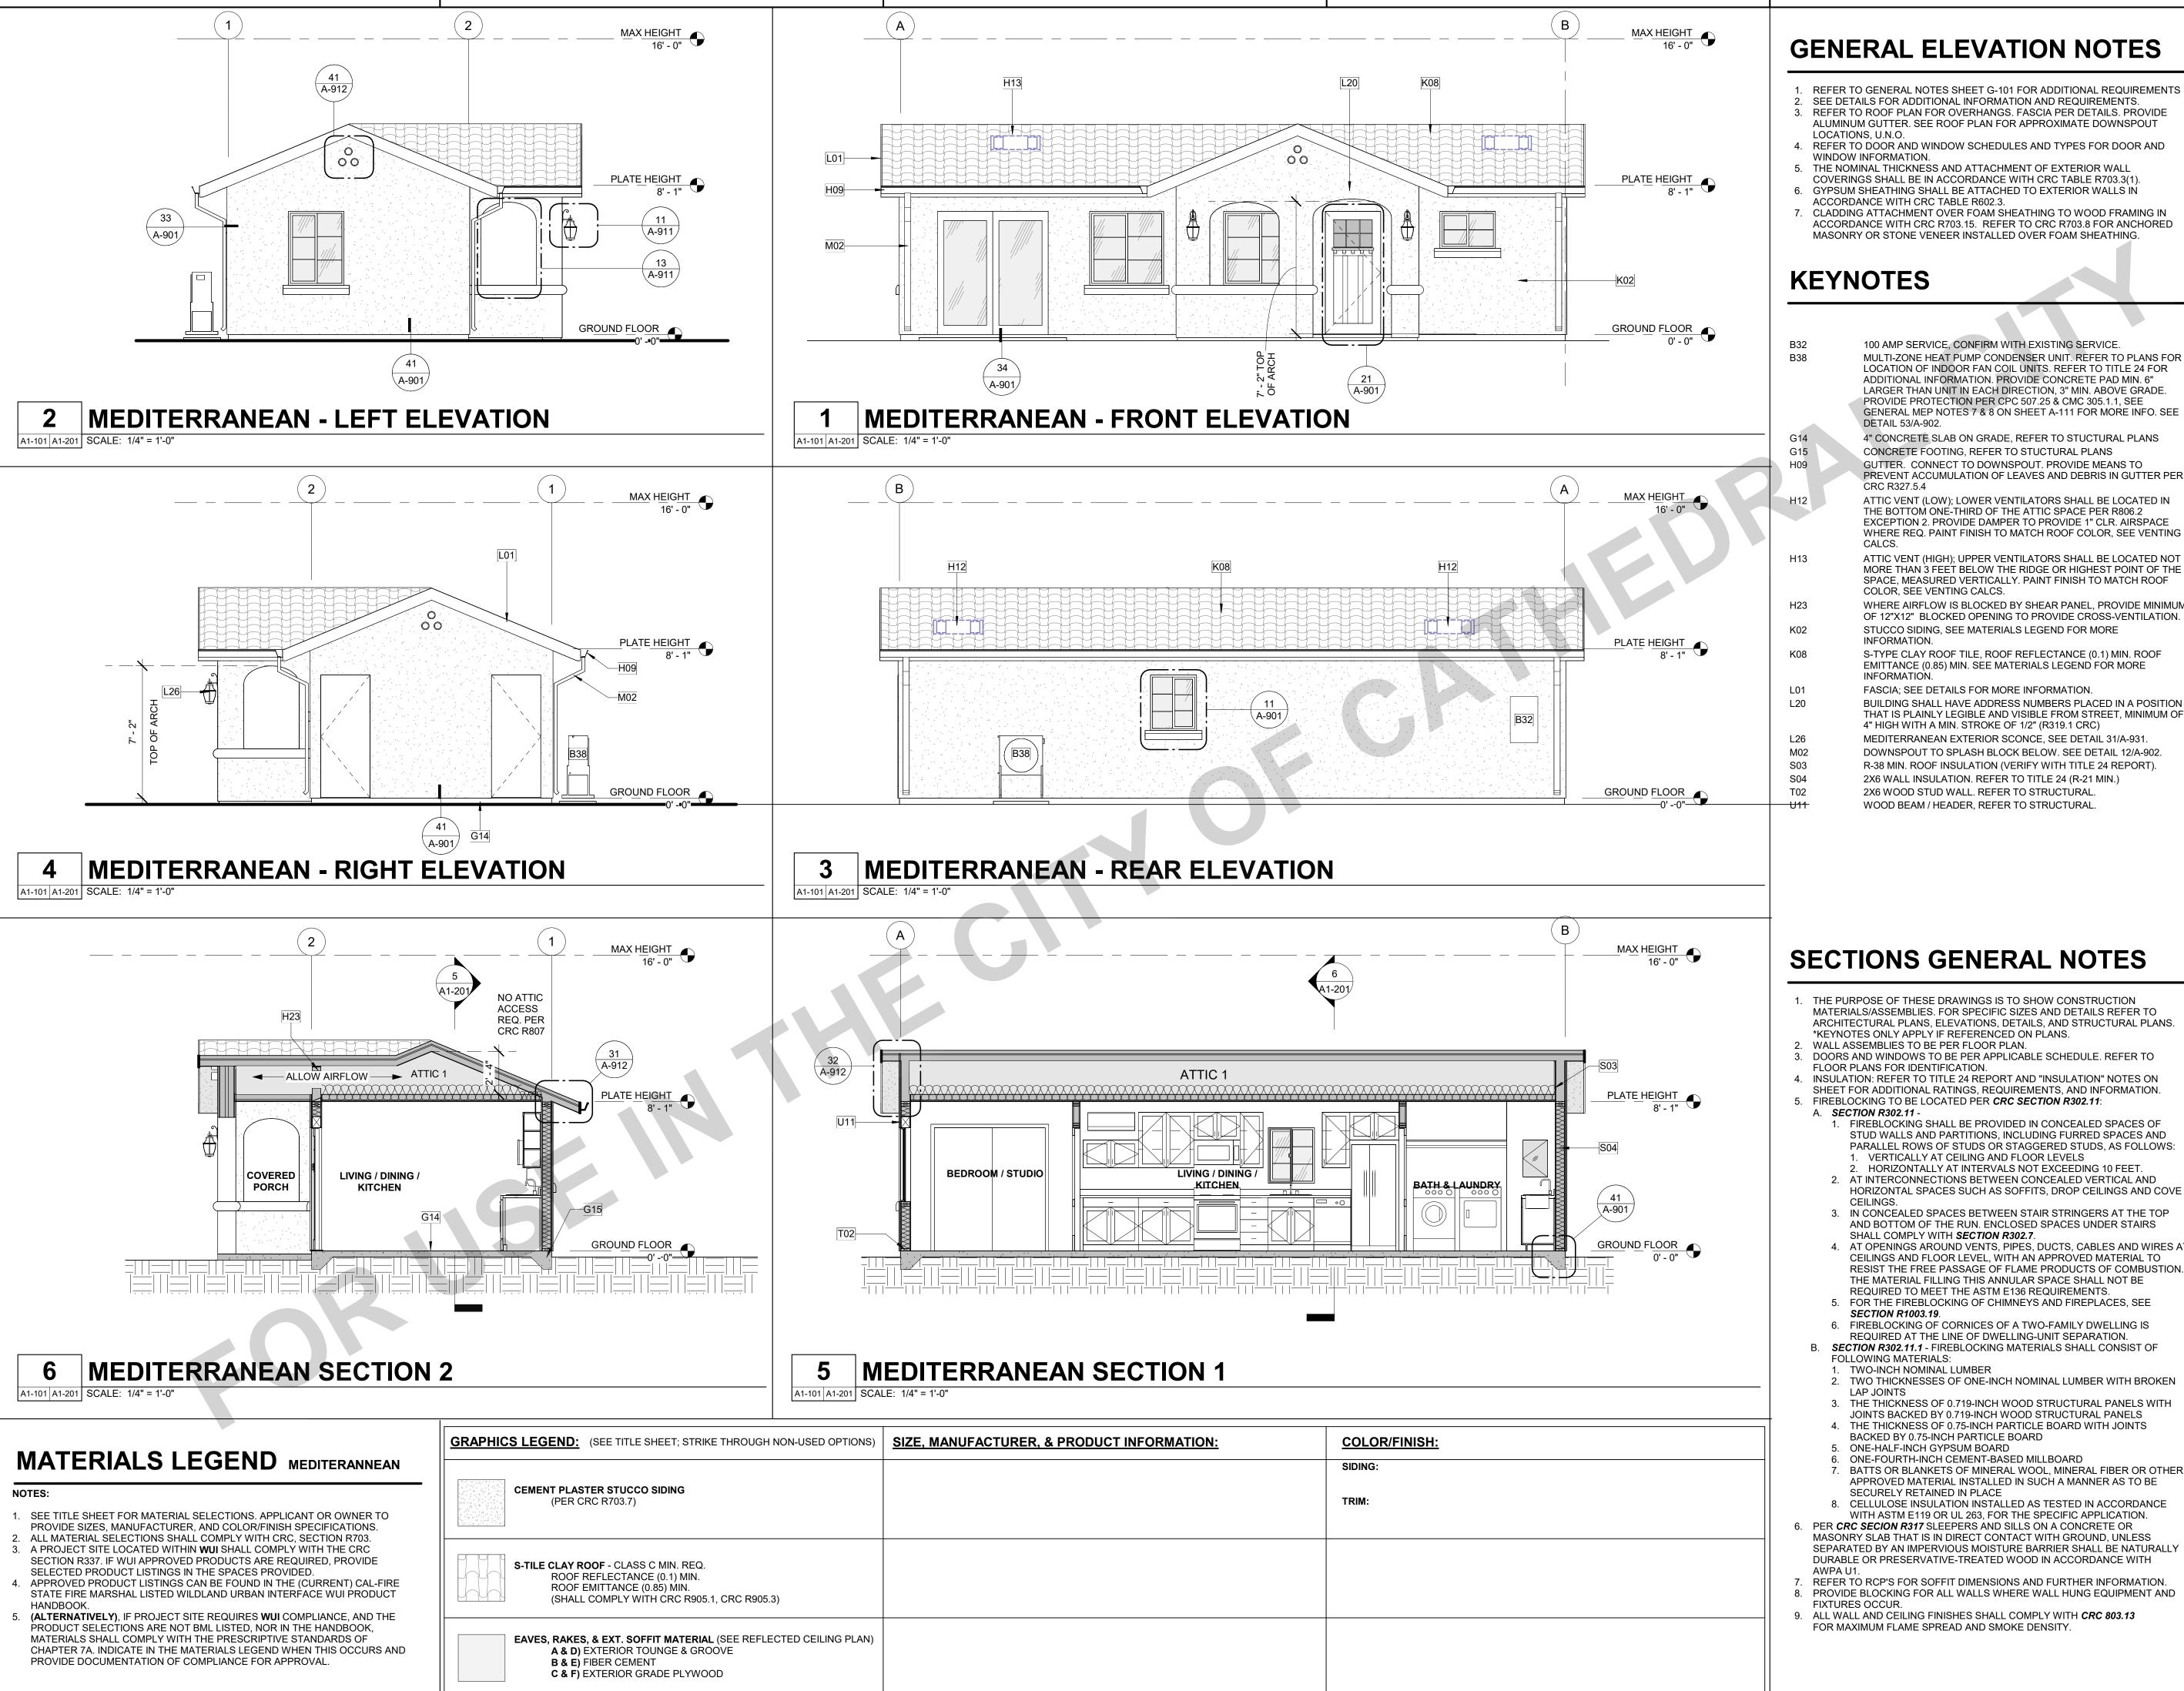

GENERAL ELEVATION NOTES

- REFER TO GENERAL NOTES SHEET G-101 FOR ADDITIONAL REQUIREMENTS 2. SEE DETAILS FOR ADDITIONAL INFORMATION AND REQUIREMENTS. REFER TO ROOF PLAN FOR OVERHANGS. FASCIA PER DETAILS. PROVIDE ALUMINUM GUTTER. SEE ROOF PLAN FOR APPROXIMATE DOWNSPOUT
- 4. REFER TO DOOR AND WINDOW SCHEDULES AND TYPES FOR DOOR AND WINDOW INFORMATION.
- 5. THE NOMINAL THICKNESS AND ATTACHMENT OF EXTERIOR WALL
- COVERINGS SHALL BE IN ACCORDANCE WITH CRC TABLE R703.3(1). GYPSUM SHEATHING SHALL BE ATTACHED TO EXTERIOR WALLS IN
- CLADDING ATTACHMENT OVER FOAM SHEATHING TO WOOD FRAMING IN ACCORDANCE WITH CRC R703.15. REFER TO CRC R703.8 FOR ANCHORED MASONRY OR STONE VENEER INSTALLED OVER FOAM SHEATHING

KEYNOTES

- 100 AMP SERVICE, CONFIRM WITH EXISTING SERVICE. MULTI-ZONE HEAT PUMP CONDENSER UNIT. REFER TO PLANS FOR LOCATION OF INDOOR FAN COIL UNITS. REFER TO TITLE 24 FOR ADDITIONAL INFORMATION. PROVIDE CONCRETE PAD MIN. 6" LARGER THAN UNIT IN EACH DIRECTION, 3" MIN. ABOVE GRADE. PROVIDE PROTECTION PER CPC 507.25 & CMC 305.1.1, SEE GENERAL MEP NOTES 7 & 8 ON SHEET A-111 FOR MORE INFO. SEE DETAIL 53/A-902.
- 4" CONCRETE SLAB ON GRADE, REFER TO STUCTURAL PLANS CONCRETE FOOTING, REFER TO STUCTURAL PLANS GUTTER. CONNECT TO DOWNSPOUT. PROVIDE MEANS TO PREVENT ACCUMULATION OF LEAVES AND DEBRIS IN GUTTER PER
- THE BOTTOM ONE-THIRD OF THE ATTIC SPACE PER R806.2 EXCEPTION 2. PROVIDE DAMPER TO PROVIDE 1" CLR. AIRSPACE WHERE REQ. PAINT FINISH TO MATCH ROOF COLOR, SEE VENTING ATTIC VENT (HIGH); UPPER VENTILATORS SHALL BE LOCATED NOT
- MORE THAN 3 FEET BELOW THE RIDGE OR HIGHEST POINT OF THE SPACE, MEASURED VERTICALLY. PAINT FINISH TO MATCH ROOF COLOR, SEE VENTING CALCS. WHERE AIRFLOW IS BLOCKED BY SHEAR PANEL, PROVIDE MINIMUM
- STUCCO SIDING, SEE MATERIALS LEGEND FOR MORE INFORMATION. S-TYPE CLAY ROOF TILE, ROOF REFLECTANCE (0.1) MIN. ROOF
- EMITTANCE (0.85) MIN. SEE MATERIALS LEGEND FOR MORE INFORMATION. FASCIA; SEE DETAILS FOR MORE INFORMATION. BUILDING SHALL HAVE ADDRESS NUMBERS PLACED IN A POSITION
- THAT IS PLAINLY LEGIBLE AND VISIBLE FROM STREET, MINIMUM OF 4" HIGH WITH A MIN. STROKE OF 1/2" (R319.1 CRC) MEDITERRANEAN EXTERIOR SCONCE, SEE DETAIL 31/A-931 DOWNSPOUT TO SPLASH BLOCK BELOW. SEE DETAIL 12/A-902. R-38 MIN. ROOF INSULATION (VERIFY WITH TITLE 24 REPORT). 2X6 WALL INSULATION. REFER TO TITLE 24 (R-21 MIN.)

SECTIONS GENERAL NOTES

- 1. THE PURPOSE OF THESE DRAWINGS IS TO SHOW CONSTRUCTION MATERIALS/ASSEMBLIES. FOR SPECIFIC SIZES AND DETAILS REFER TO ARCHITECTURAL PLANS, ELEVATIONS, DETAILS, AND STRUCTURAL PLANS.
- WALL ASSEMBLIES TO BE PER FLOOR PLAN. DOORS AND WINDOWS TO BE PER APPLICABLE SCHEDULE. REFER TO
- FLOOR PLANS FOR IDENTIFICATION. INSULATION: REFER TO TITLE 24 REPORT AND "INSULATION" NOTES ON
- SHEET FOR ADDITIONAL RATINGS, REQUIREMENTS, AND INFORMATION. 5. FIREBLOCKING TO BE LOCATED PER *CRC SECTION R302.11*:
- FIREBLOCKING SHALL BE PROVIDED IN CONCEALED SPACES OF STUD WALLS AND PARTITIONS, INCLUDING FURRED SPACES AND PARALLEL ROWS OF STUDS OR STAGGERED STUDS, AS FOLLOWS: VERTICALLY AT CEILING AND FLOOR LEVELS
- HORIZONTALLY AT INTERVALS NOT EXCEEDING 10 FEET. 2. AT INTERCONNECTIONS BETWEEN CONCEALED VERTICAL AND HORIZONTAL SPACES SUCH AS SOFFITS, DROP CEILINGS AND COVE
- 3. IN CONCEALED SPACES BETWEEN STAIR STRINGERS AT THE TOP AND BOTTOM OF THE RUN. ENCLOSED SPACES UNDER STAIRS SHALL COMPLY WITH SECTION R302.7.
- 4. AT OPENINGS AROUND VENTS, PIPES, DUCTS, CABLES AND WIRES AT CEILINGS AND FLOOR LEVEL, WITH AN APPROVED MATERIAL TO RESIST THE FREE PASSAGE OF FLAME PRODUCTS OF COMBUSTION. THE MATERIAL FILLING THIS ANNULAR SPACE SHALL NOT BE REQUIRED TO MEET THE ASTM E136 REQUIREMENTS.
- FOR THE FIREBLOCKING OF CHIMNEYS AND FIREPLACES, SEE **SECTION R1003.19**.
- FIREBLOCKING OF CORNICES OF A TWO-FAMILY DWELLING IS
- REQUIRED AT THE LINE OF DWELLING-UNIT SEPARATION. SECTION R302.11.1 - FIREBLOCKING MATERIALS SHALL CONSIST OF
- TWO-INCH NOMINAL LUMBER
- 2. TWO THICKNESSES OF ONE-INCH NOMINAL LUMBER WITH BROKEN
- 3. THE THICKNESS OF 0.719-INCH WOOD STRUCTURAL PANELS WITH
- JOINTS BACKED BY 0.719-INCH WOOD STRUCTURAL PANELS THE THICKNESS OF 0.75-INCH PARTICLE BOARD WITH JOINTS
- BACKED BY 0.75-INCH PARTICLE BOARD
- ONE-HALF-INCH GYPSUM BOARD 6. ONE-FOURTH-INCH CEMENT-BASED MILLBOARD
- BATTS OR BLANKETS OF MINERAL WOOL, MINERAL FIBER OR OTHER APPROVED MATERIAL INSTALLED IN SUCH A MANNER AS TO BE SECURELY RETAINED IN PLACE
- 8. CELLULOSE INSULATION INSTALLED AS TESTED IN ACCORDANCE WITH ASTM E119 OR UL 263, FOR THE SPECIFIC APPLICATION. PER CRC SECION R317 SLEEPERS AND SILLS ON A CONCRETE OR SEPARATED BY AN IMPERVIOUS MOISTURE BARRIER SHALL BE NATURALLY
- REFER TO RCP'S FOR SOFFIT DIMENSIONS AND FURTHER INFORMATION. PROVIDE BLOCKING FOR ALL WALLS WHERE WALL HUNG EQUIPMENT AND
- ALL WALL AND CEILING FINISHES SHALL COMPLY WITH CRC 803.13 FOR MAXIMUM FLAME SPREAD AND SMOKE DENSITY

Cathedral City

HESE PLANS ARE PROVIDED BY THE CITY OF CATHEDRAL CITY AS PART OF THE PRE-APPROVED ADU PROGRAM AND ARE PUBLIC DOMAIN. THERE CANNOT BE A CHARGE TO PROVIDE THESE PLANS. NO ALTERATIONS TO THESE PLANS ARE ALLOWED. ALI ALTERATIONS MUST BE DONE UNDER A SEPARATE PERMIT ONCE THE BUILDING PERMIT FOR THE ADU HAS BEEN ISSUED AND FINAL INSPECTION COMPLETED. IF YOU DO NOT HAVE THE CONSTRUCTION KNOWLEDGE AND EXPERIENCE TO CONTRUCT THESE PLANS WITHOUT FURTHER DETAILS, IT IS RECOMMENDED YOU HIRE A CONTRACTOR TO DO THE CONSTRUCTION. THE CITY WILL NOT PROVIDE FURTHER INFORMATION OR DETAILS AND BUILDING INSPECTORS WILL NOT PROVIDE STEP BY STEP INSTRUCTIONS IN THE FIELD.

BUILDING

ADU


ATHEDR/

U

08/08/24 SHEET

SE

A1-201

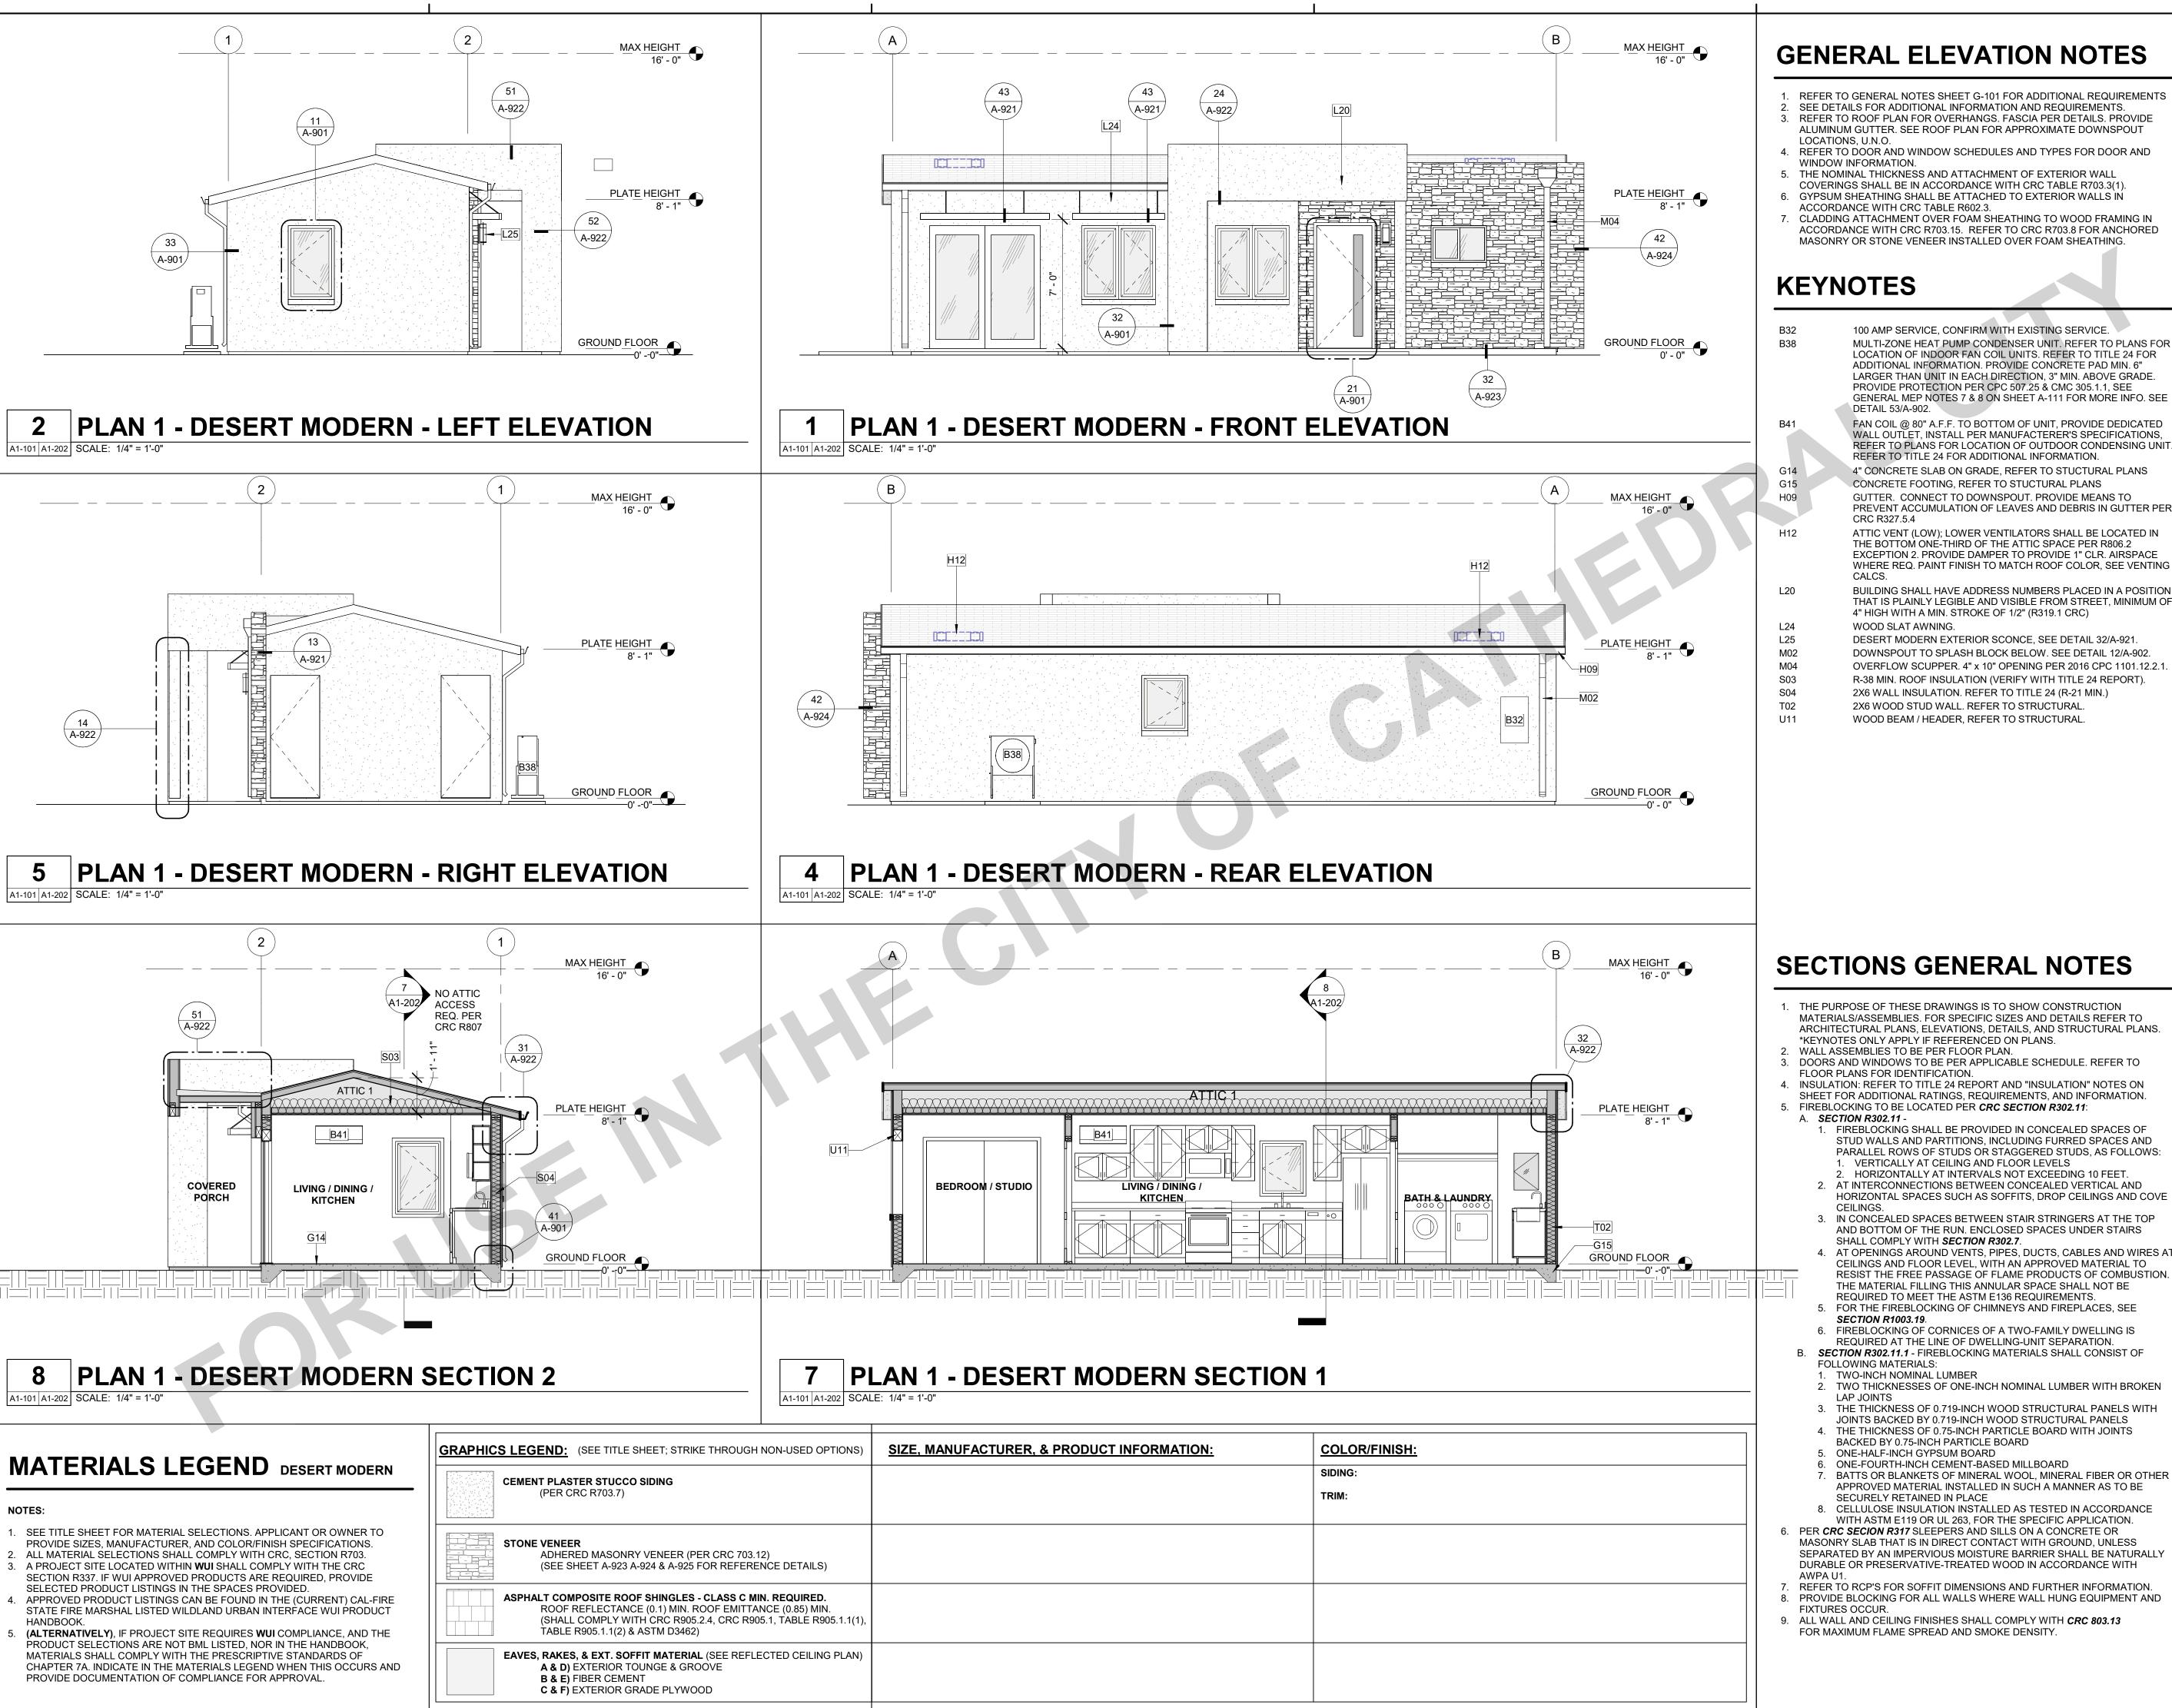

GENERAL ELEVATION NOTES

- REFER TO GENERAL NOTES SHEET G-101 FOR ADDITIONAL REQUIREMENTS SEE DETAILS FOR ADDITIONAL INFORMATION AND REQUIREMENTS. REFER TO ROOF PLAN FOR OVERHANGS. FASCIA PER DETAILS. PROVIDE ALUMINUM GUTTER. SEE ROOF PLAN FOR APPROXIMATE DOWNSPOUT
- LOCATIONS, U.N.O. 4. REFER TO DOOR AND WINDOW SCHEDULES AND TYPES FOR DOOR AND
- THE NOMINAL THICKNESS AND ATTACHMENT OF EXTERIOR WAL
- COVERINGS SHALL BE IN ACCORDANCE WITH CRC TABLE R703.3(1). GYPSUM SHEATHING SHALL BE ATTACHED TO EXTERIOR WALLS IN
- CLADDING ATTACHMENT OVER FOAM SHEATHING TO WOOD FRAMING IN ACCORDANCE WITH CRC R703.15. REFER TO CRC R703.8 FOR ANCHORED MASONRY OR STONE VENEER INSTALLED OVER FOAM SHEATHING

KEYNOTES

- 100 AMP SERVICE, CONFIRM WITH EXISTING SERVICE. MULTI-ZONE HEAT PUMP CONDENSER UNIT. REFER TO PLANS FOR LOCATION OF INDOOR FAN COIL UNITS. REFER TO TITLE 24 FOR ADDITIONAL INFORMATION. PROVIDE CONCRETE PAD MIN. 6" LARGER THAN UNIT IN EACH DIRECTION, 3" MIN. ABOVE GRADE PROVIDE PROTECTION PER CPC 507.25 & CMC 305.1.1, SEE GENERAL MEP NOTES 7 & 8 ON SHEET A-111 FOR MORE INFO. SEE
 - WALL OUTLET, INSTALL PER MANUFACTERER'S SPECIFICATIONS, REFER TO PLANS FOR LOCATION OF OUTDOOR CONDENSING UNIT. REFER TO TITLE 24 FOR ADDITIONAL INFORMATION. 4" CONCRETE SLAB ON GRADE, REFER TO STUCTURAL PLANS
 - GUTTER. CONNECT TO DOWNSPOUT. PROVIDE MEANS TO PREVENT ACCUMULATION OF LEAVES AND DEBRIS IN GUTTER PER ATTIC VENT (LOW); LOWER VENTILATORS SHALL BE LOCATED IN THE BOTTOM ONE-THIRD OF THE ATTIC SPACE PER R806.2
 - BUILDING SHALL HAVE ADDRESS NUMBERS PLACED IN A POSITION THAT IS PLAINLY LEGIBLE AND VISIBLE FROM STREET, MINIMUM OF 4" HIGH WITH A MIN. STROKE OF 1/2" (R319.1 CRC)
- WOOD SLAT AWNING. DESERT MODERN EXTERIOR SCONCE, SEE DETAIL 32/A-921. DOWNSPOUT TO SPLASH BLOCK BELOW. SEE DETAIL 12/A-902. OVERFLOW SCUPPER. 4" x 10" OPENING PER 2016 CPC 1101.12.2.1.
- R-38 MIN. ROOF INSULATION (VERIFY WITH TITLE 24 REPORT). 2X6 WALL INSULATION. REFER TO TITLE 24 (R-21 MIN.) 2X6 WOOD STUD WALL. REFER TO STRUCTURAL. WOOD BEAM / HEADER, REFER TO STRUCTURAL

- 1. THE PURPOSE OF THESE DRAWINGS IS TO SHOW CONSTRUCTION MATERIALS/ASSEMBLIES. FOR SPECIFIC SIZES AND DETAILS REFER TO ARCHITECTURAL PLANS, ELEVATIONS, DETAILS, AND STRUCTURAL PLANS. *KEYNOTES ONLY APPLY IF REFERENCED ON PLANS.
- WALL ASSEMBLIES TO BE PER FLOOR PLAN. DOORS AND WINDOWS TO BE PER APPLICABLE SCHEDULE. REFER TO FLOOR PLANS FOR IDENTIFICATION.
- 4. INSULATION: REFER TO TITLE 24 REPORT AND "INSULATION" NOTES ON SHEET FOR ADDITIONAL RATINGS. REQUIREMENTS, AND INFORMATION.
- 5. FIREBLOCKING TO BE LOCATED PER CRC SECTION R302.11: A. **SECTION R302.11** -1. FIREBLOCKING SHALL BE PROVIDED IN CONCEALED SPACES OF
- PARALLEL ROWS OF STUDS OR STAGGERED STUDS, AS FOLLOWS: VERTICALLY AT CEILING AND FLOOR LEVELS HORIZONTALLY AT INTERVALS NOT EXCEEDING 10 FEET. 2. AT INTERCONNECTIONS BETWEEN CONCEALED VERTICAL AND
- HORIZONTAL SPACES SUCH AS SOFFITS, DROP CEILINGS AND COVE 3. IN CONCEALED SPACES BETWEEN STAIR STRINGERS AT THE TOP
- AND BOTTOM OF THE RUN. ENCLOSED SPACES UNDER STAIRS SHALL COMPLY WITH SECTION R302.7. 4. AT OPENINGS AROUND VENTS, PIPES, DUCTS, CABLES AND WIRES AT CEILINGS AND FLOOR LEVEL, WITH AN APPROVED MATERIAL TO
- THE MATERIAL FILLING THIS ANNULAR SPACE SHALL NOT BE REQUIRED TO MEET THE ASTM E136 REQUIREMENTS. 5. FOR THE FIREBLOCKING OF CHIMNEYS AND FIREPLACES, SEE
- **SECTION R1003.19**. FIREBLOCKING OF CORNICES OF A TWO-FAMILY DWELLING IS
- REQUIRED AT THE LINE OF DWELLING-UNIT SEPARATION. SECTION R302.11.1 - FIREBLOCKING MATERIALS SHALL CONSIST OF
- FOLLOWING MATERIALS: 1. TWO-INCH NOMINAL LUMBER
- TWO THICKNESSES OF ONE-INCH NOMINAL LUMBER WITH BROKEN LAP JOINTS
- 3. THE THICKNESS OF 0.719-INCH WOOD STRUCTURAL PANELS WITH
- JOINTS BACKED BY 0.719-INCH WOOD STRUCTURAL PANELS 4. THE THICKNESS OF 0.75-INCH PARTICLE BOARD WITH JOINTS
- BACKED BY 0.75-INCH PARTICLE BOARD ONE-HALF-INCH GYPSUM BOARD
- ONE-FOURTH-INCH CEMENT-BASED MILLBOARD BATTS OR BLANKETS OF MINERAL WOOL, MINERAL FIBER OR OTHER APPROVED MATERIAL INSTALLED IN SUCH A MANNER AS TO BE
- SECURELY RETAINED IN PLACE 8. CELLULOSE INSULATION INSTALLED AS TESTED IN ACCORDANCE WITH ASTM E119 OR UL 263, FOR THE SPECIFIC APPLICATION.
- PER CRC SECION R317 SLEEPERS AND SILLS ON A CONCRETE OR MASONRY SLAB THAT IS IN DIRECT CONTACT WITH GROUND, UNLESS SEPARATED BY AN IMPERVIOUS MOISTURE BARRIER SHALL BE NATURALLY DURABLE OR PRESERVATIVE-TREATED WOOD IN ACCORDANCE WITH
- REFER TO RCP'S FOR SOFFIT DIMENSIONS AND FURTHER INFORMATION. PROVIDE BLOCKING FOR ALL WALLS WHERE WALL HUNG EQUIPMENT AND
- FIXTURES OCCUR. 9. ALL WALL AND CEILING FINISHES SHALL COMPLY WITH CRC 803.13

FOR MAXIMUM FLAME SPREAD AND SMOKE DENSITY.

Cathedral City

HESE PLANS ARE PROVIDED BY THE CITY OF CATHEDRAL CITY AS PART OF THE PRE-APPROVED ADU PROGRAM AND ARE PUBLIC DOMAIN. THERE CANNOT BE A CHARGE TO PROVIDE THESE PLANS. NO ALTERATIONS TO THESE PLANS ARE ALLOWED. ALL ALTERATIONS MUST BE DONE UNDER A SEPARATE PERMIT ONCE THE BUILDING PERMIT FOR THE ADU HAS BEEN ISSUED AND FINAL INSPECTION COMPLETED. IF YOU DO NOT HAVE THE CONSTRUCTION KNOWLEDGE AND EXPERIENCE TO CONTRUCT THESE PLANS WITHOUT FURTHER DETAILS, IT IS RECOMMENDED YOU HIRE A CONTRACTOR TO DO THE CONSTRUCTION. THE CITY WILL NOT PROVIDE FURTHER INFORMATION OR DETAILS AND BUILDING INSPECTORS WILL NOT PROVIDE STEP BY STEP INSTRUCTIONS IN THE FIELD.

BUILDING


ADU


ATHEDR/


U


08/08/24


SHEET

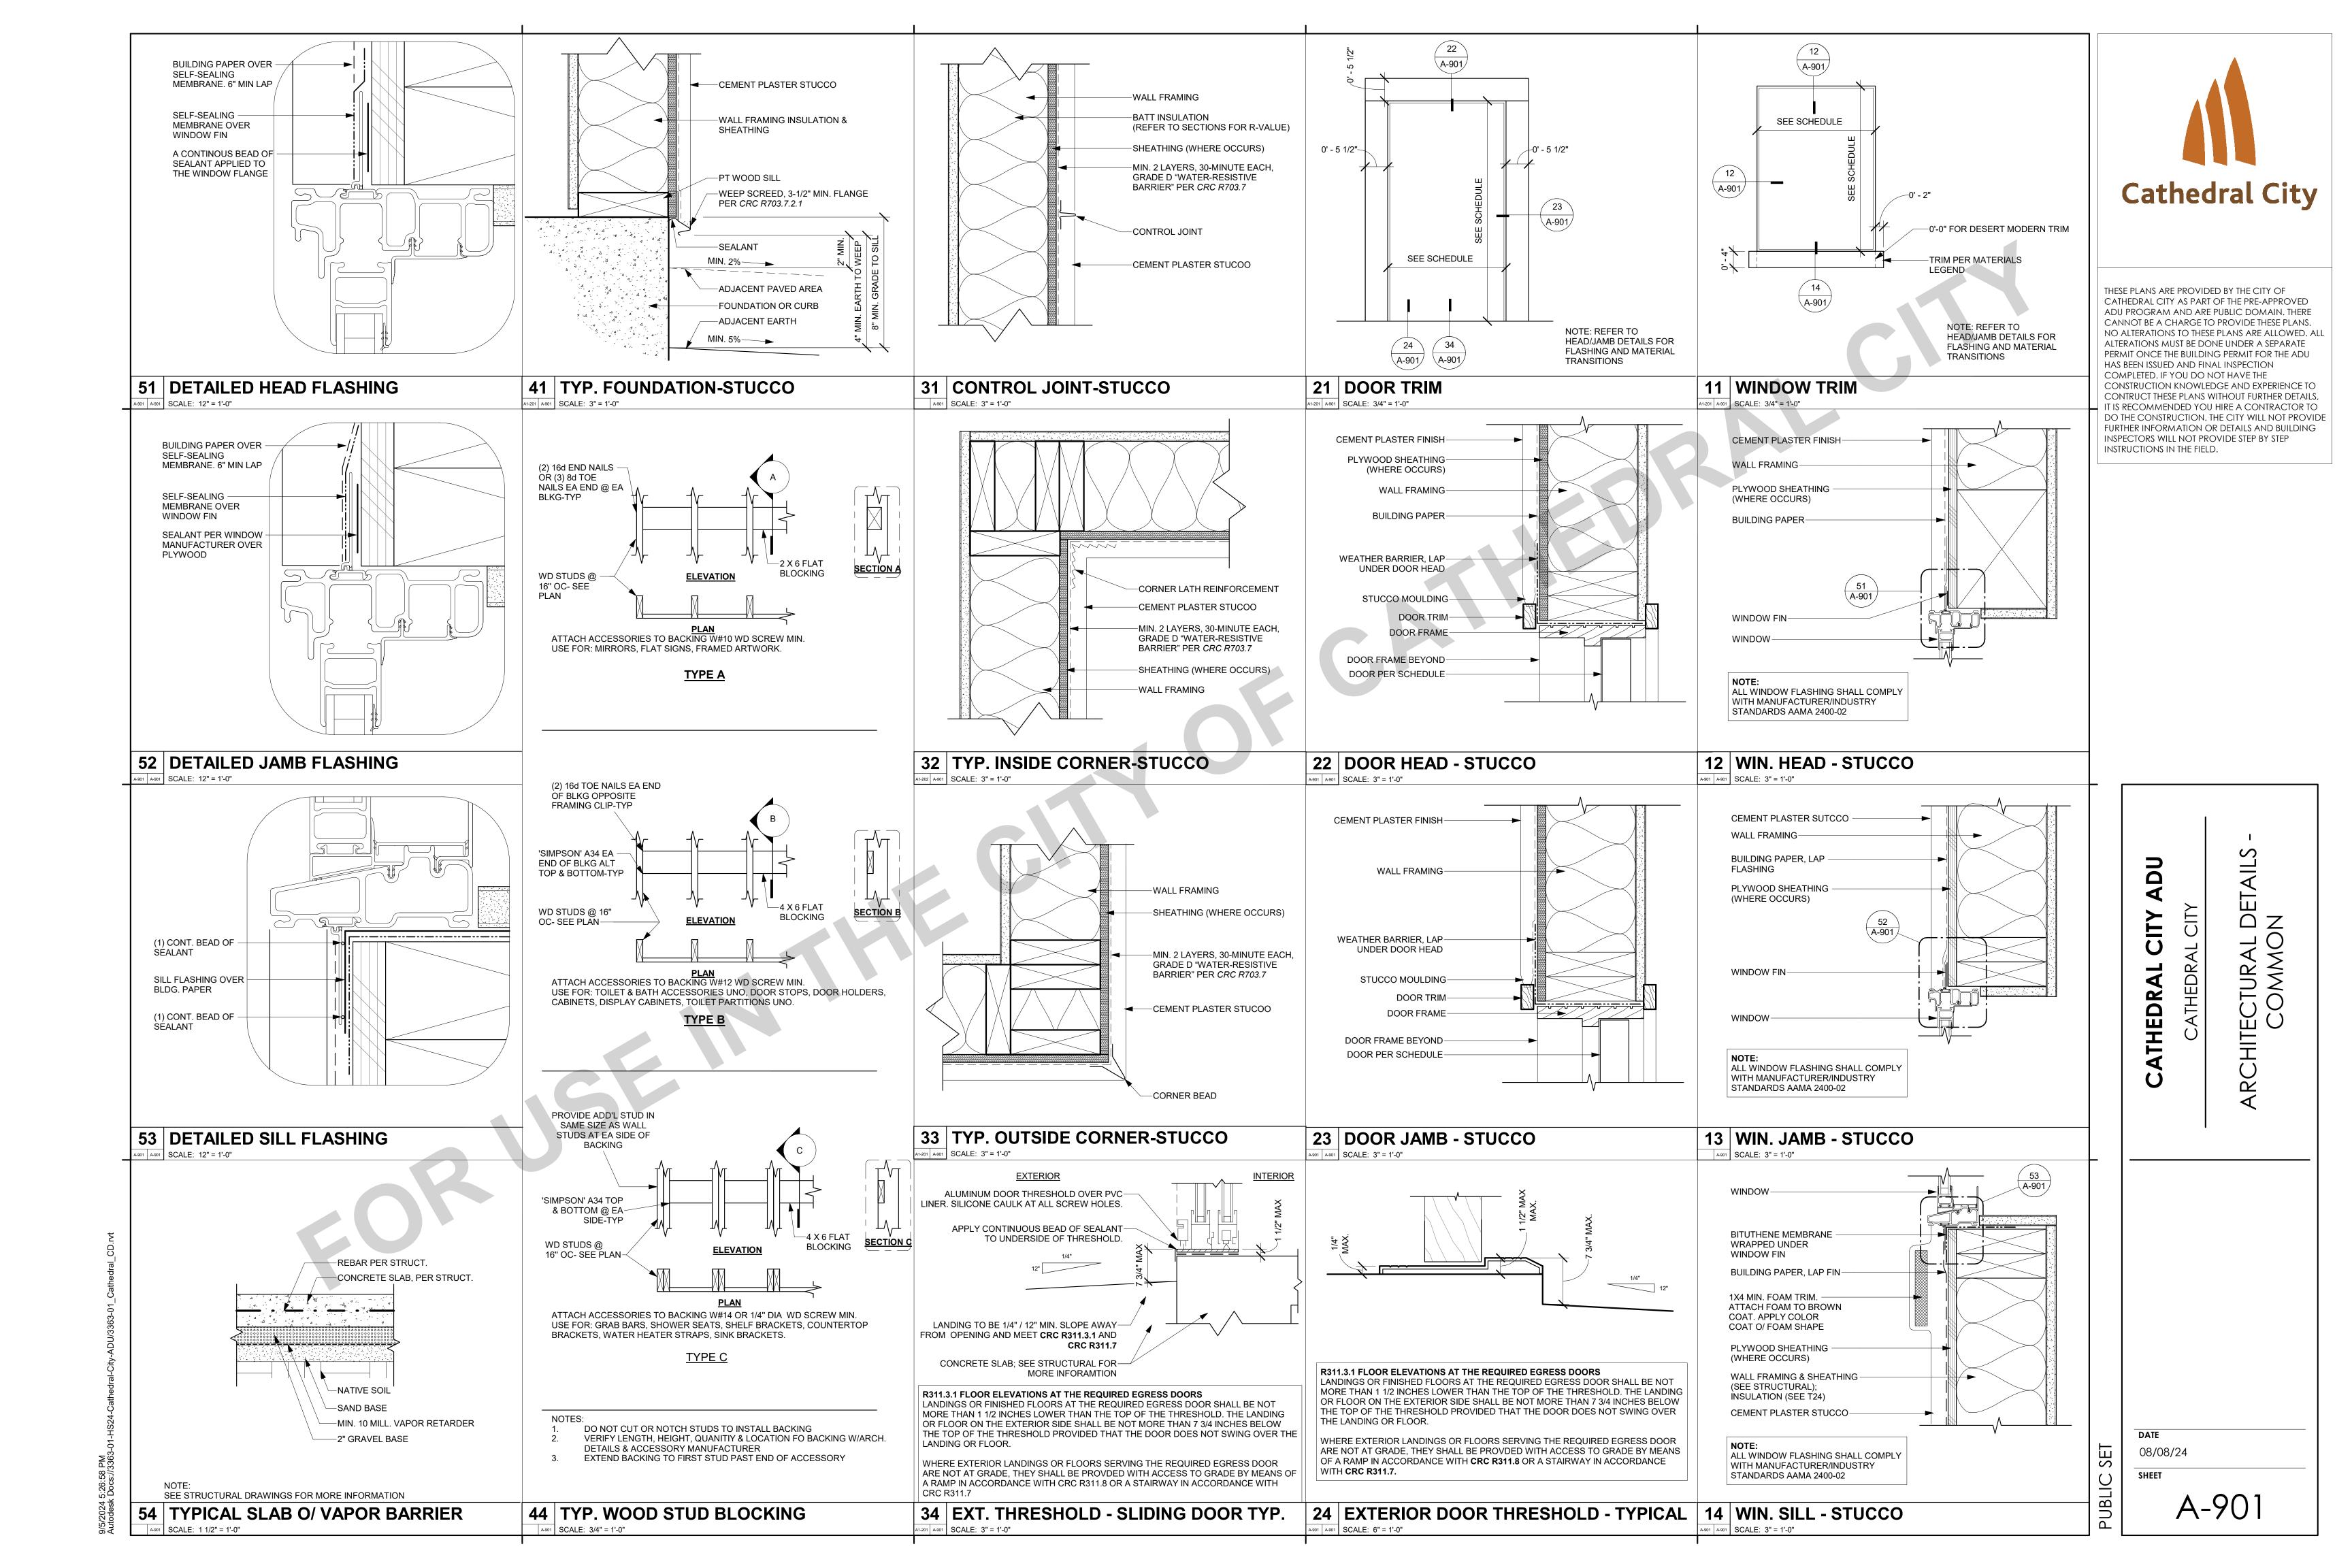

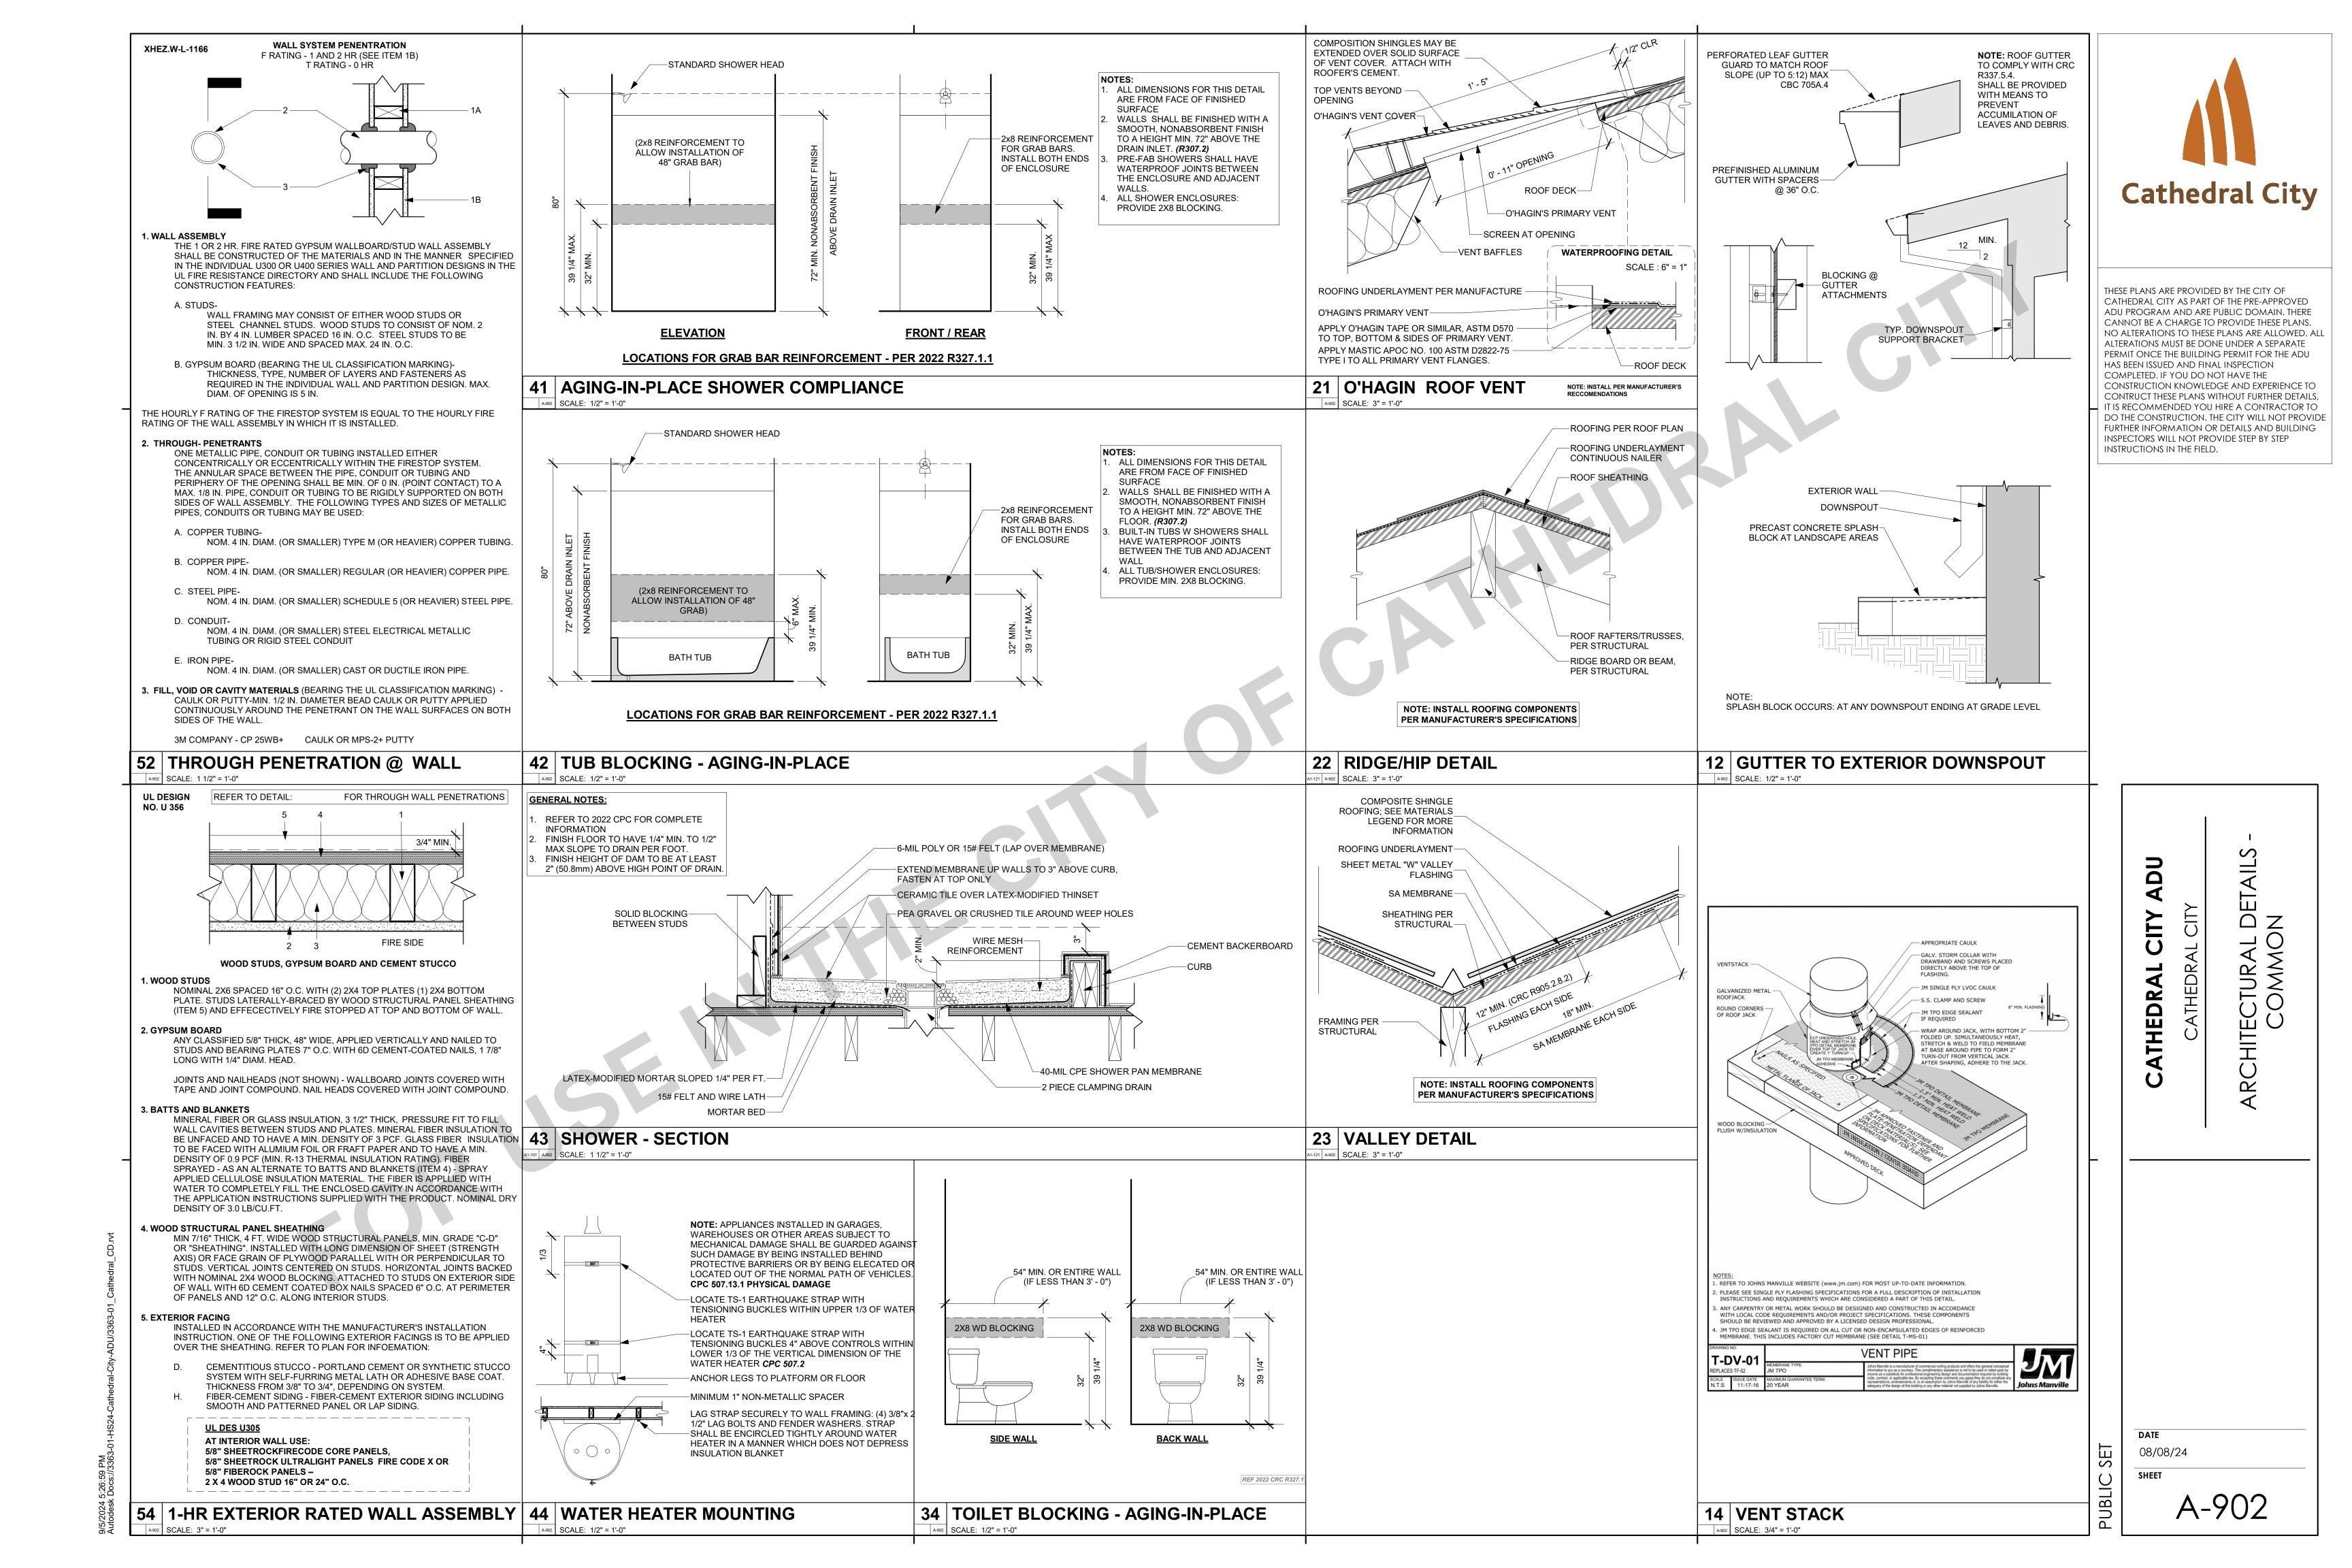

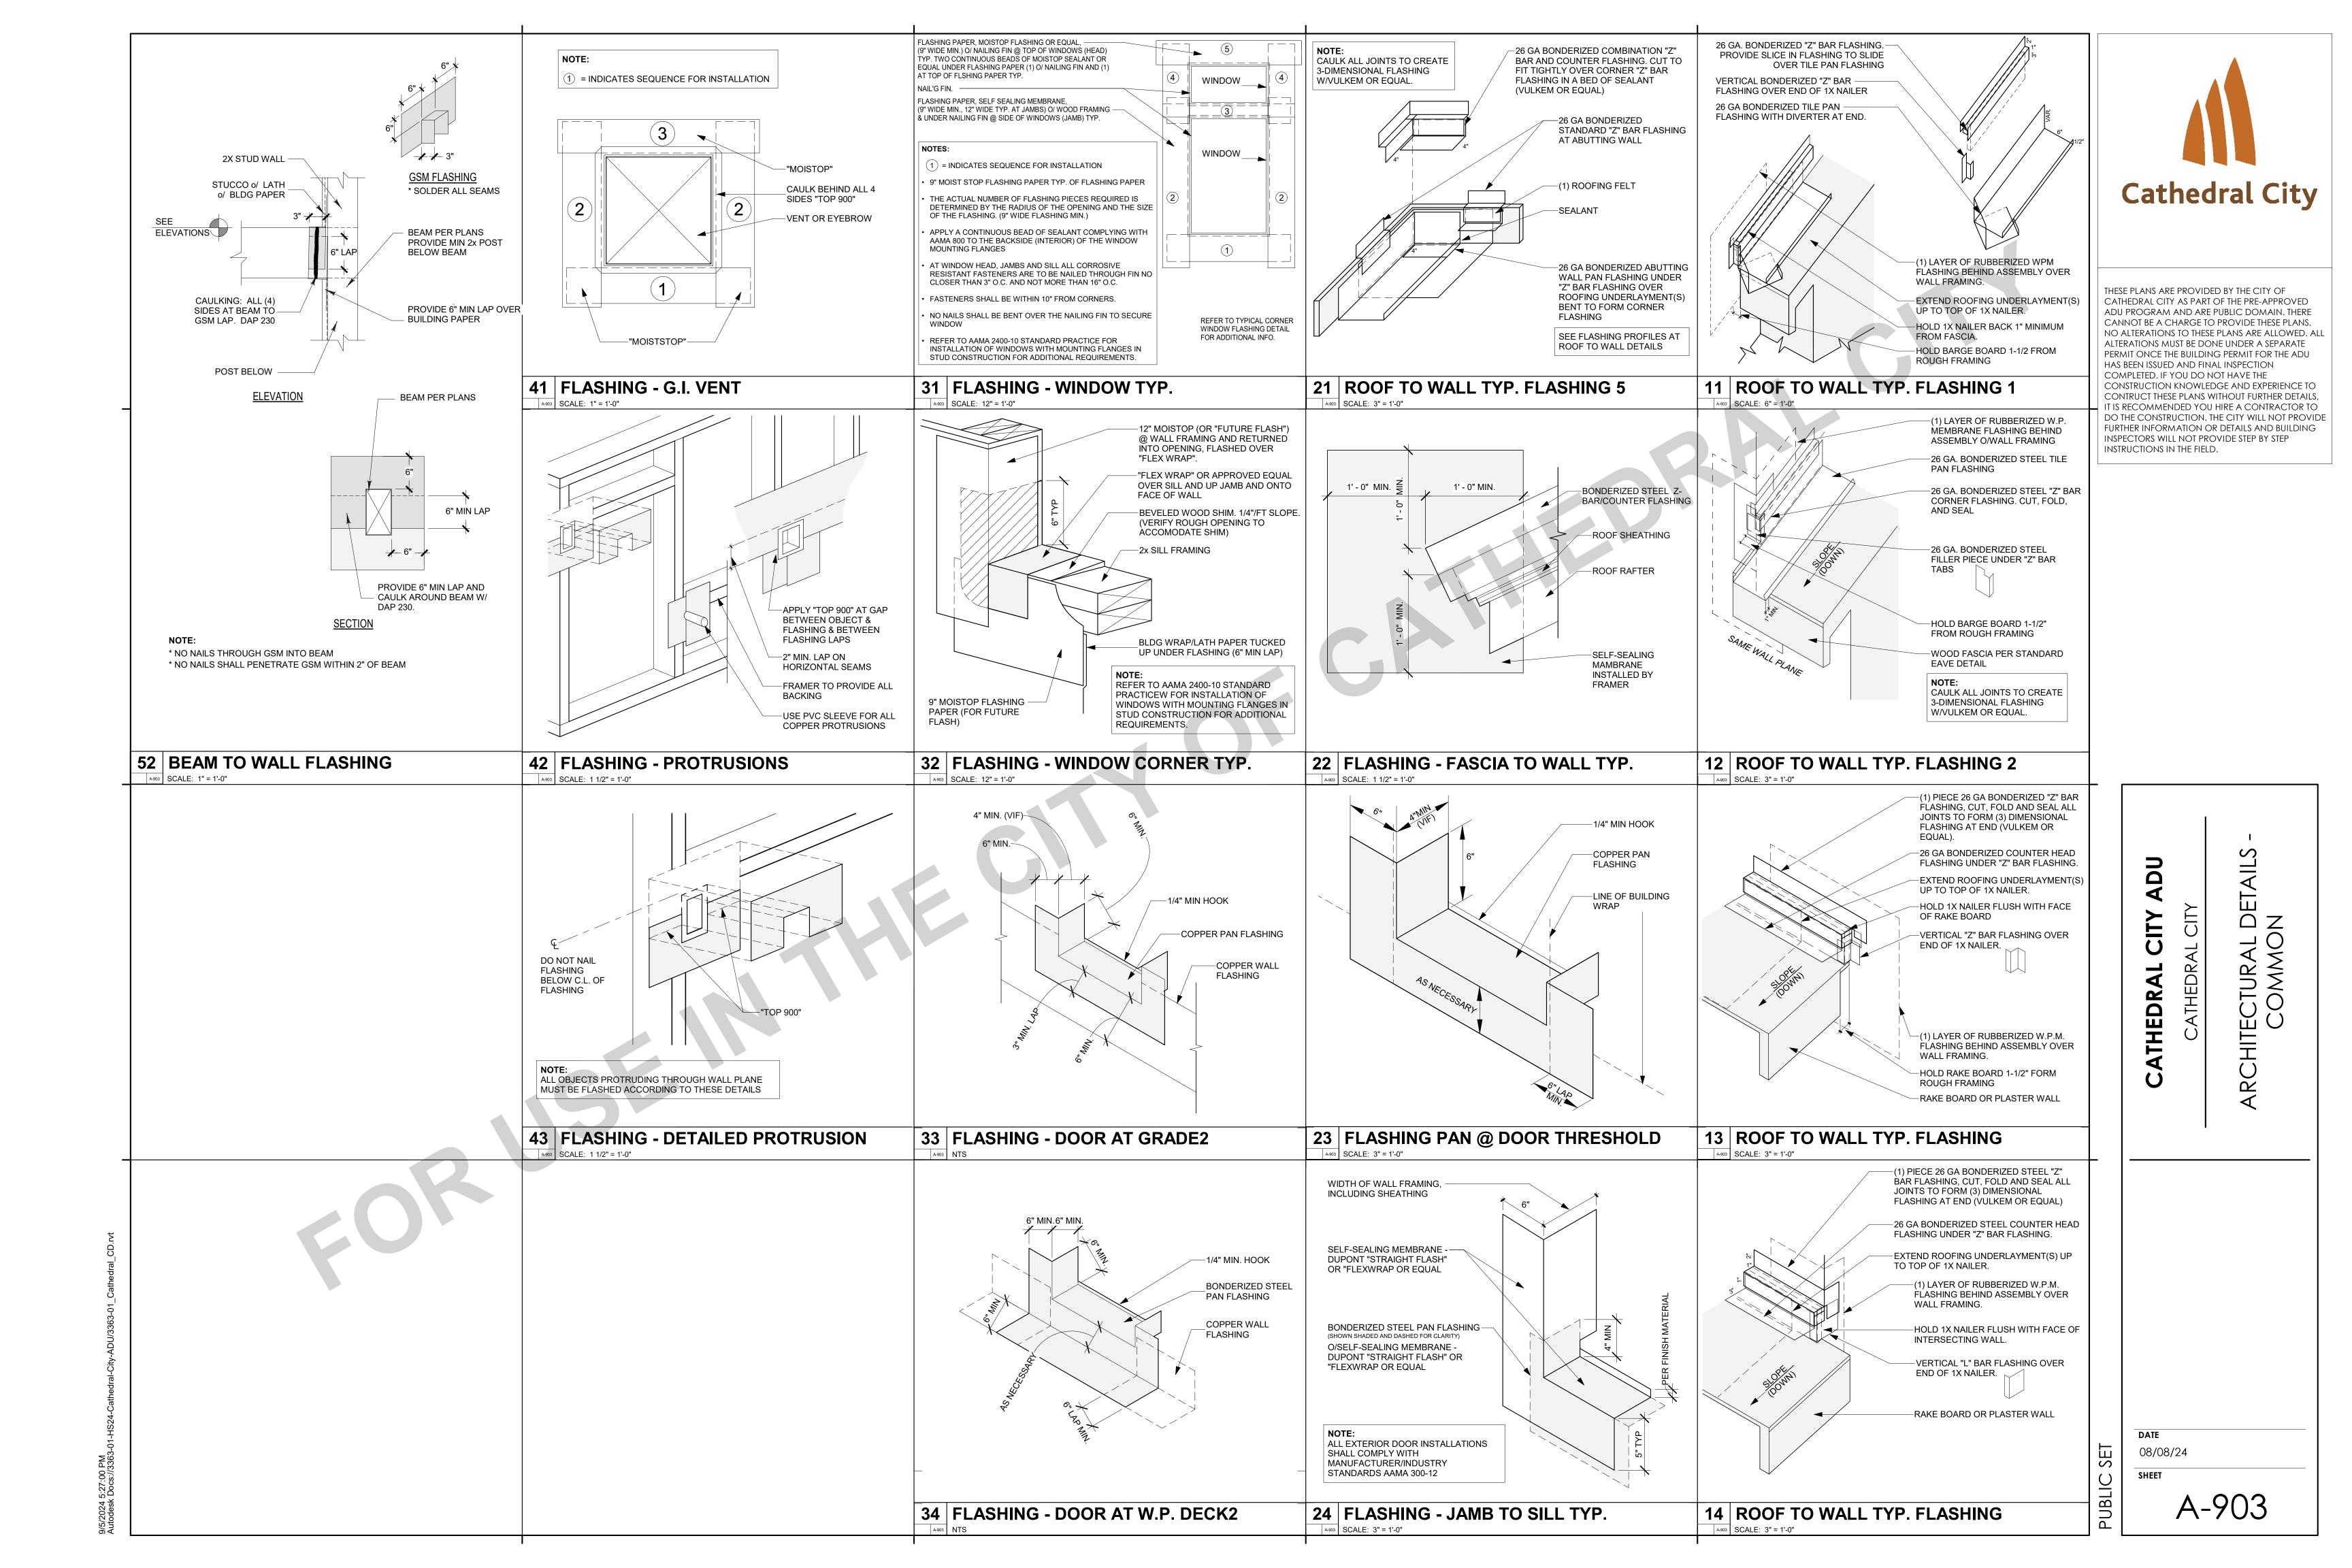

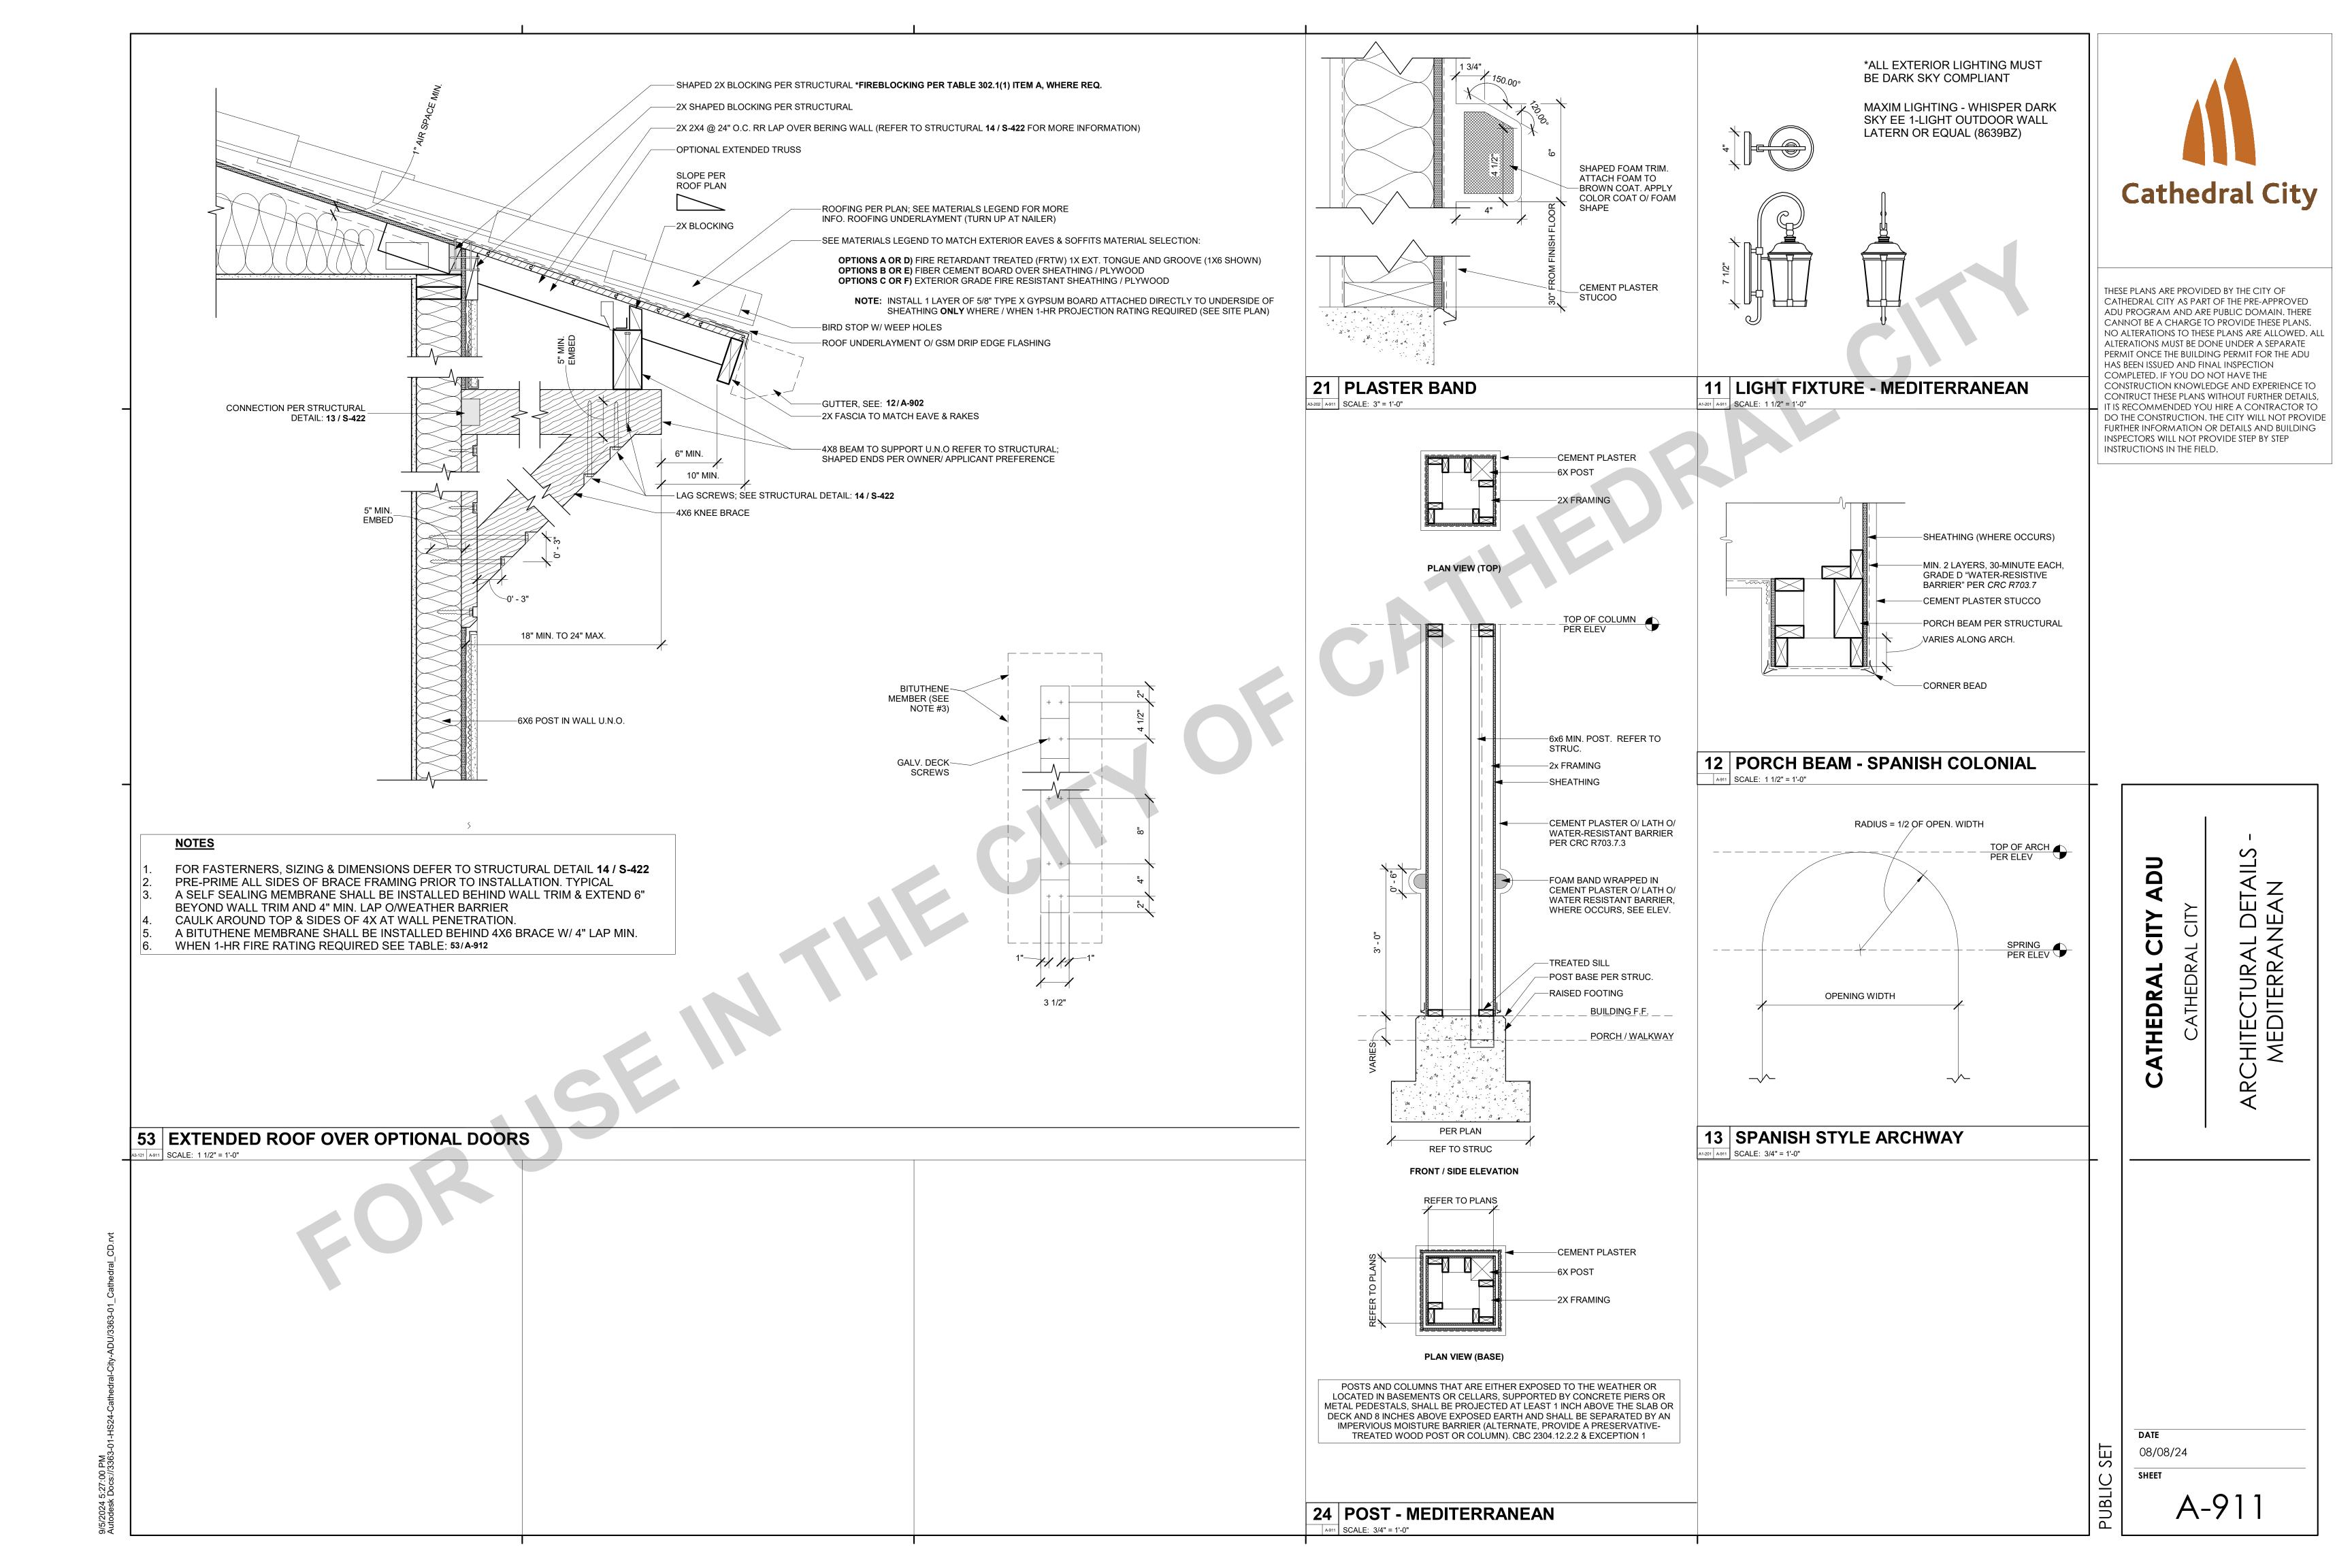

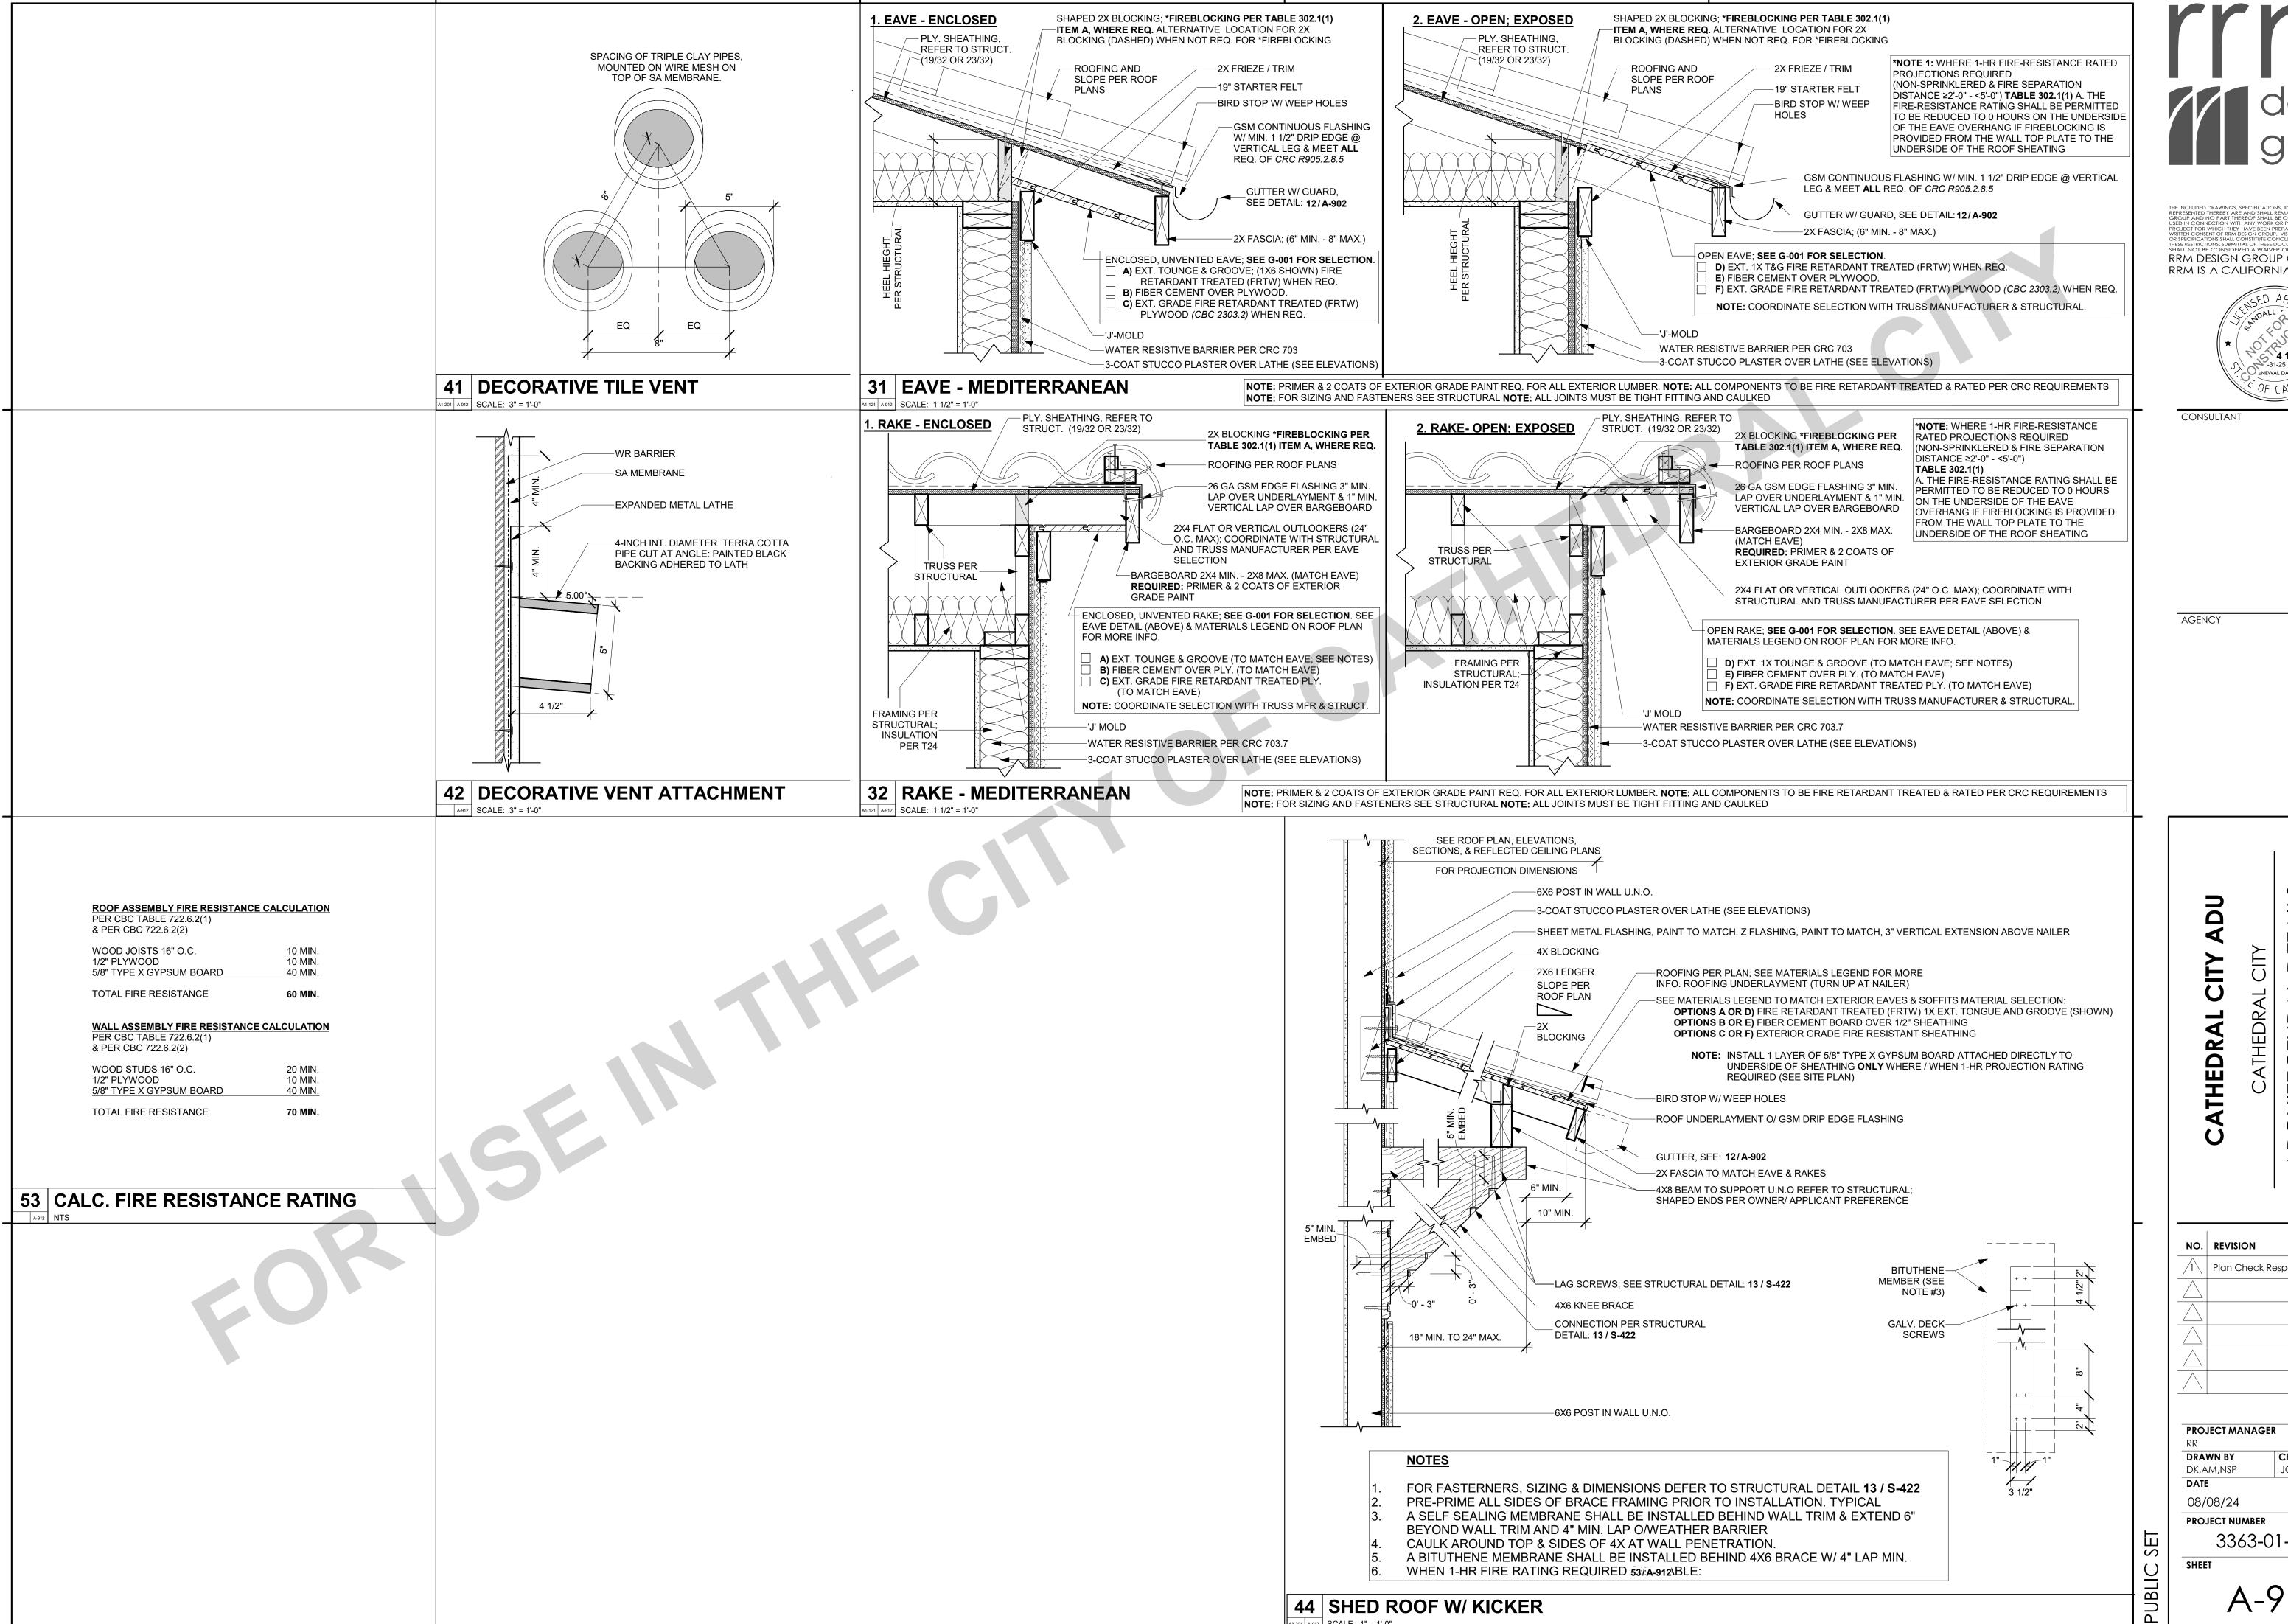

3-201 A-912 SCALE: 1" = 1'-0"


RRM DESIGN GROUP COPYRIGHT 2023 RRM IS A CALIFORNIA CORPORATION




 $1 \setminus |$ Plan Check Response #1 | 07/15/24

CHECKED BY

3363-01-HS24

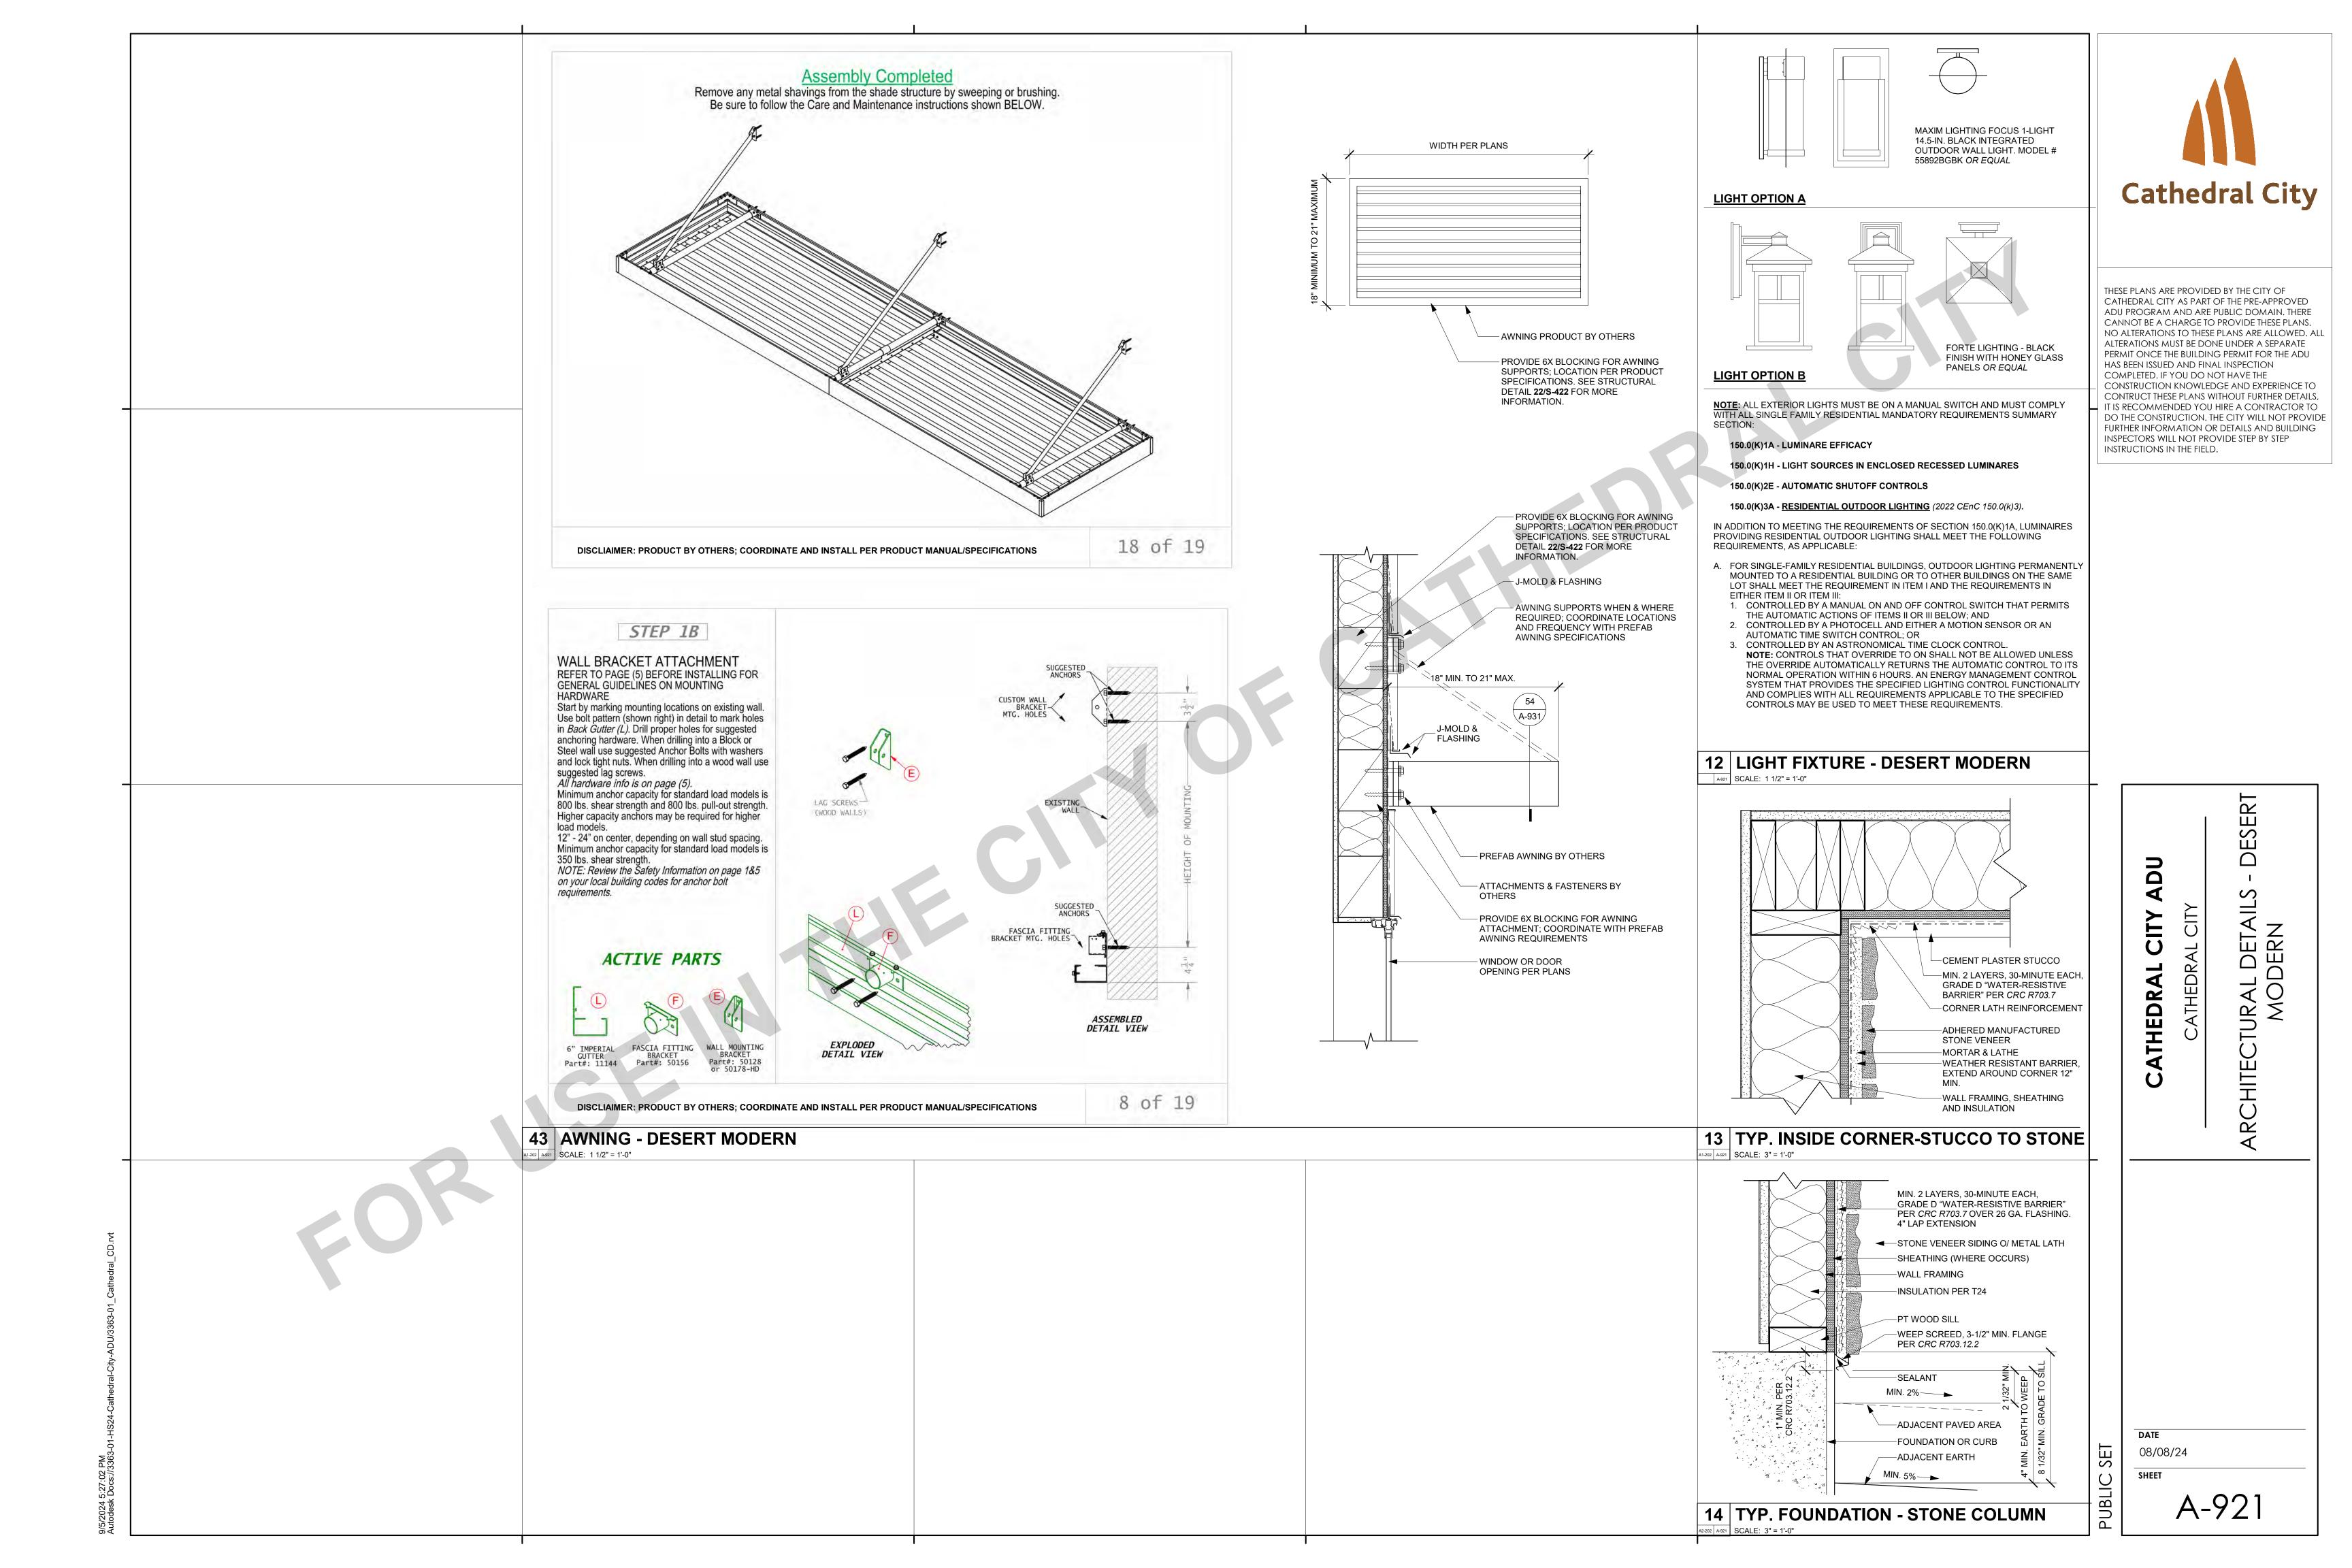

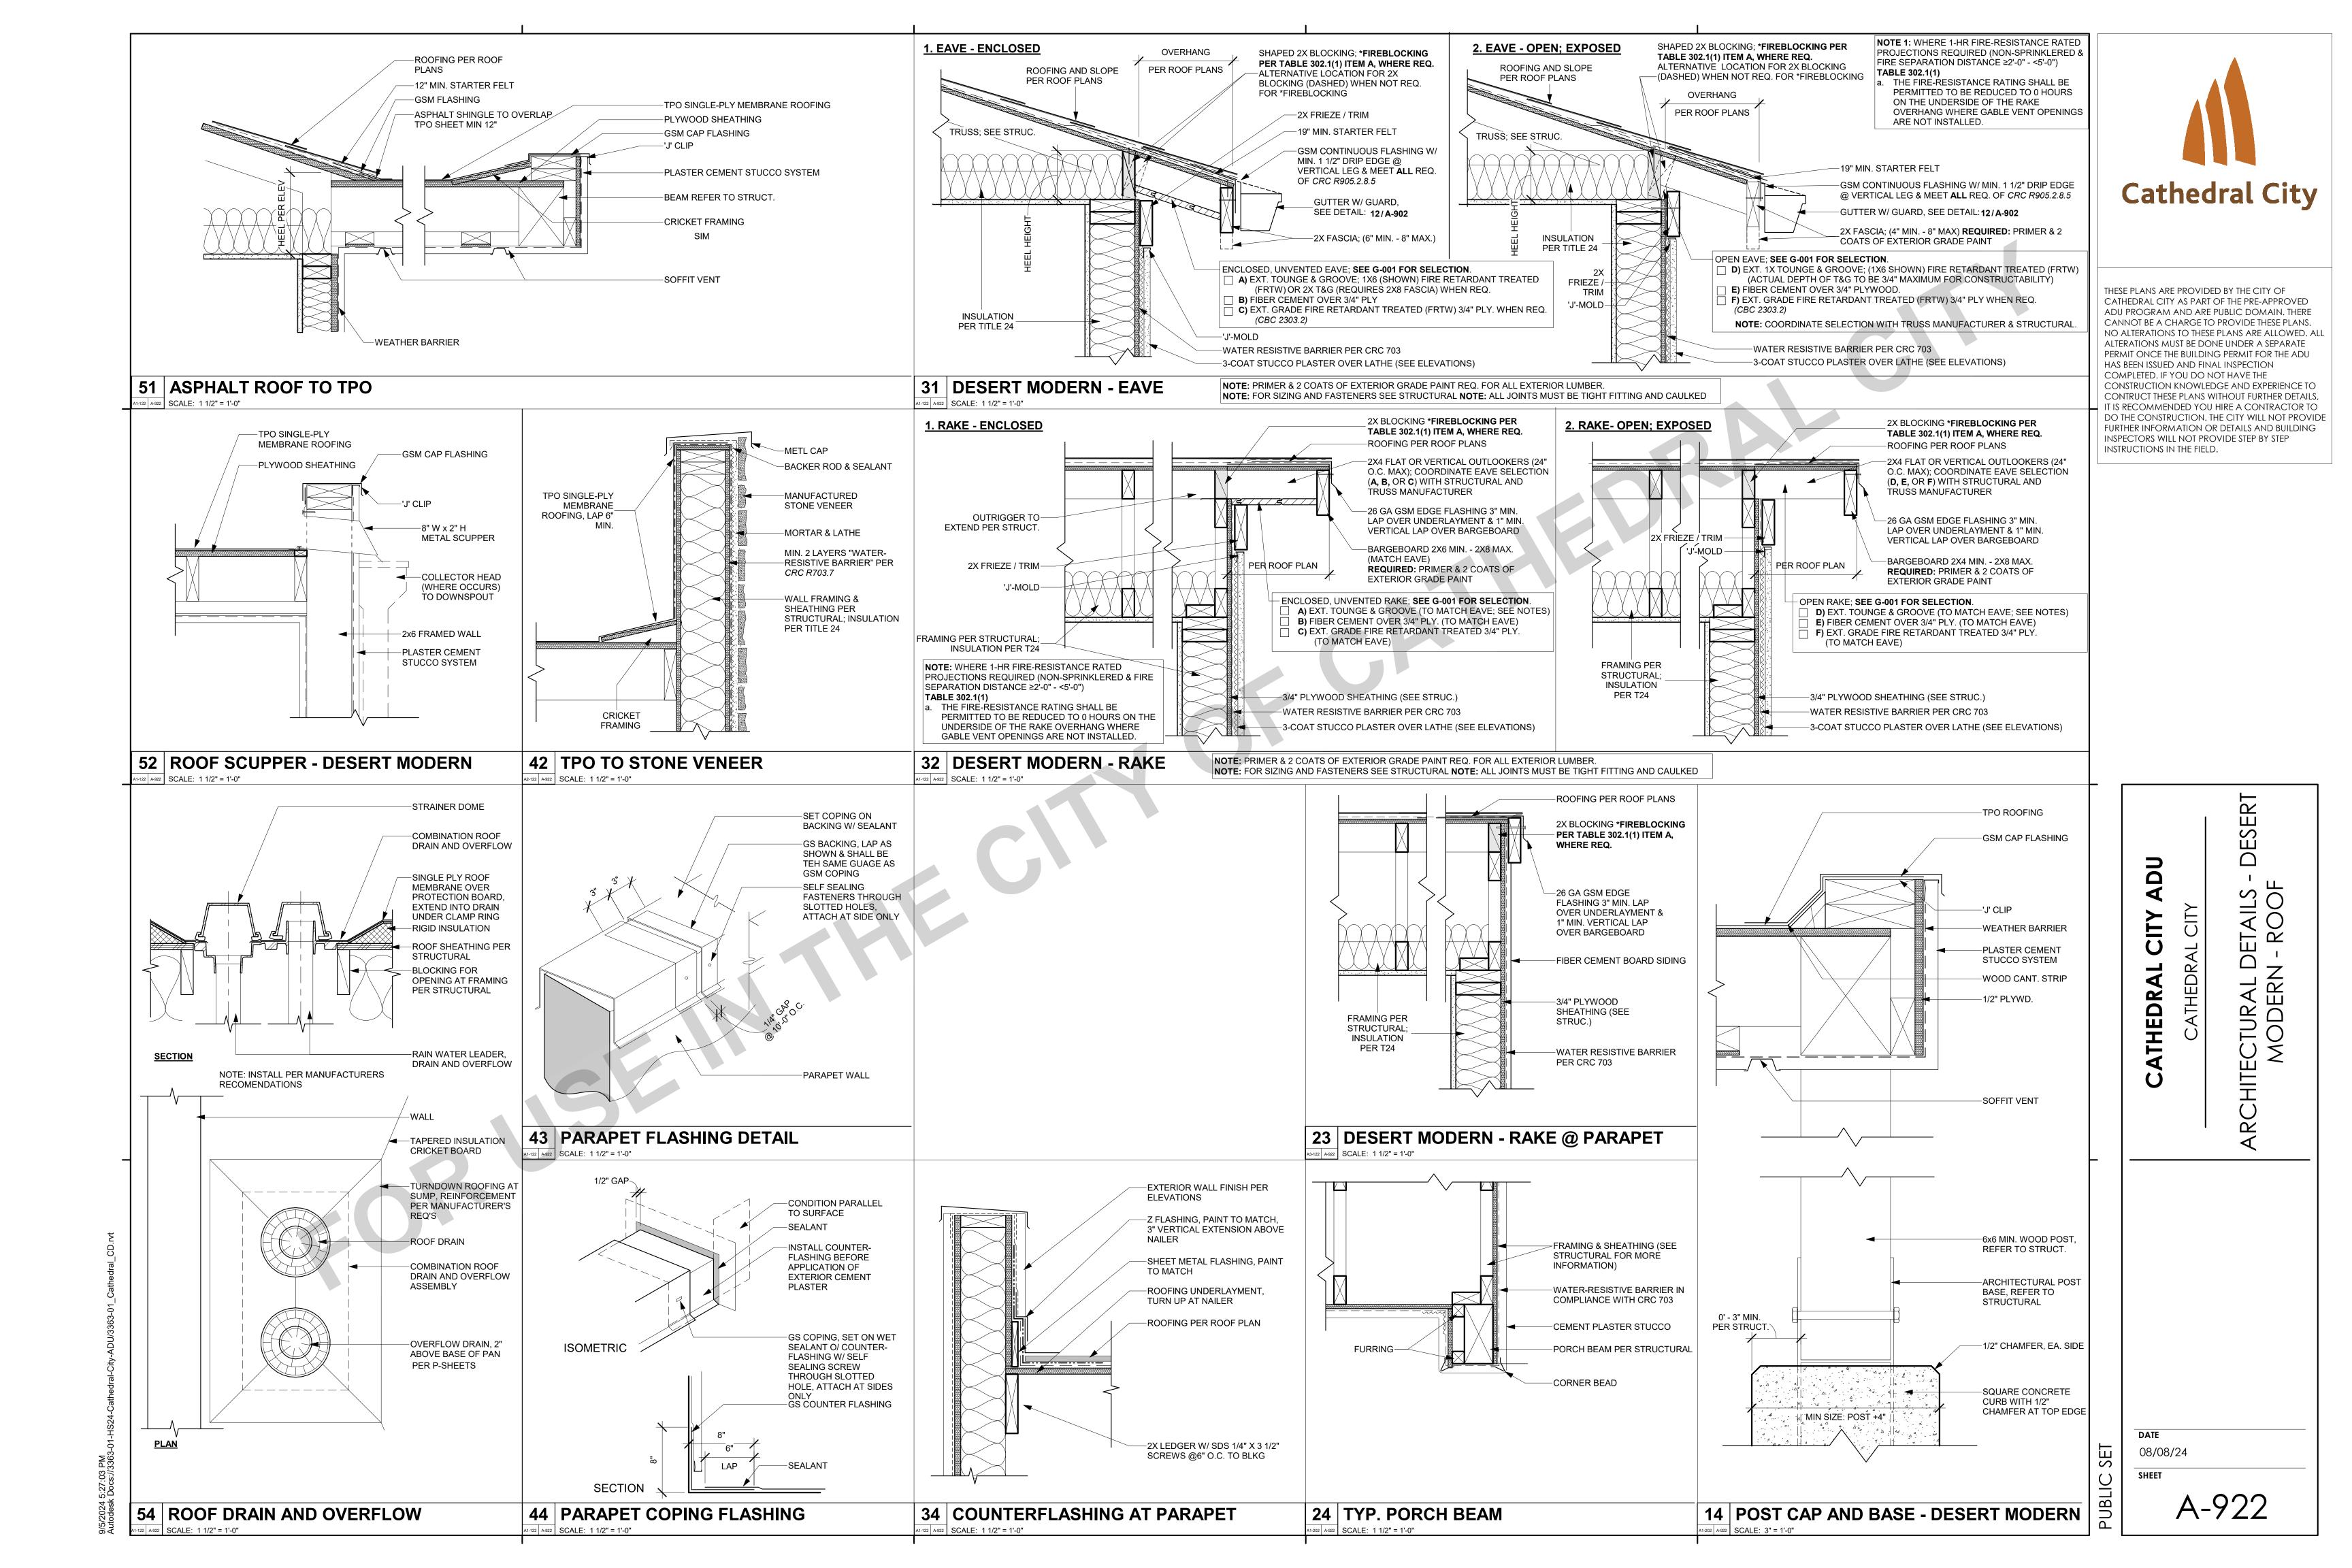

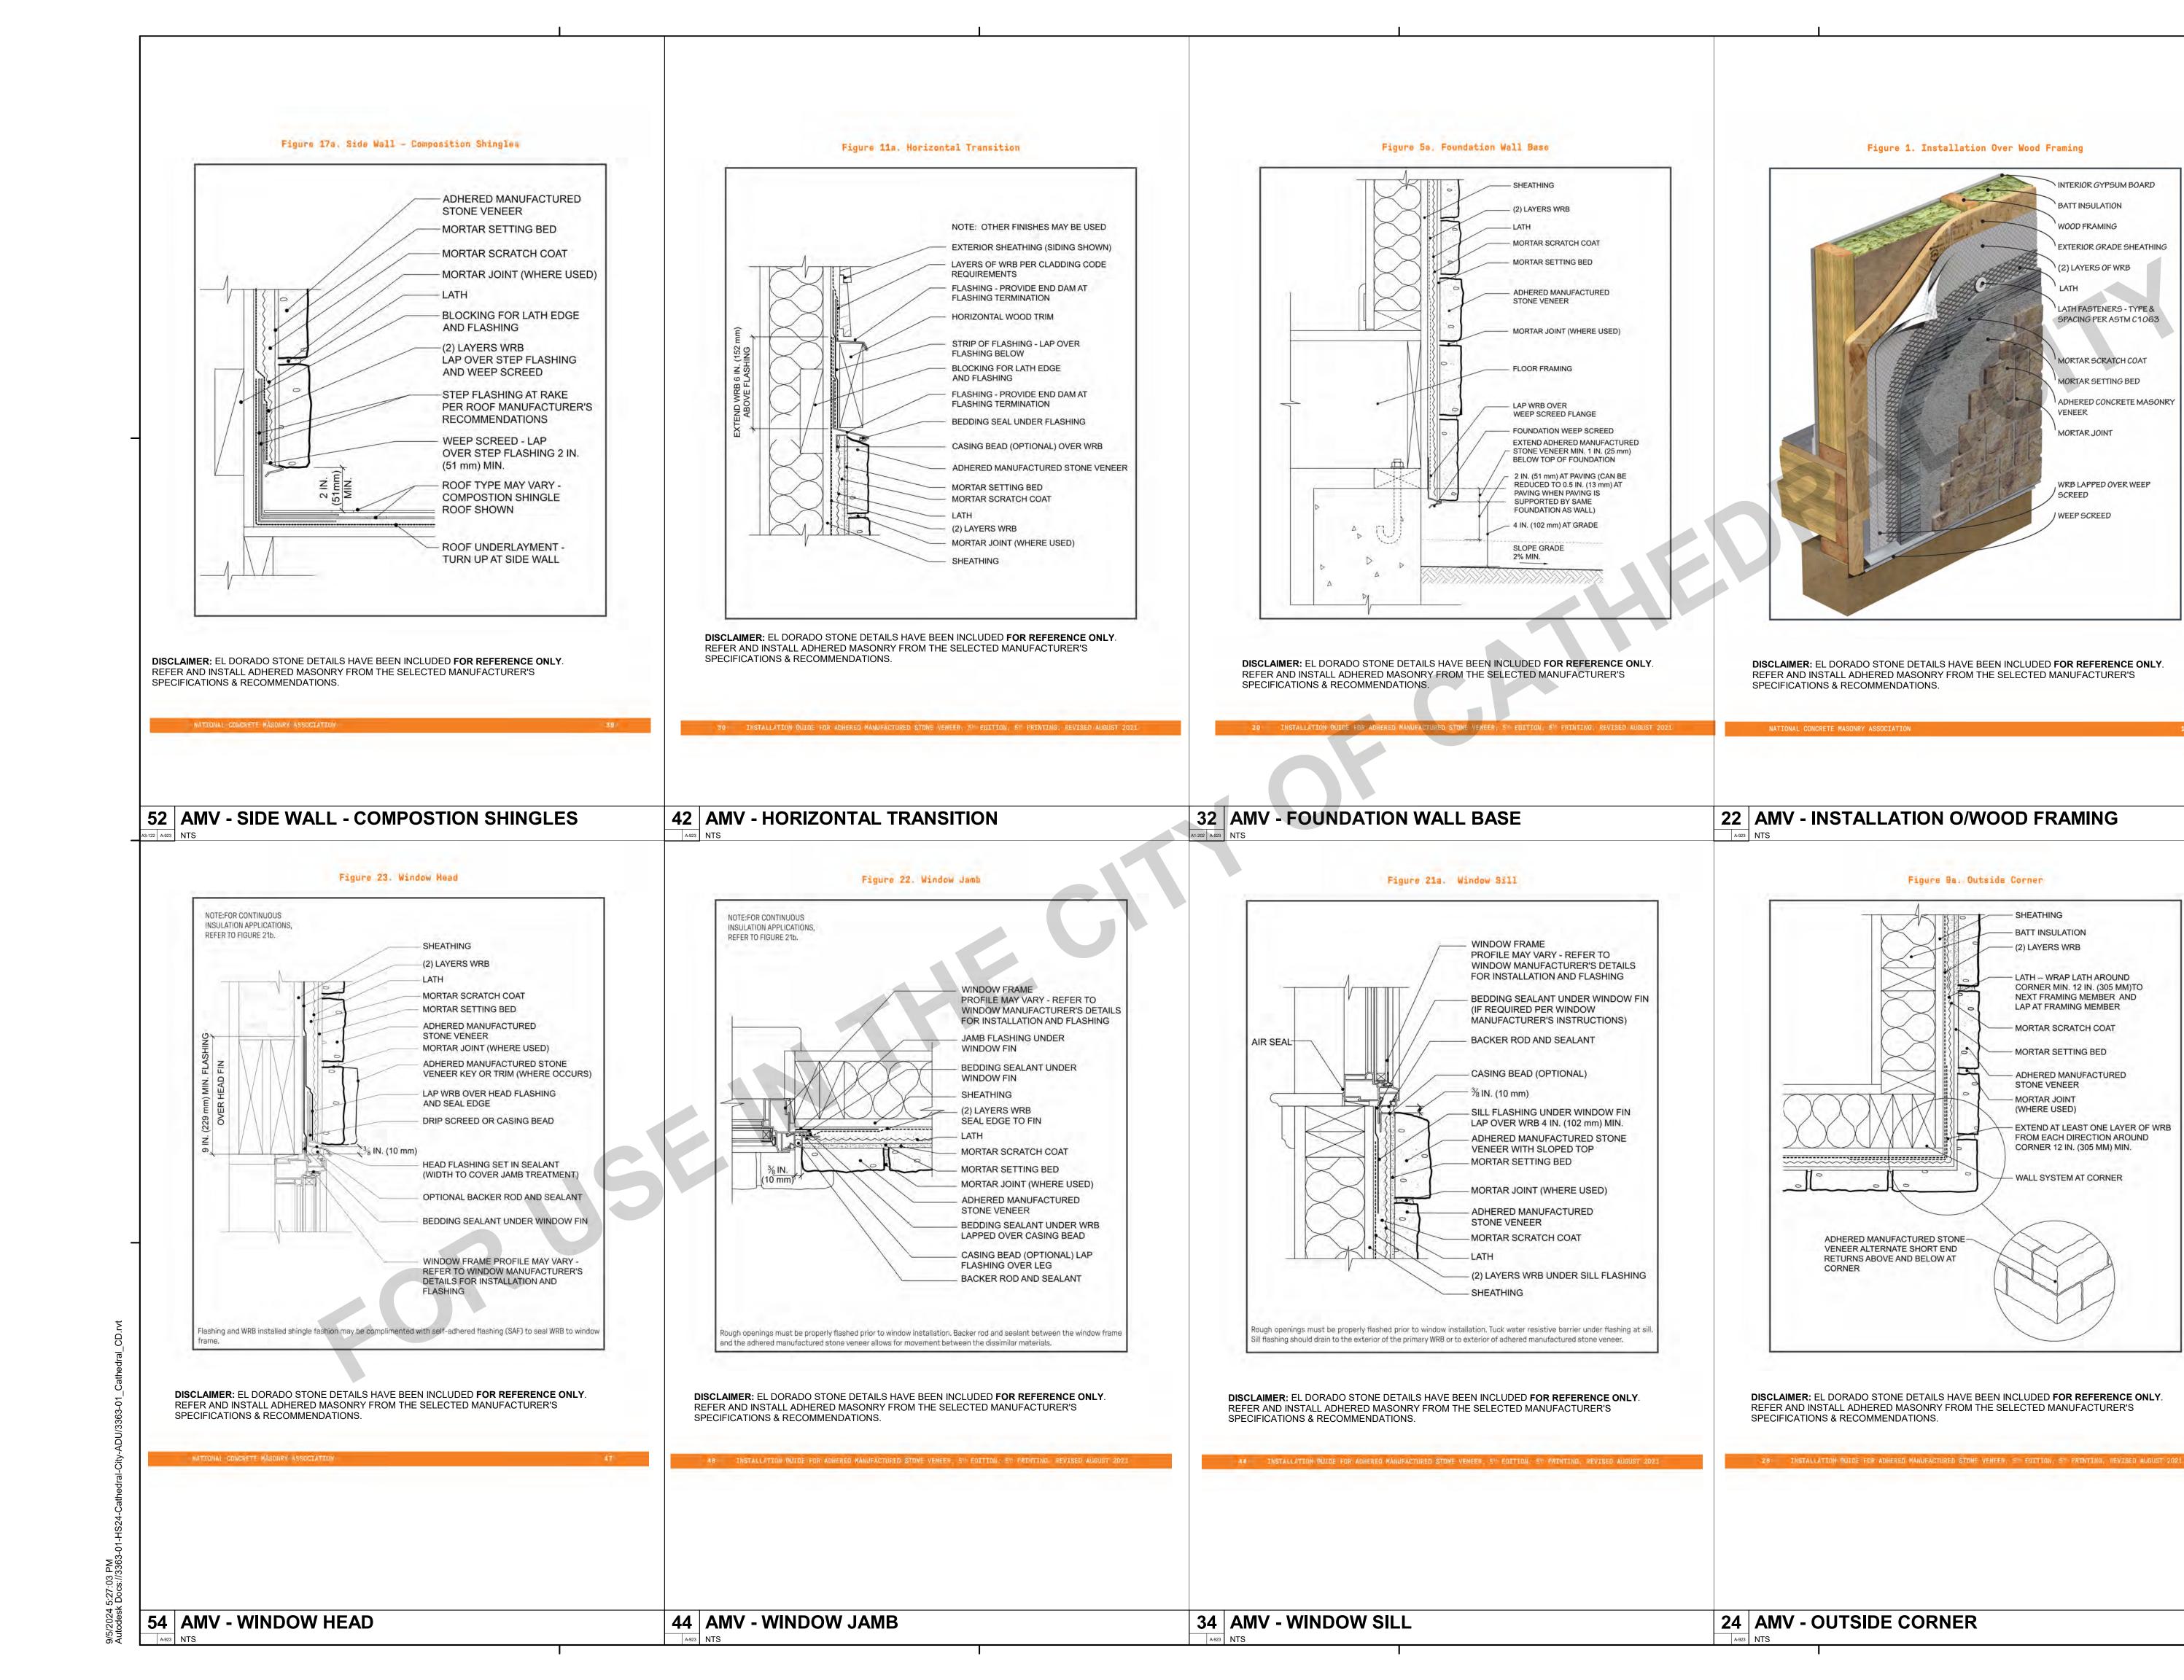




Figure 1. Installation Over Wood Framing

Figure Ba. Outside Corner

- SHEATHING

- BATT INSULATION

- (2) LAYERS WRB

LATH - WRAP LATH AROUND

NEXT FRAMING MEMBER AND

LAP AT FRAMING MEMBER

- MORTAR SCRATCH COAT

- MORTAR SETTING BED

STONE VENEER

- MORTAR JOINT

(WHERE USED)

- ADHERED MANUFACTURED

EXTEND AT LEAST ONE LAYER OF WRB

FROM EACH DIRECTION AROUND

CORNER 12 IN. (305 MM) MIN.

WALL SYSTEM AT CORNER

CORNER MIN. 12 IN. (305 MM)TO

INTERIOR GYPSUM BOARD

EXTERIOR GRADE SHEATHING

LATH FASTENERS - TYPE &

SPACING PER ASTM C1063

MORTAR SCRATCH COAT

MORTAR SETTING BED

WRB LAPPED OVER WEEP

VENEER

SCREED

WEEP SCREED

MORTAR JOINT

ADHERED CONCRETE MASONRY

2) LAYERS OF WRB

BATT INSULATION

WOOD FRAMING

THESE PLANS ARE PROVIDED BY THE CITY OF CATHEDRAL CITY AS PART OF THE PRE-APPROVED ADU PROGRAM AND ARE PUBLIC DOMAIN. THERE CANNOT BE A CHARGE TO PROVIDE THESE PLANS. NO ALTERATIONS TO THESE PLANS ARE ALLOWED. ALI ALTERATIONS MUST BE DONE UNDER A SEPARATE PERMIT ONCE THE BUILDING PERMIT FOR THE ADU HAS BEEN ISSUED AND FINAL INSPECTION COMPLETED. IF YOU DO NOT HAVE THE CONSTRUCTION KNOWLEDGE AND EXPERIENCE TO CONTRUCT THESE PLANS WITHOUT FURTHER DETAILS, IT IS RECOMMENDED YOU HIRE A CONTRACTOR TO DO THE CONSTRUCTION. THE CITY WILL NOT PROVIDE FURTHER INFORMATION OR DETAILS AND BUILDING INSPECTORS WILL NOT PROVIDE STEP BY STEP INSTRUCTIONS IN THE FIELD.

> 4 ATHEDR,


U


RC ERE


 \sim \square


08/08/24 SHEET

PUBL

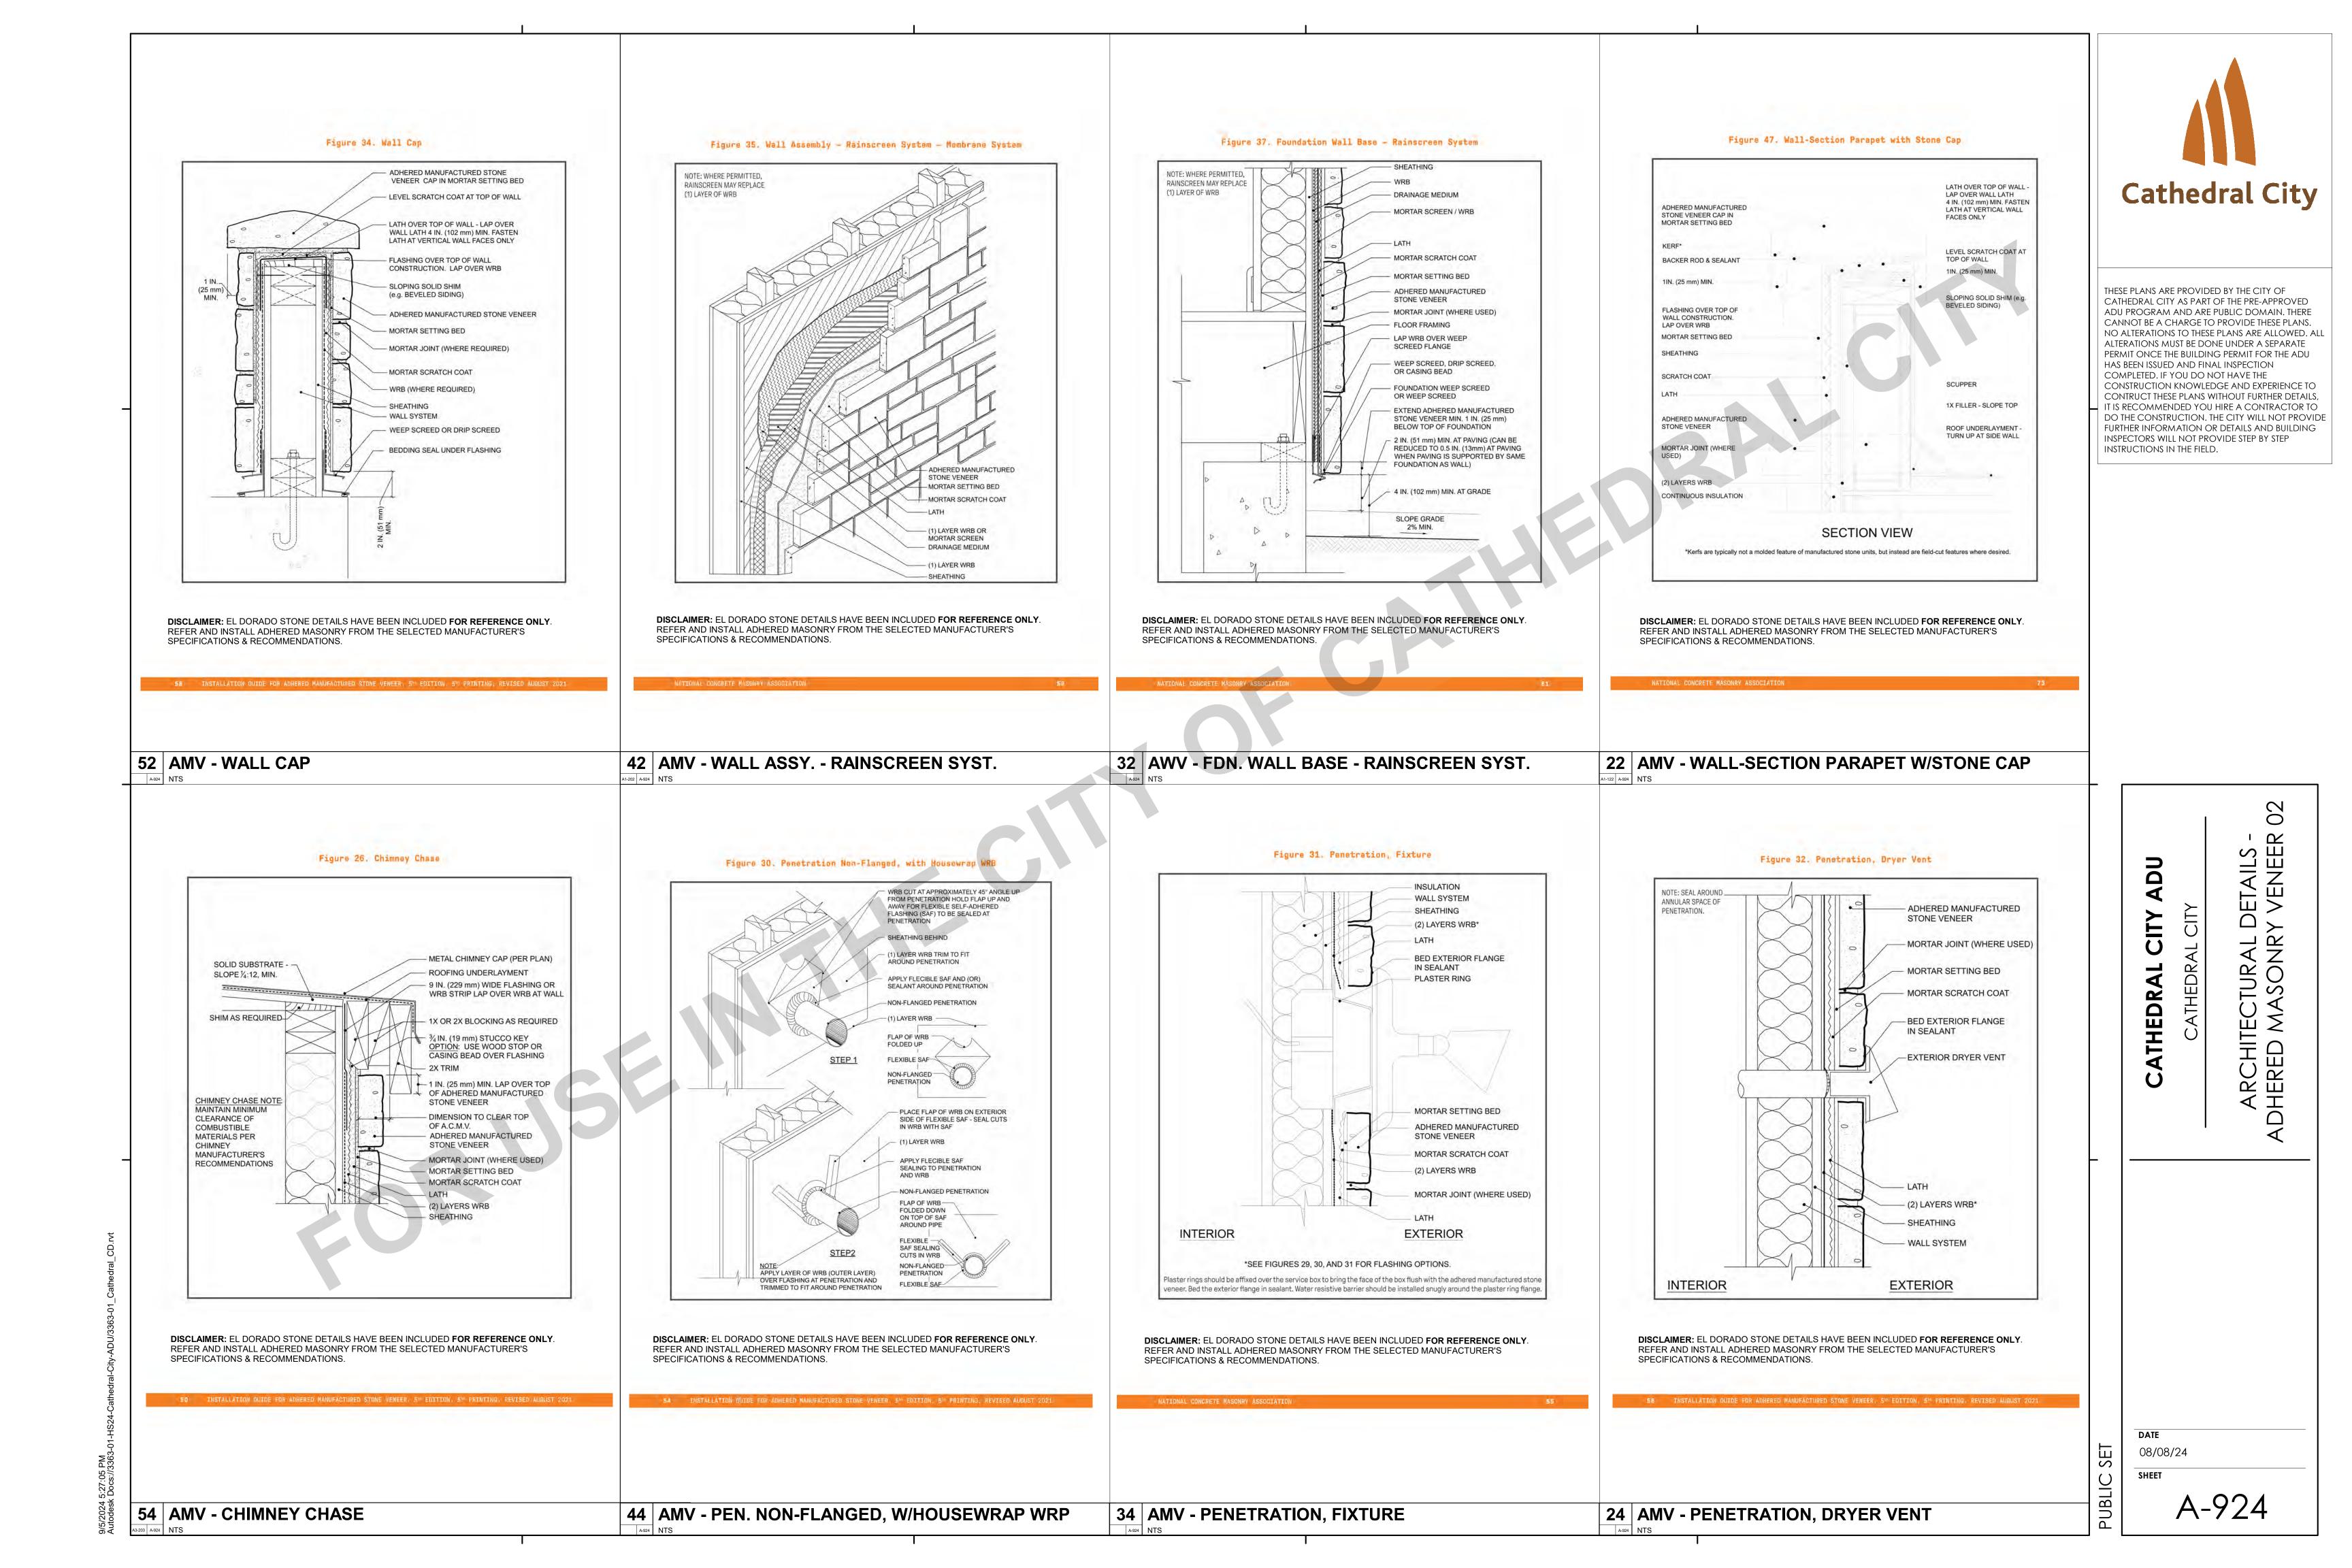

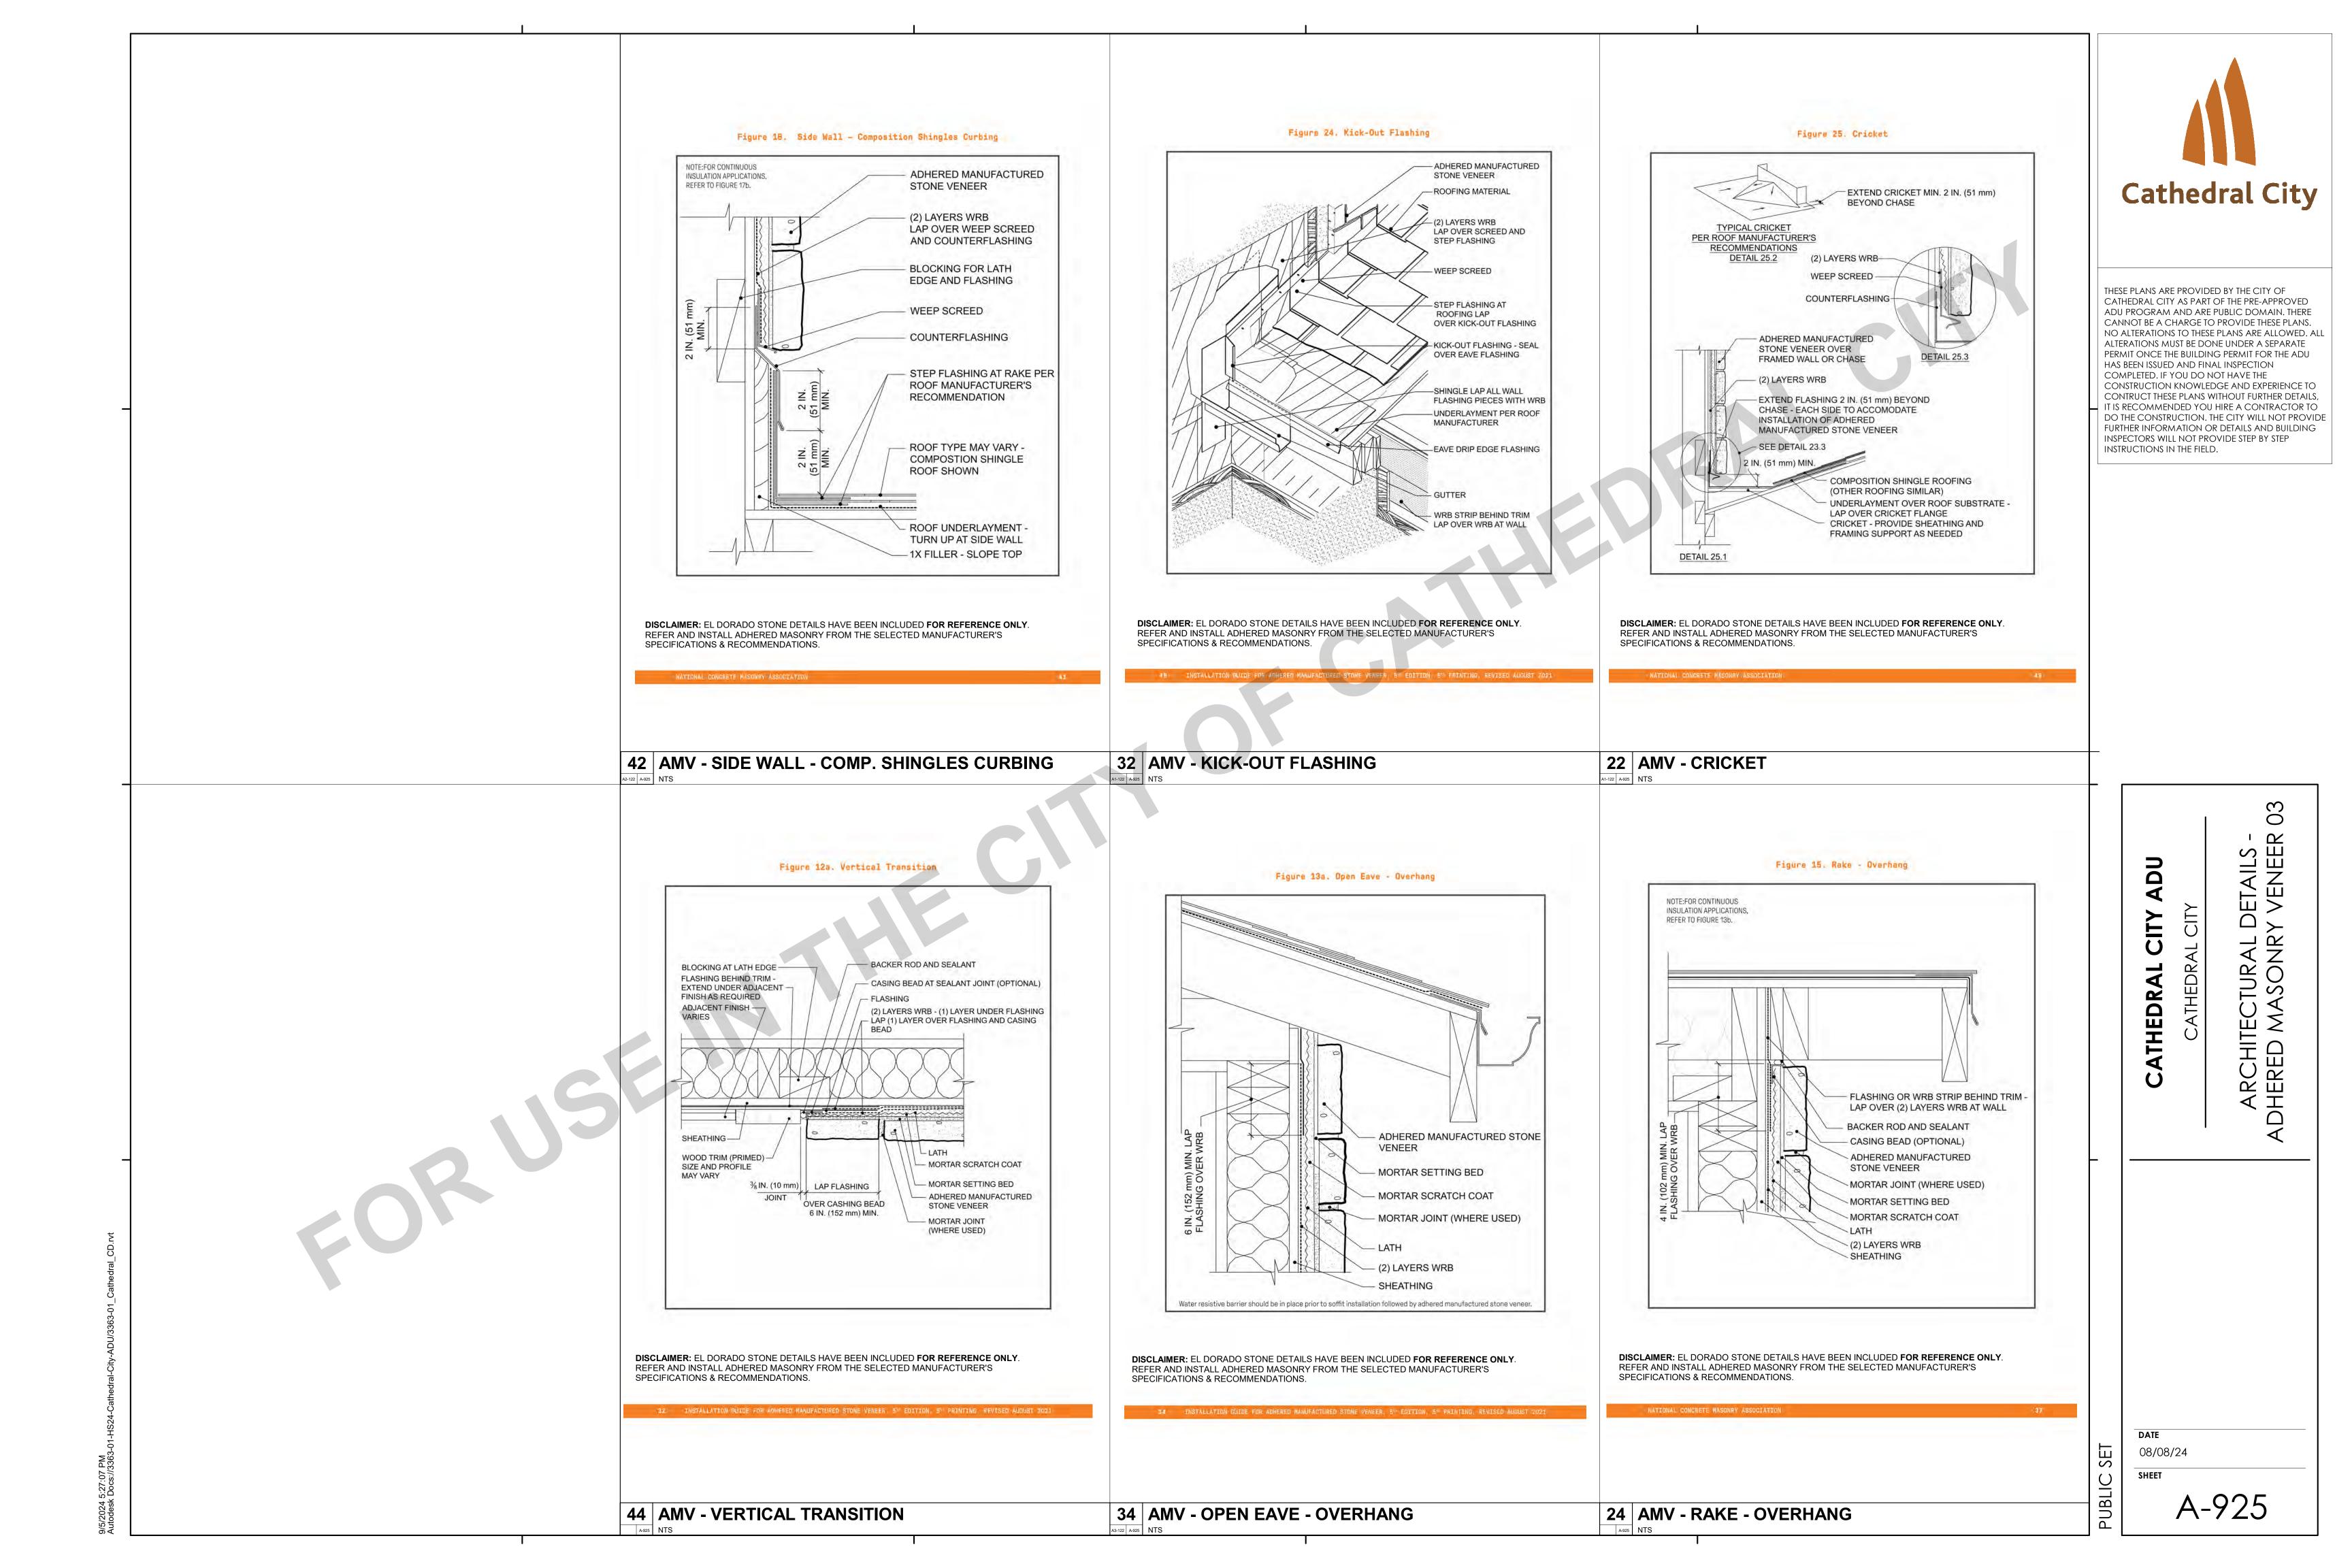

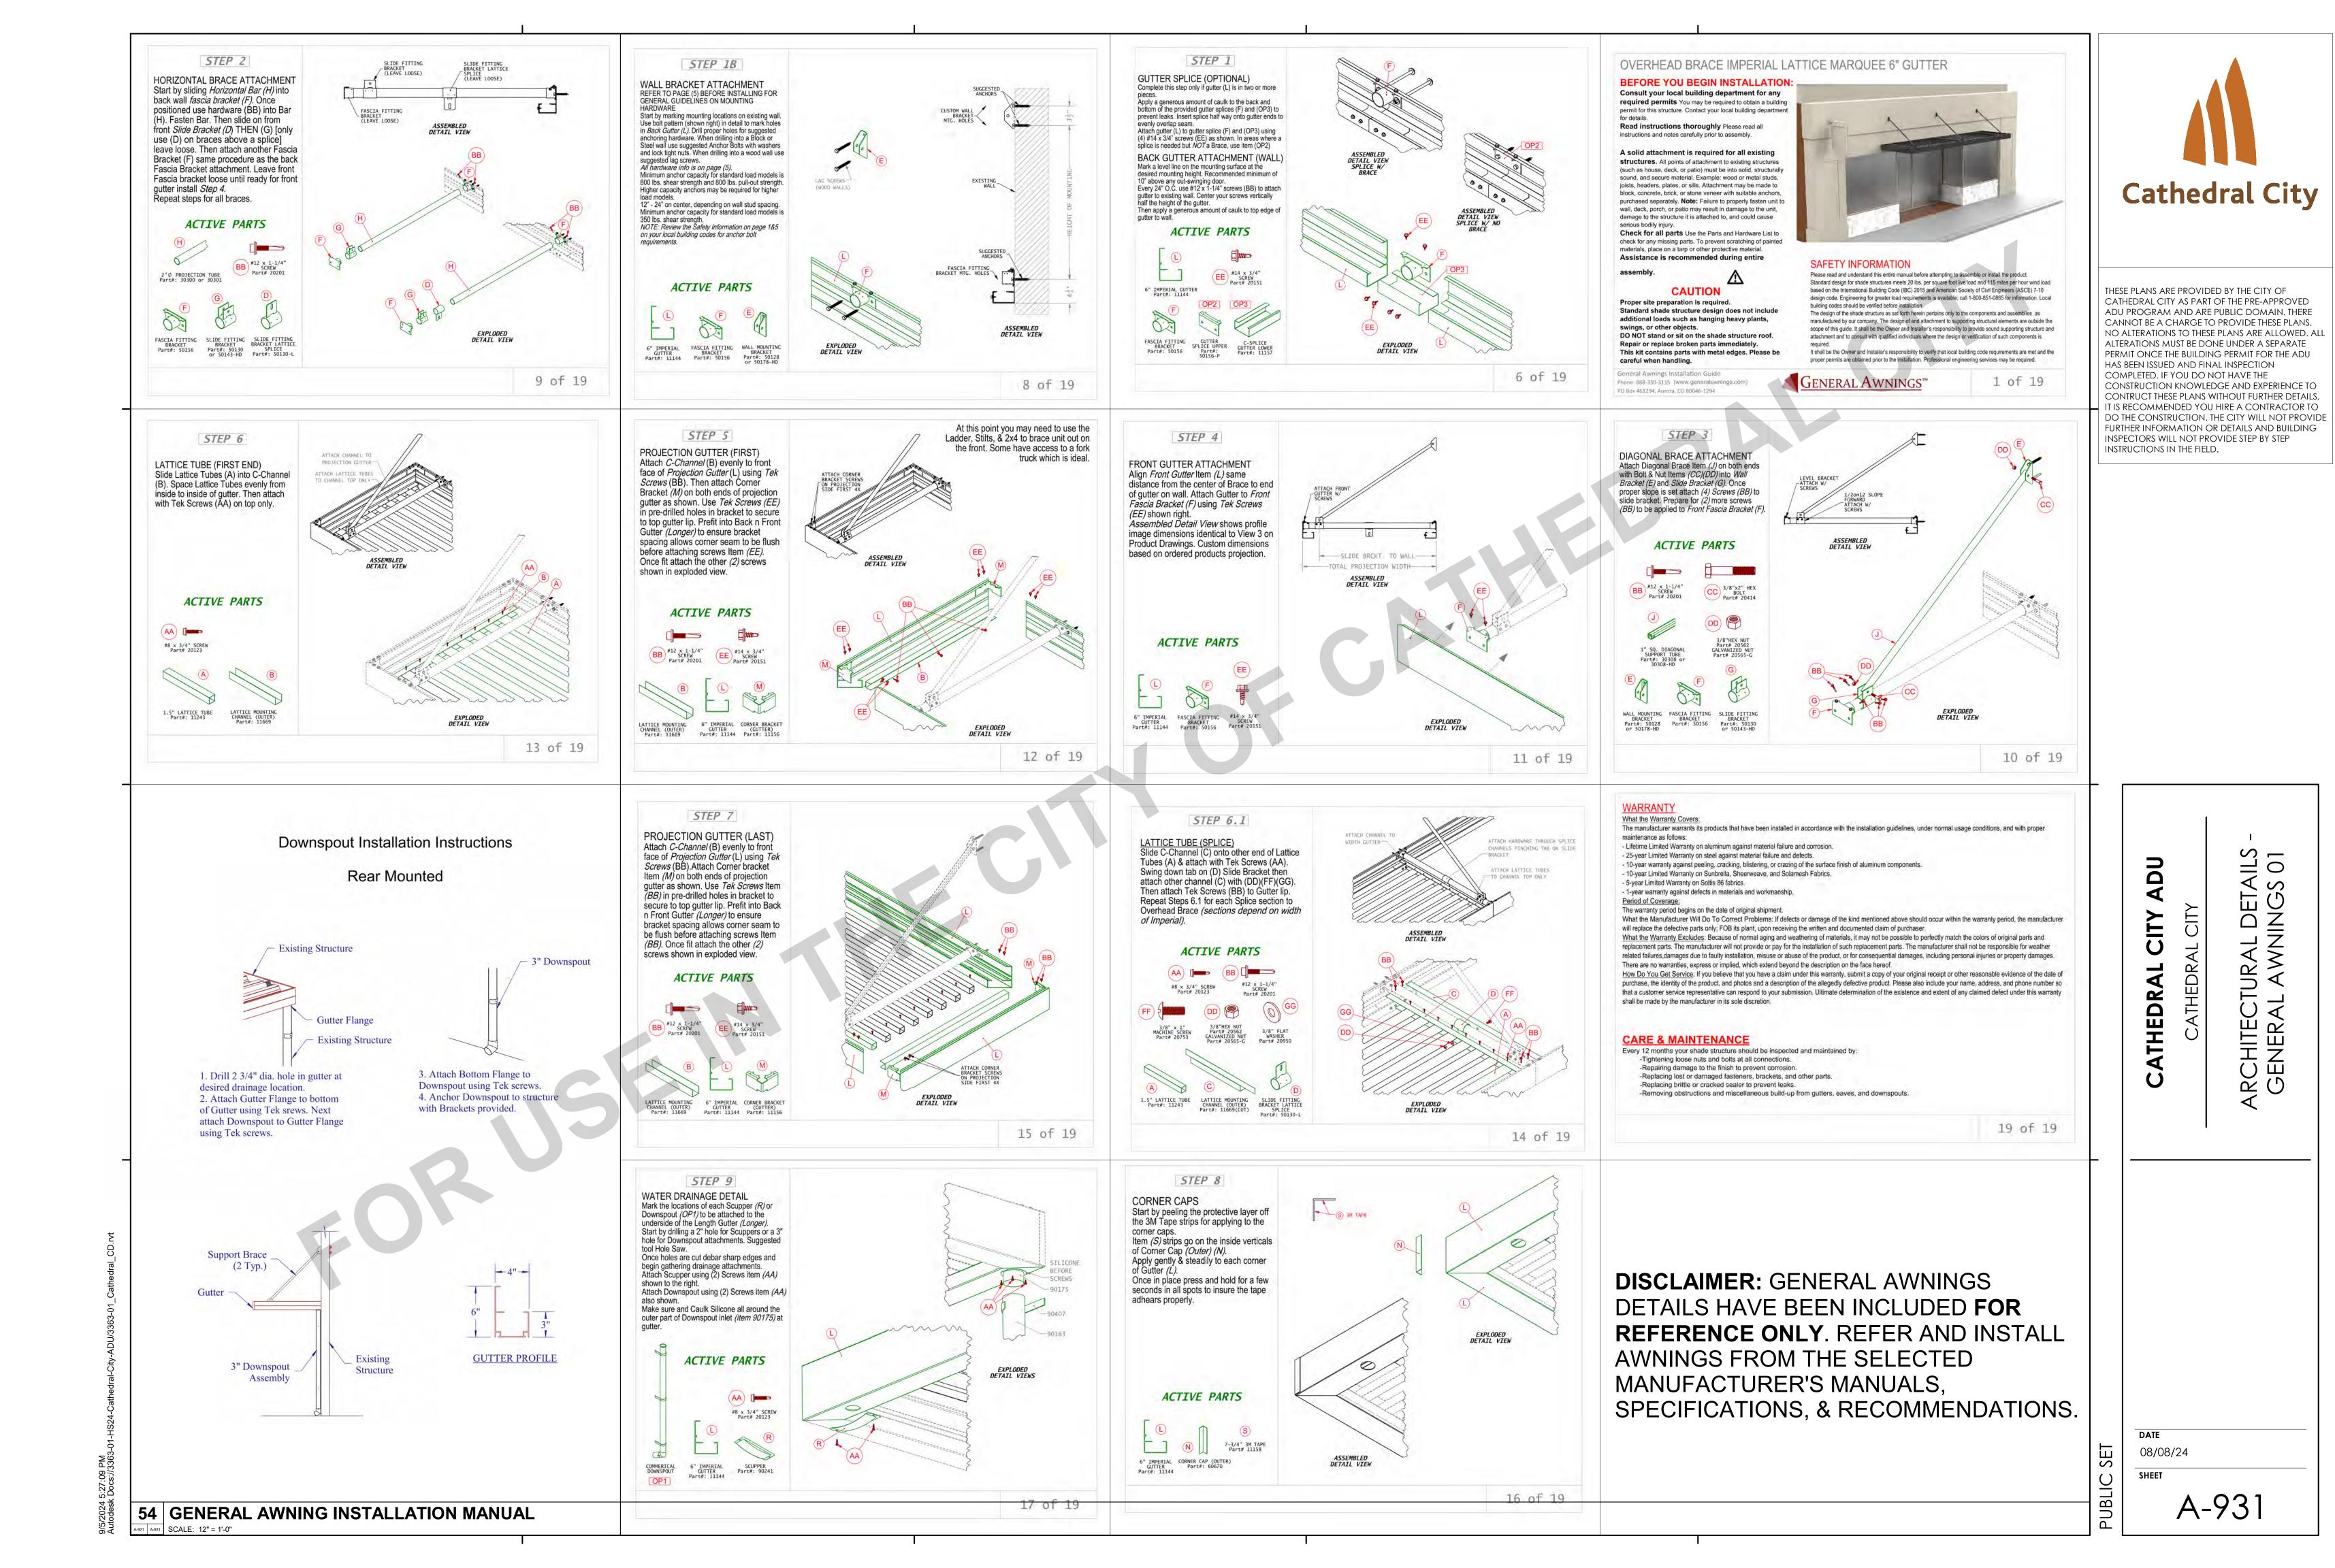

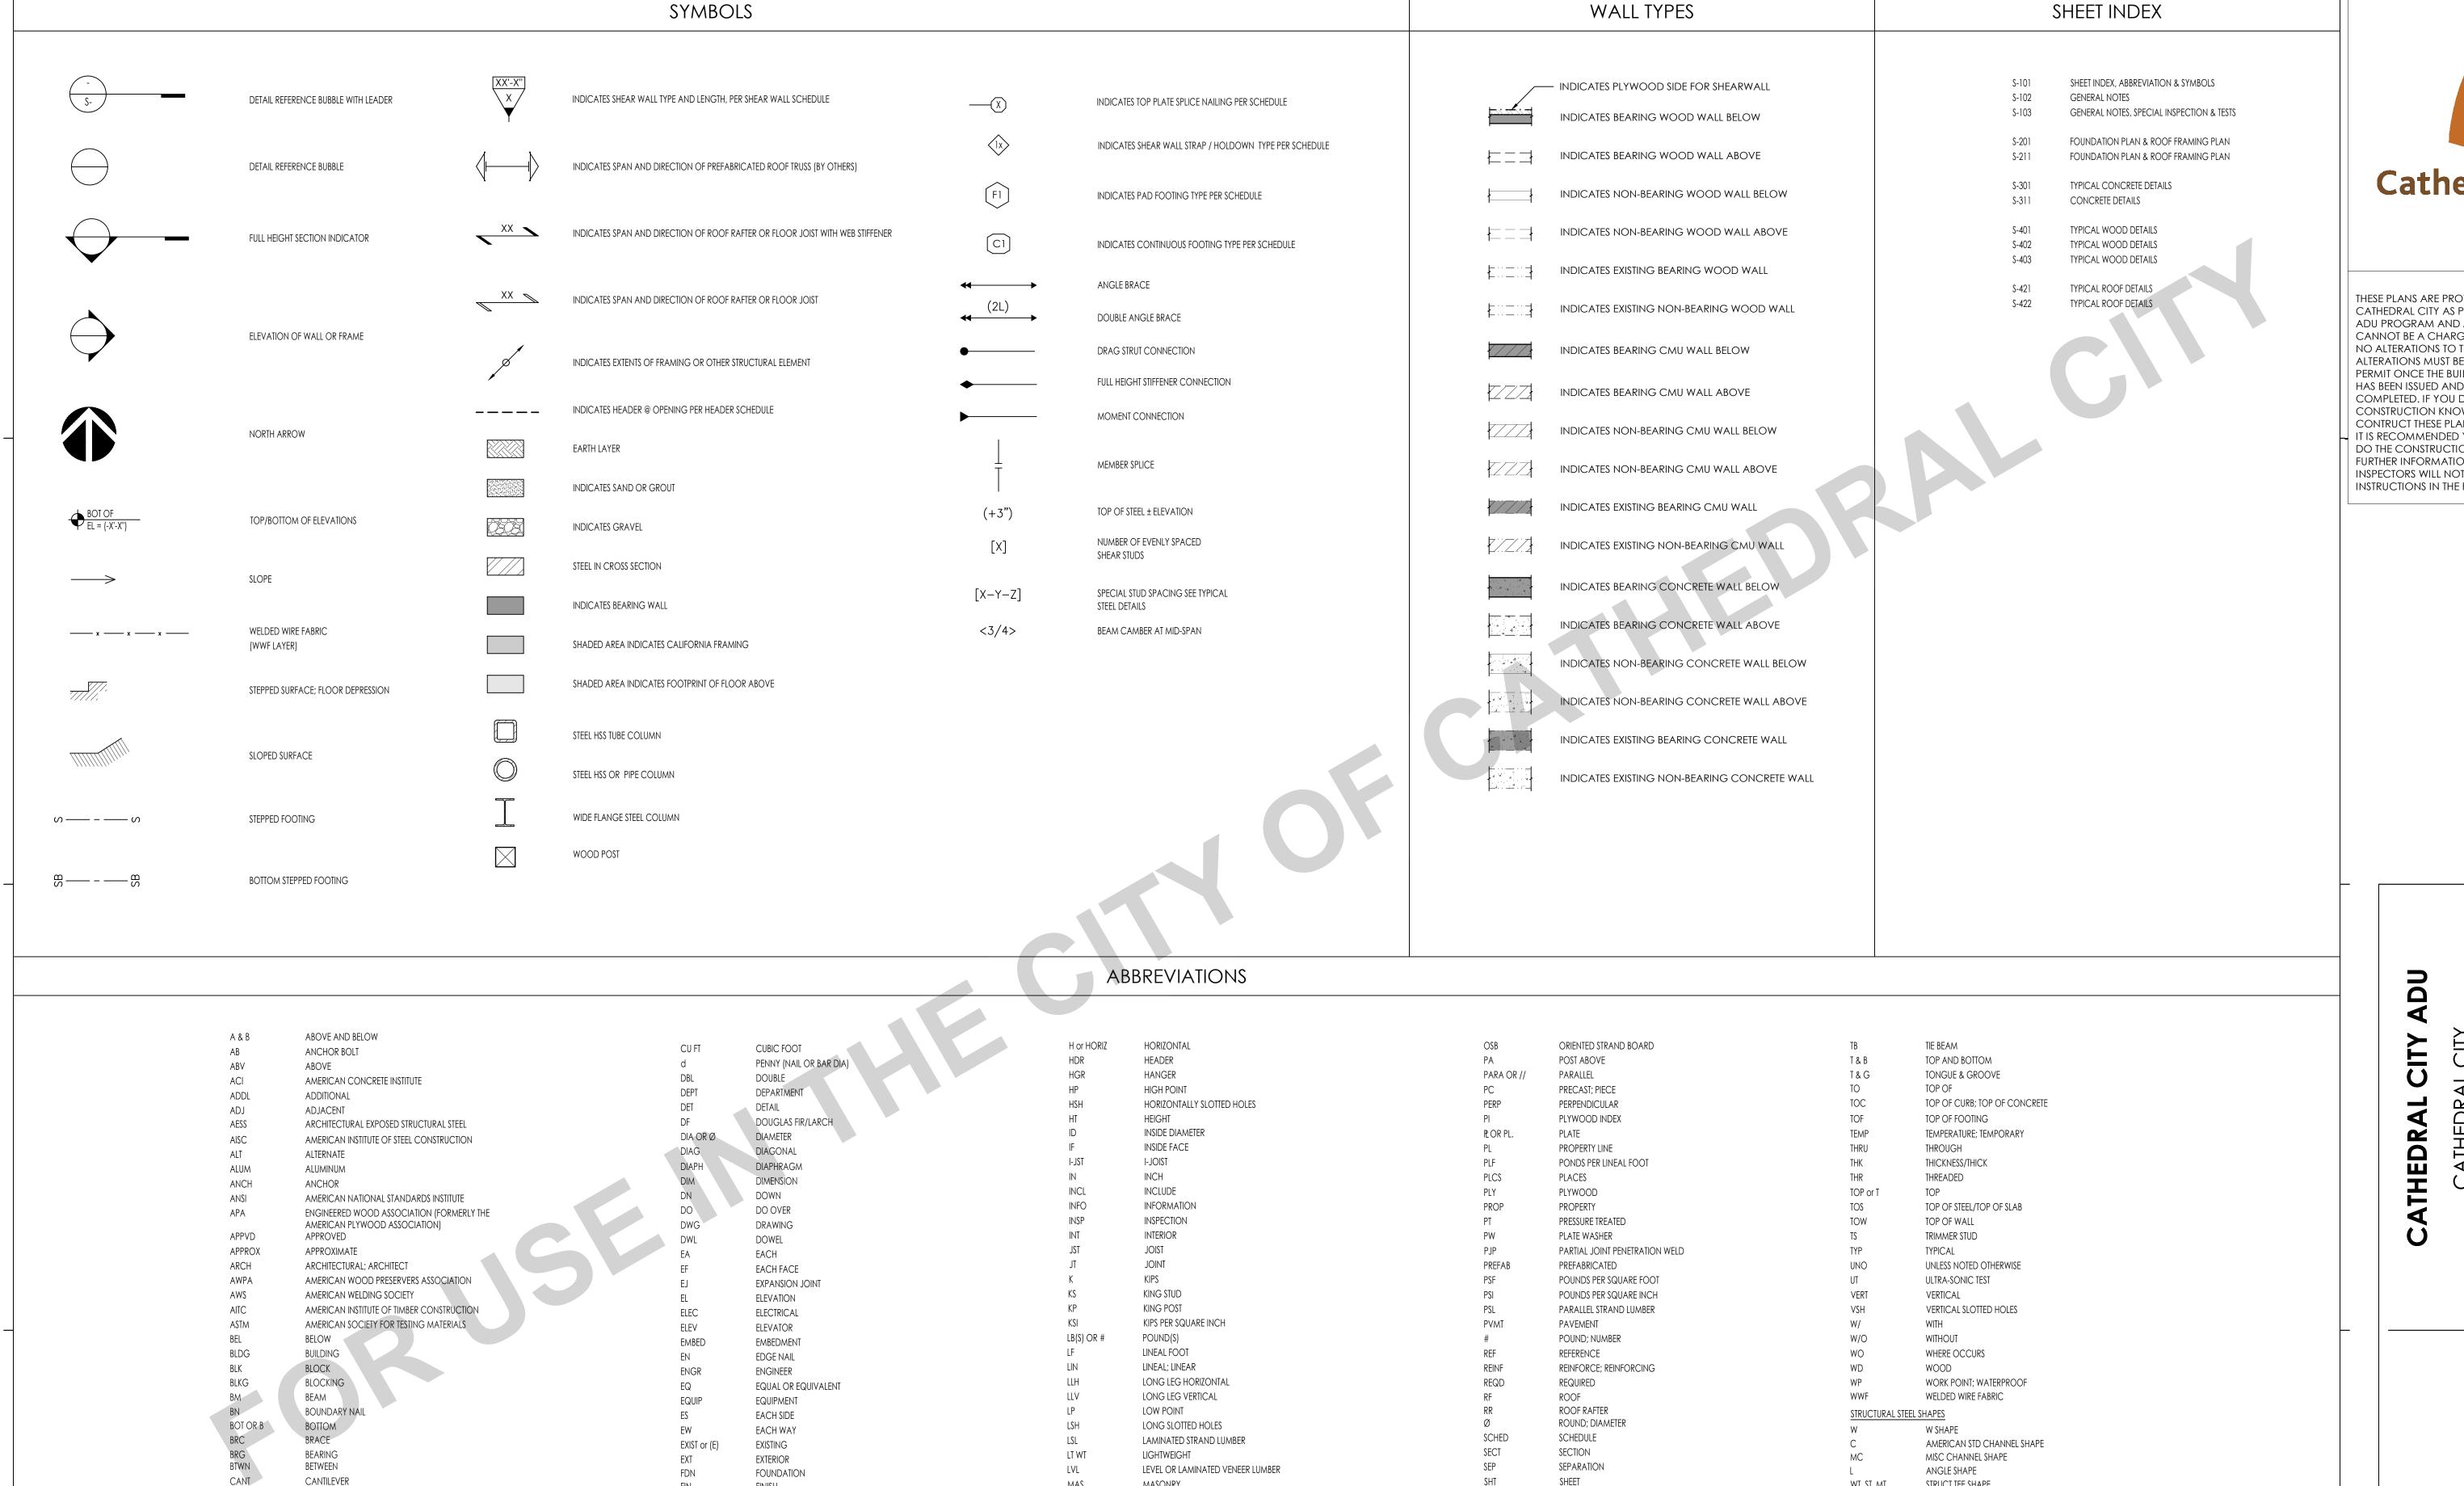

MAS

MATL

MAX

MECH

MFR

MISC

NO or #

NTS

OC

OH

OPNG

OPP

ORIG

MB

FINISH

FLG

FLR

FOC

FOM

FOS

FOW

FTA

FTG

GA

GB

GLB

GR

GRND

GALV

FRMG

FLOOR JOIST

FLANGE

FLOOR

FIELD NAIL

FACE OF STUD

FACE OF WALL

FRAMING

FOOT; FEET

FOOTING

GAUGE

GRADE

GROUND

GALVANIZED

GRADE BEAM

GLUED LAMINATED BEAM

FLOOR TIE ABOVE

FACE OF CONCRETE

FACE OF MASONARY

CAM OR C

CC

CG

CIP

CJ

CLR

CMU

COL

COMP

CONC

CONN

CONSTR

CONT

CONTR

CJP

CTR

CTSK

CAMBER

CENTER TO CENTER

CENTER OF GRAVITY

CLEARANCE; CLEAR

CONCRETE MASONRY UNIT

CONNECTION; CONNECT

CONTINUE; CONTINUOUS

COUNTERSINK; COUNTERSUNK

COMPLETE JOINT PENETRATION WELD

CONSTRUCTION JOINT; CONTROL JOINT

CAST-IN-PLACE

CENTER LINE

COLUMN

COMPRESSION

CONSTRUCTION

CONTRACTOR

CENTER

CONCRETE

MASONRY

MATERIAL

MAXIMUM

MACHINE BOLT

MECHANICAL

MANUFACTURER

MINIMUM; MINUTE

MISCELLANEOUS

NOT TO SCALE

OUTSIDE DIAMETER

OUTSIDE FACE

OPPOSITE HAND

OPENING

OPPOSITE

ORIGINAL

ON CENTER

NEW

NORTH

NUMBER

SHTG

SIM

SOG

SPCG

SPECS

SQ

STD

STGR

STIFF

STIRR

STRUCT

SHEATHING

SLAB ON GRADE

SPECIFICATIONS

STAINLESS STEEL

SHORT SLOTTED HOLES

SHEAR NAIL

SPACING

SQUARE

STANDARD

STAGGER

STIFFENERS

STRUCTURAL

SHEAR WALL

SYMMETRICAL

STIRRUP

STEEL

SIMILAR

Cathedral City

THESE PLANS ARE PROVIDED BY THE CITY OF CATHEDRAL CITY AS PART OF THE PRE-APPROVED ADU PROGRAM AND ARE PUBLIC DOMAIN. THERE CANNOT BE A CHARGE TO PROVIDE THESE PLANS. NO ALTERATIONS TO THESE PLANS ARE ALLOWED. ALL ALTERATIONS MUST BE DONE UNDER A SEPARATE PERMIT ONCE THE BUILDING PERMIT FOR THE ADU HAS BEEN ISSUED AND FINAL INSPECTION COMPLETED. IF YOU DO NOT HAVE THE CONSTRUCTION KNOWLEDGE AND EXPERIENCE TO CONTRUCT THESE PLANS WITHOUT FURTHER DETAILS, IT IS RECOMMENDED YOU HIRE A CONTRACTOR TO DO THE CONSTRUCTION. THE CITY WILL NOT PROVIDE FURTHER INFORMATION OR DETAILS AND BUILDING INSPECTORS WILL NOT PROVIDE STEP BY STEP INSTRUCTIONS IN THE FIELD.

EX, SYMBOLS $\overline{\Box}$ \ll SHEET I ABBREVIATION

08/08/24

SHEET

S

PUBLIC

WT, ST, MT

PIPE

PIPE-X

PIPE-XX

STRUCT TEE SHAPE

STANDARD PIPE SHAPE

EXTRA STRONG PIPE SHAPE

DBL EXTRA STRONG PIPE SHAPE

HOLLOW STRUCTURAL SECTION

REINFORCING STEEL

MORE THAN 18,000 PSI.

- REINFORCING BARS SHALL CONFORM TO THE REQUIREMENTS OF CHAPTER 19 OF THE CODE AND WITH THE PROVISIONS OF ACI 318-19, ASTM A706, GRADE 60 UNO. ASTM A615 GR 60 STEEL MAY BE SUBSTITUTED FOR ASTM A706 GR60 STEEL PER ACI 318-19 SECTION 20.2.2.5 PROVIDED THE FOLLOWING CONDITIONS ARE MET:
- A. THE ACTUAL YIELD STRENGTH BASED ON MILL TESTS DOES NOT EXCEED THE SPECIFIED YIELD STRENGTH BY
- B. THE RATIO OF THE ACTUAL ULTIMATE TENSILE STRESS TO THE ACTUAL YIELD STRENGTH IS NOT LESS THAN
- C. WHERE REINFORCEMENT COMPLYING WITH ASTM A615 IS TO BE WELDED, CHEMICAL TESTS SHALL BE PERFORMED TO DETERMINE WELDABILITY IN ACCORDANCE WITH SECTION 26.6.4 OF ACI 318-19.
- 2. BARS SHALL BE CLEAN OF RUST, GREASE, OR OTHER MATERIALS LIKELY TO IMPAIR BOND. ALL REINFORCING BAR BENDS SHALL BE MADE COLD.
- 3. WELDED WIRE REINFORCEMENT (WWR), PLAIN OR DEFORMED, SHALL CONFORM TO ASTM A185. WELDED DEFORMED WIRE REINFORCEMENT (WWR) SHALL CONFORM TO ASTM A 1064. ALL WWR FOR STAIR PANS AND ALL WWR FOR CONCRETE FILL ON METAL DECK TO BE PLAIN WWR. PROVIDE LAPS PER ACI 318-19 SECTION 25.5.3 OR 25.5.4 MINIMUM. WWR SHALL BE SUPPORTED ON APPROVED CHAIRS.
- REINFORCING BAR LAP SPLICES SHALL BE MADE AS INDICATED ON THE DRAWINGS, LAP ALL HORIZONTAL BARS AT CORNERS AND INTERSECTIONS. STAGGER ALL SPLICES UNLESS NOTED OTHERWISE ON PLANS.
- A. MINIMUM LAP SPLICE LENGTH FOR REINFORCING STEEL BARS IN CONCRETE SHALL BE PER ACI 318-19 SECTION 25.5.2 AND THE REINFORCING SCHEDULE ON THE DRAWINGS.
- B. MINIMUM LAP SPLICE LENGTH FOR REINFORCING STEEL BARS IN MASONRY SHALL BE PER TMS 042-16 SECTION 6.1.6.1.1 AND THE REINFORCING SCHEDULE ON THE DRAWINGS.
- 5. ALL BARS SHALL BE MARKED SO THEIR IDENTIFICATION CAN BE MADE WHEN THE FINAL IN-PLACE INSPECTION IS MADE. ALL REINFORCING CONFORMING TO DIFFERING ASTM SPECIFICATIONS AND/OR OF DIFFERING GRADES SHALL BE CLEARLY MARKED TO DIFFERENTIATE THEM FROM OTHER REINFORCING STEEL IF CONCURRENTLY PRESENT ON SITE.
- WHERE WELDING OF REINFORCING IS APPROVED BY THE STRUCTURAL ENGINEER, IT SHALL BE DONE BY AWS CERTIFIED WELDERS USING E80XX OR APPROVED ELECTRODES. WELDING PROCEDURES SHALL CONFORM TO THE REQUIREMENTS OF STRUCTURAL WELDING CODE- REINFORCING STEEL", AWS-D1.4-15. REINFORCING BARS TO BE WELDED SHALL CONFORM TO THE REQUIREMENTS OF ASTM A706.
- REINFORCING STEEL SHALL BE ACCURATELY PLACED, ADEQUATELY SUPPORTED AND SHALL BE SECURED AGAINST DISPLACEMENT, AND TIED BEFORE THE CONCRETE IS PLACED DURING CONSTRUCTION WITHIN PERMITTED TOLERANCES. ADEQUATE SUPPORTS ARE ALSO NECESSARY TO KEEP THE REINFORCING STEEL AT THE PROPER DISTANCE FROM THE FORMS. USE WIRE BAR SUPPORTS, PRECAST CONCRETE SUPPORTS, SPACERS, BOLSTERS, REINFORCEMENT OR OTHER MEANS OF SUPPORT PER THE "CRSI MANUAL OF STANDARD PRACTICE", LATEST EDITION.
- 8. REINFORCING STEEL SHALL BE DETAILED IN ACCORDANCE WITH THE "CRSI MANUAL OF STANDARD PRACTICE" FOR DETAILING REINFORCED CONCRETE STRUCTURES", LATEST EDITION.
- 9. COMPLETE AND DETAILED REINFORCING PLACEMENT DRAWINGS SHALL BE PREPARED AND SUBMITTED TO THE ARCHITECT FOR APPROVAL BY THE SEOR PRIOR TO FABRICATION IN ACCORDANCE WITH THE SPECIFICATIONS AND APPLICABLE CODES. THESE DRAWINGS SHALL BE AVAILABLE ON THE JOB SITE PRIOR TO PLACING OF CONCRETE. THE REINFORCING PLACEMENT DRAWINGS SHALL INCLUDE ALL PRIMARY REINFOREMENT, LAP SPLICES, TIES, DOWELS, HEADED U-DOWELS, EMBED PLATES, ANCHOR BOLTS, ETC. AREAS OF CONGESTION SHALL BE DETAILED SUFFICIENTLY TO DEMONSTRATE THAT PLACEMENT OF REBAR MEETS SPACING REQUIREMENTS OF ACI 318-19.
- 10. MILL TEST REPORTS FOR GRADE 60 BARS SHALL BE SUBMITTED TO THE INSPECTOR OF RECORD PRIOR TO PLACEMENT OF CONCRETE PER ACI 318-19 SECTION 26.13.2.3 OF THE CODE.
- 11. WHEN REQ'D, INSPECTION OF CONCRETE SHALL INCLUDE INSPECTION DURING INSTALLATION OF REINFORCING STEEL. INSPECTION SHALL BE SCHEDULED SO THAT PLACEMENT OF REINFORCING STEEL, CONDUIT, SLEEVES, AND EMBEDDED ITEMS MAY BE CORRECTED PRIOR TO PLACEMENT OF OVERLYING GRIDS
- 12. CONCRETE PROTECTION FOR REINFORCEMENT

OR REINFORCING STEEL.

1	FOLLOWING MINIMUM CONCRETE COVER SHALL BE PROVIDED FOR FORCEMENT IN CAST-IN-PLACE CONCRETE (NON-PRESTRESSED):	MINIMUM COVER, IN.
A.	CONCRETE CAST AGAINST AND PERMANENTLY EXPOSED TO EARTH	3
В.	CONCRETE EXPOSED TO EARTH OR WEATHER: NO.6 THROUGH NO. 18 BAR NO.5 BAR, W31 OR D31 WIRE & SMALLER	2 1 ½"
C.	CONCRETE NOT EXPOSED TO WEATHER OR IN CONTACT WITH GROUND: SLABS, WALLS, JOISTS: NO.14 AND NO.18 BARS NO.11 BAR & SMALLER BEAMS, COLUMNS: PRIMARY REINFORCEMENT TIES, STIRRUPS, SPIRALS	1 ½" 3½" 1 ½"

13. MECHANICAL BAR SPLICE CONNECTIONS SHALL CONFORM TO THE REQUIREMENTS OF ACI 318-19 SECTION 25.5.7 USE OF MECHANICAL CONNECTIONS SHALL BE APPROVED BY THE STRUCTURAL ENGINEER. SPLICES MUST BE TESTED AS INDICATED IN THE CONCRETE REINFORCEMENT SPECIFICATION. ACCEPTABLE PRODUCTS

LENTON STANDARD COUPLERS (IAPMO-ES 0129) LENTON FORM SAVERS, TYPE SA (IAPMO-ES 0129) LENTON WELDABLE HALF COUPLERS (IAPMO-ES 0129) LENTON LOCK COUPLERS PER (IAPMO-ES 0129)

SECTION 18.2.7 & 18.12.7.4

NOTE THAT REBAR ATTACHED TO PLATE USING LENTON WELDABLE HALF COUPLERS SHALL BE ASTM A706 PER IAPMO-ES 0129.

ALL MECHANICAL BAR SPLICE CONNECTIONS IN SPECIAL STRUCTURAL WALLS, SPECIAL MOMENT FRAMES AND CONCRETE DIAPHRAGMS SHALL BE TYPE 2 CONFORMING TO THE REQUIREMENTS OF ACI 318-19

CONCRETE

- ALL CONCRETE CONSTRUCTION SHALL CONFORM WITH CHAPTER 19 OF THE CODE AND WITH THE PROVISIONS OF ACI 318-19.
- 2. CONCRETE MATERIALS SHALL BE IN ACCORDANCE WITH THE FOLLOWING STANDARDS:

MATERIAL	ASTM STANDARD
PORTLAND CEMENT (TYPE II) ^A	C150
CONCRETE AGGREGATES (HARDROCK)	C33
CONCRETE AGGREGATES (LIGHTWEIGHT) ^C	C330
WATER ^B	C1602
COAL FLY ASH OR POZOLLAN (CLASS F)	C618
NATURAL OR MANUFACTURED SAND	C33
SLAG	C989

- A. FOR SOILS WITH HIGH CONCENTRATIONS OF SULFATES (EXPOSURES S2 OR S3 PER ACI 318-19 TABLE 19.3.2.1) PORTLAND CEMENT SHALL BE TYPE V. VERIFY WITH PROJECT GEOTECHNICAL REPORT.
- B. WATER SHOULD ONLY BE ADDED AT THE BATCH PLANT. IN NO CASE SHALL THE DESIGN WATER/ CEMENT RATIO BE EXCEEDED.
- C. PUMICE AGGREGATE SHALL NOT BE USED.
- 3. CONCRETE MIXES SHALL BE PROPORTIONED BASED ON SECTION 26.4.3 OF ACI 318-19, WHICH REFERENCES ACI 301-20 ARTICLE 4.2.3. MIX DESIGNS SHALL INCLUDE DOCUMENTATION OF MIX AVERAGE COMPRESSIVE STRENGTH THROUGH FIELD TEST DATA OR TRAIL MIXTURES IN ACCORDANCE WITH ACI 301-20 ARTICLE 4.2.3.4. SCHEDULE OF STRUCTURAL CONCRETE STRENGTHS AND LOCATIONS (UNO):

LOCATION IN STRUCTURE	MINIMUM STRENGTH (PSI)	DENSITY (PCF)	MAX SLUMP (IN±1)	MAX WATER/CEMENT RATIO	SLAG/ FLY ASH ^A (MAX)
CONCRETE FOUNDATIONS, GRADE BEAMS, TIE BEAMS	2,500	150	4	0.5	0.15
CONCRETE SLAB ON GRADE	2,500	150	4	0.45	0.15

- A. AS MEASURED BY CEMENTITIOUS WEIGHT
- READY MIXED CONCRETE SHALL BE MIXED AND DELIVERED IN ACCORDANCE WITH THE REQUIREMENTS OF ASTM C94 OR C685.
- 5. DEPOSITING AND CONVEYING OF CONCRETE SHALL CONFORM TO SECTION 26.5 OF ACI 318-19 AND PROJECT SPECIFICATIONS.
- 6. ALL CONCRETE SURFACES AGAINST WHICH NEW CONCRETE IS TO BE PLACED SHALL BE CLEANED AND ROUGHENED TO 1/4" AMPLITUDE.
- 7. ALL REINFORCING BARS, ANCHOR BOLT HOLDOWNS AND OTHER CONCRETE INSERTS SHALL BE WELL SECURED AND TIED IN POSITION PRIOR TO PLACING CONCRETE. IN NO CASE SHALL ANY REINFORCING BARS, ANCHOR BOLTS, HOLDOWNS OR OTHER CONCRETE INSERTS BE "WET SET" OR "WET-STABBED" INTO CONCRETE DURING
- 8. PROVIDE SLEEVES FOR PLUMBING AND ELECTRICAL OPENINGS IN CONCRETE BEFORE PLACING. DO NOT CUT ANY REINFORCING WHICH MAY CONFLICT. CORING IN CONCRETE IS NOT PERMITTED WITHOUT SEOR APPROVAL. NOTIFY THE SEOR IN ADVANCE OF CONDITIONS NOT SHOWN ON THE DRAWINGS, SEE THE DRAWINGS FOR ADDITIONAL RESTRICTIONS ON THE PLACEMENT OF OPENINGS IN SLABS AND WALLS.
- PIPES EMBEDDED IN CONCRETE:
- A. CONCRETE
 - a. PIPES LARGER THAN 1-1/2" DIAMETER SHALL NOT BE EMBEDDED IN STRUCTURAL CONCRETE EXCEPT WHERE SPECIFICALLY APPROVED BY SEOR. b. NO CONDUITS SHALL BE PLACED IN CONCRETE FILL OVER METAL DECK.
 - C. PIPES SHALL NOT DISPLACE OR INTERRUPT REINFORCING BARS.

 - d. DO NOT STACK CONDUITS, SPACE EMBEDDED PIPES AND CONDUITS AT A MINIMUM OF 3 DIAMETERS CLEAR FROM OTHER EMBEDDED PIPES/CONDUITS AND REBAR.

FOUNDATION

- 1. GEOTECHNICAL INFORMATION AND FOUNDATION DESIGN IS BASED ON THE FOLLOWING: DESIGN LATERAL SOIL LOADS ARE IN ACCORDANCE WITH 2022 CBC TABLE 1610.1 ALLOWABLE FOUNDATION BEARING AND LATERAL PRESSURES ARE IN ACCORDANCE WITH 2022 CBC TABLE 1806.2
- C. VALUES LISTED SHALL BE VERIFIED BY A LICENSED GEOTECHNICAL ENGINEER

		ALLOWABLE LATE	ral resistance ^b
ELEMENT	ALLOWABLE BEARING CAPACITY (PSF) ^A	PASSIVE RESISTANCE (PSF/FT BELOW GRADE) ^E	COHESION (PSF)
CONT FOOTING	1,500	100	120

- A. THE ALLOWABLE CAPACITY MAY BE INCREASED BY ONE-THIRD WHEN CONSIDERING LOADS OF SHORT DURATION SUCH AS WIND OR SEISMIC FORCES.
- B. THE ALLOWABLE LATERAL RESISTANCE CAN BE TAKEN AS THE SUM OF THE FRICTIONAL RESISTANCE AND PASSIVE RESISTANCE.
- C. THE UPPER 0 FOOT OF SOIL NOT PROTECTED BY PAVEMENT SHALL BE NEGLECTED WHEN CALCULATING PASSIVE RESISTANCE.
- D. COMPACTED FILL SHOULD BE PREPARED AS FOLLOWS: A MIN OF 12" OF COMPACTED FILL SHALL BE PROVIDED, COMPACTED TO A MIN OF 90 PERCENT MODIFIED PROCTOR IN ACCORDANCE WITH ASTM D 1557 (2022 CBC 1804.6)
- E. MAY BE DOUBLED FOR ISOLATED POLES PER 2022 CBC 1806.3.4
- 4. WHERE NOT SHOWN ON THE DRAWINGS, CONTRACTOR TO PROVIDE FOR DESIGN AND INSTALLATION OF ALL CRIBBING, SHEATHING AND SHORING REQUIRED AND SHALL BE SOLELY RESPONSIBLE FOR ALL EXCAVATION PROCEDURES INCLUDING LAGGING, SHORING, AND PROTECTION OF ADJACENT PROPERTY, STRUCTURES, STREETS, AND UTILITIES IN ACCORDANCE WITH ALL NATIONAL, STATE AND LOCAL SAFETY ORDINANCES.
- 5. CONTRACTOR TO PROVIDE FOR DE-WATERING OF EXCAVATIONS FROM SURFACE WATER, GROUND WATER AND/OR SEEPAGE.
- 6. EXCAVATION FOR FOOTINGS SHALL BE APPROVED BY THE INSPECTOR OR GEOTECHNICAL ENGINEER PRIOR TO PLACING CONCRETE AND REINFORCING.
- 7. ALL EXCAVATIONS SHALL BE PROPERLY BACKFILLED. DO NOT PLACE BACKFILL BEHIND RETAINING WALLS BEFORE CONCRETE OR GROUT HAS ATTAINED FULL DESIGN STRENGTH, CONTRACTOR SHALL PROVIDE FOR DESIGN, PERMITS AND INSTALLATION OF SUCH BRACING.
- 8. EXCAVATIONS SHALL BE CUT SQUARE AND SMOOTH, WITH LEVEL BOTTOMS.
- 9. FOOTING BACKFILL AND UTILITY TRENCH BACKFILL WITHIN BUILDING AREA SHALL BE MECHANICALLY COMPACTED IN LAYERS IN ACCORDANCE WITH THE GEOTECHNICAL INVESTIGATION REPORT AND APPROVED BY THE GEOTECHNICAL ENGINEER. FLOODING WILL NOT BE PERMITTED. ALL FILLS USED TO SUPPORT FOUNDATIONS SHALL BE INSPECTED BY THE GEOTECHNICAL ENGINEER REPRESENTATIVE PER SECTION 1705.6 OF THE CODE.
- 10. ALL ABANDONED FOOTINGS, UTILITIES, ETC. SHALL BE REMOVED. NEW FOOTINGS MUST EXTEND INTO UNDISTURBED SOILS.
- 11. PIPES WITHIN THE ZONE OF INFLUENCE OF BUILDING OR SITE ELEMENT FOUNDATIONS SHALL BE ENCASED IN LEAN CONCRETE AT THE DIRECTION OF THE GEOTECHNICAL ENGINEER OF RECORD.

EXISTING CONDITIONS

- 1. ALL INFORMATION SHOWN ON THE PLANS RELATIVE TO EXISTING CONDITIONS IS GIVEN AS THE BEST PRESENT KNOWLEDGE FROM PLANS SUPPLIED BY THE OWNER, BUT WITHOUT GUARANTEE OF ACCURACY.
- 2. WHERE ACTUAL CONDITIONS ARE NOT IN ACCORDANCE WITH THE INFORMATION PRESENTED, THE ARCHITECT AND/OR STRUCTURAL ENGINEER SHALL BE NOTIFIED IMMEDIATELY. NO MODIFICATIONS OF THE PLANS FOR NEW CONSTRUCTION SHALL BE MADE WITHOUT THE WRITTEN APPROVAL OF THE ARCHITECT.

EXISTING UNDERGROUND UTILITIES

- THE ARCHITECT AND ENGINEERS ARE NOT RESPONSIBLE FOR THE LOCATIONS OF EXISTING UNDERGROUND UTILITIES WHETHER OR NOT SHOWN ON THE DRAWINGS. DRAWINGS, IF ANY, IS APPROXIMATE. THE CONTRACTOR SHALL EXERCISE EXTREME CAUTION IN EXCAVATING AND TRENCHING ON THE SITE. THE CONTRACTOR SHALL IMMEDIATELY NOTIFY THE ARCHITECT AND/OR STRUCTURAL ENGINEER SHOULD ANY SUCH UNIDENTIFIED CONDITIONS BE DISCOVERED.
- THE CONTRACTOR SHALL BE RESPONSIBLE FOR ANY DAMAGES WHICH MAY RESULT FROM HIS FAILURE TO EXACTLY LOCATE AND PRESERVE ALL EXISTING UNDERGROUND UTILITIES.
- AN UNDERGROUND SERVICE ALERT INQUIRY IDENTIFICATION NUMBER MUST BE OBTAINED AT LEAST TWO WORKING DAYS BEFORE STARTING WORK WITH THIS PERMIT.
- A. FOR PROJECTS IN SOUTHERN CALIFORNIA TELEPHONE NO. 1-800-422-4133. B. FOR PROJECTS IN NORTHERN CALIFORNIA TELEPHONE NO. 1-800-227-2600.

DEMOLITION

- 1. ALL DEMOLITION SHALL BE CARRIED ON IN SUCH A WAY AS NOT TO DAMAGE EXISTING ELEMENTS, WHICH ARE TO REMAIN IN THE FINISHED STRUCTURE.
- 2. ALL ELEMENTS OF THE STRUCTURE, WHICH ARE TO REMAIN, AND WHICH ARE DAMAGED DURING DEMOLITION WORK SHALL BE REPLACED AT NO ADDITIONAL COST. EXISTING ELEMENTS SHALL BE PROTECTED TO THE FULLEST EXTENT POSSIBLE, IN ORDER TO MITIGATE DAMAGE.
- 3. CONTRACTOR IS REPONSIBLE FOR REMOVAL AND REPLACEMENT OF ALL EXISTING ELEMENTS THAT ARE NECESSARY FOR THE INSTALLATION OF ALL NEW WORK.
- 4. WHERE EXISTING PARTITION WALLS ARE TO BE DEMOLISHED, CONTRACTOR SHALL VERIFY WALLS ARE NON-BEARING PRIOR TO DEMOLITION. IF WALLS ARE FOUND TO BE BEARING, CONTRACTOR SHALL NOTIFY ARCHITECT IMMEDIATELY

DESIGN INFORMATION

1. DEAD LOADS:

	DEAD LOADS	
LOCATIONS		uniform (PSF)
ROOF:	CLAY TILE OVER PRE-FAB TRUSS	28
EXTERIOR BEARING WALLS:	2x STUDS W/ STUCCO EXT FINISH + INT GYP BOARD	18
INTERIOR BEARING WALLS:	2x STUDS W/ GYP BOARD EACH FACE	10
INTERIOR NON BEARING WALLS:	2x STUDS W/ GYP BOARD EACH FACE	9

2. ROOF LIVE LOADS (2022 CBC SECTION 1603.1.2)

ROOF LIVE LOADS			
OCCUPANCY OR USE	UNIFORM (PSF)	CONC. (LBS)	REFERENCE
ROOF ORDINARY FLAT, PITCHED AND CURVED ROOFS (THAT ARE NOT OCCUPIABLE)	20		2022 CBC TABLE 1607.1

3. ROOF SNOW LOADS (2022 CBC SECTION 1603.1.3):

SNOW DESIGN DATA		
PARAMETER	VALUE	REFERENCE
GROUND SNOW LOAD	Pg = 0 PSF	ASCE 7-16 7.2
4. WIND DESIGN DATA (2022 CBC SECTION 1603.1.4) :		

WIND DESIGN DATA				
PARAMETER	VALUE	REFERENCE		
ultimate design wind speed (3-sec gust)	V _{ULT} = 97 MPH	2022 CBC FIG. 1609.3		
NOMINAL DESIGN WIND SPEED (3-SEC GUST)	V _{ASD} = 76 MPH	2022 CBC 1609.3.1		
EXPOSURE CATEGORY	С	2022 CBC 1609.4.3		
INTERNAL PRESSURE COEFFICIENT:	GCpi = ± 0.18	ASCE 7-16 TABLE 26.13-1		

COM	PONENTS & C	CLADDING WINI	D PRESSURES (PSF		
LOCATION		COMPONENT TRIBUTARY AREA (SQ FT)			
LOCATION		10	100	500	
	ZONE 1	-29.2	-22.2	-17.0	
	ZONE 2e	-29.2	-22.2	-17.0	
	ZONE 2n	-46.6	-27.5	-24.0	
ROOF	ZONE 2r	-46.6	-27.5	-24.0	
	ZONE 3e	-46.6	-27.5	-24.0	
	ZONE 3r	-50.9	-34.4	-34.4	
	ALL ZONES	16.0	16.0	16.0	
	ZONE 1	-37.9	-36.2	-34.4	
	ZONE 2e	-37.9	-36.2	-34.4	
OVERHANG	ZONE 2n	-55.3	-44.0	-41.4	
OVERNANG	ZONE 2r	-55.3	-44.0	-41.4	
	ZONE 3e	-65.7	-44.8	-44.8	
	ZONE 3r	-65.7	-44.8	-44.8	
	ZONE 4	-22.2	-19.3	-17.0	
WALL	ZONE 5	-27.5	-21.4	-17.0	
	POSITIVE	20.5	17.0	16.0	

5. EARTHQUAKE DESIGN DATA (2022 CBC SECTION 1603.1.5):

SITE AND OCCUPANCY PARAMETERS				
PARAMETER	VALUE	REFERENCE		
RISK CATEGORY	II	2022 CBC TABLE 1604.5		
SEISMIC IMPORTANCE FACTOR	I = 1.0	ASCE 7-16 TABLE 1.5-2		
MAPPED SPECTRAL RESPONSE ACCELERATIONS:	Ss = 2.625g	2022 CBC 1613.2.1		
MAPPED SPECIKAL RESPONSE ACCELERATIONS.	S ₁ = 1.100g	2022 CBC 1613.2.1		
SITE CLASS	D (DEFAULT)	2022 CBC 1613.2.2		
SPECTRAL RESPONSE COEFFICIENTS:	S DS = 2.100g	2022 CBC 1613.2.4		
SPECIKAL RESPONSE COEFFICIENTS.	S D1 = 1.247g	2022 CBC 1013.2.4		

BUIL	DING PARAMETERS		
PARAMETER	VALUE	REFERENCE	
SEISMIC DESIGN CATEGORY	SDC = E	2022 CBC 1613.2.5	
BASIC SEISMIC FORCE RESISTING SYSTEM	LIGHT FRAME (WOOD) WALLS SHEATHED WITH WOOD STRUCTURAL PANELS RATED FOR SHEAR RESISTANCE	ASCE 7-16 TABLE 12.2-1	
RESPONSE MODIFICATION FACTOR	$R = 6\frac{1}{2}$		
SYSTEM OVERSTRENGTH FACTOR	Ωο = 3		
DEFLECTION AMPLIFICATION FACTOR	Cd = 4		
DESIGN BASE SHEAR	V = 8.9K	ASCE 7-16 12.8.1	
SEISMIC RESPONSE COEFFICIENTS	Cs = 0.323	ASCE 7-16 12.8.1.1	
ANALYSIS PROCEDURE USED	EQUIVALENT LATERAL FORCE PROCEDURE	ASCE 7-16 12.8	

6. GEOTECHNICAL INFORMATION (2022 CBC SECTION 1603.1.6): REFER TO FOUNDATION GENERAL NOTES

GENERAL

- 1. ALL WORK SHALL CONFORM TO THE MINIMUM STANDARDS OF THE FOLLOWING CODES AND STANDARDS:
- A. 2022 CALIFORNIA BUILDING CODE, PART 2, VOLUME 2 OF 2, AND TITLE 24 C.C.R. 2022 EDITION AND LATEST REVISIONS (INCLUDING SUPPLEMENTS AND ERRATA) HEREIN REFERRED TO AS "THE CODE".
- B. ANY OTHER REGULATING AGENCIES WHICH HAVE AUTHORITY OVER ANY PORTION OF THE WORK,

INCLUDING THE STATE OF CALIFORNIA DIVISION OF OCCUPATIONAL SAFETY AND HEALTH (CAL/OSHA).

- C. CODES & STANDARDS REFERENCED IN THE CODE OR LISTED IN THESE NOTES AND SPECIFICATIONS.
- ALL DRAWINGS ARE CONSIDERED TO BE A PART OF THE CONTRACT DOCUMENTS. THE CONTRACTOR SHALL BE RESPONSIBLE FOR THE REVIEW AND COORDINATION OF ALL DRAWINGS AND SPECIFICATIONS PRIOR TO THE START OF CONSTRUCTION. ANY DISCREPANCIES THAT OCCUR SHALL BE BROUGHT TO THE ATTENTION OF THE ARCHITECT PRIOR TO START OF CONSTRUCTION SO THAT A CLARIFICATION CAN BE ISSUED. ANY WORK PERFORMED IN CONFLICT WITH THE CONTRACT DOCUMENTS OR ANY CODE REQUIREMENTS SHALL BE CORRECTED BY THE CONTRACTOR AT THEIR OWN EXPENSE AND AT NO EXPENSE TO THE OWNER OR
- NOTES AND DETAILS ON DRAWINGS SHALL TAKE PRECEDENCE OVER GENERAL NOTES AND TYPICAL DETAILS. WHERE NO DETAILS ARE GIVEN, CONSTRUCTION SHALL BE AS SHOWN FOR SIMILAR WORK.
- 4. THE CONTRACTOR SHALL VERIFY ALL DIMENSIONS PRIOR TO STARTING CONSTRUCTION, THE ARCHITECT SHALL BE NOTIFIED OF ANY DISCREPANCIES OR INCONSISTENCIES. IN NO INSTANCE SHALL DIMENSIONS BE SCALED FROM THE DRAWINGS.
- 5. SEE ARCHITECTURAL DRAWINGS FOR THE FOLLOWING:
- A. SIZE AND LOCATION OF ALL DOOR AND WINDOW OPENINGS, EXCEPT AS NOTED
- B. SIZE AND LOCATION OF ALL INTERIOR AND EXTERIOR NON-BEARING PARTITIONS UNLESS NOTED AND/OR DETAILED ON THE STRUCTURAL DRAWINGS
- C. SIZE AND LOCATION OF ALL CONCRETE CURBS, EQUIPMENT PADS, PITS, FLOOR DRAINS, SLOPES, DEPRESSED AREAS, CHANGE IN LEVEL, CHAMFERS, GROOVES, INSERTS, ETC
- D. SIZE AND LOCATION OF ALL FLOOR AND ROOF OPENINGS EXCEPT AS SHOWN
- FLOOR AND ROOF FINISHES
- F. MISCELLANEOUS DRAINAGE AND WATERPROOFING
- G. ALL FIREPROOFING REQUIREMENTS INCLUDING FIREPROOFING OF STRUCTURAL STEEL
- H. DIMENSIONS NOT SHOWN ON STRUCTURAL DRAWINGS
- 6. SEE MECHANICAL, PLUMBING AND ELECTRICAL DRAWINGS FOR THE FOLLOWING:
- A. PIPE RUNS, SLEEVES, HANGERS, TRENCHES, WALL AND SLAB OPENINGS, ETC., EXCEPT AS SHOWN OR NOTED.
- B. ELECTRICAL CONDUIT RUNS, BOXES, OUTLETS IN WALLS AND SLABS.
- C. CONCRETE INSERTS FOR ELECTRICAL, MECHANICAL OR PLUMBING FIXTURES.
- D. SIZE AND LOCATION OF MACHINE OR EQUIPMENT BASES, ANCHOR BOLTS FOR MOTOR MOUNTS.
- 7. SEE CIVIL DRAWINGS FOR THE FOLLOWING:
- A. HEIGHT AND/OR ELEVATION OF: a. FINISHED SURFACE
- b. TOP OF WALL
- c. TOP OF GRADE
- d. FINISHED GRADE
- e. SLOPE

B. SITE CONCRETE WALKWAYS, CURBS & PAVING

- 8. THE CONTRACT STRUCTURAL DRAWINGS AND SPECIFICATIONS REPRESENT THE FINISHED STRUCTURE. THEY DO
- NOT INDICATE THE METHOD OF CONSTRUCTION. THE CONTRACTOR SHALL PROVIDE ALL MEASURES NECESSARY TO PROTECT THE STRUCTURE DURING CONSTRUCTION. SUCH MEASURES SHALL INCLUDE, BU NOT BE LIMITED TO, BRACING, SHORING FOR LOADS DUE TO CONSTRUCTION EQUIPMENT ETC. THE CONTRACTOR IS RESPONSIBLE FOR PROVISION OF TEMPORARY SHORING AND OTHER CONSTRUCTION AIDS, INCLUDING ALL ENGINEERING OF SUCH SYSTEMS, FOR TEMPORARY SUPPORT OF NEW AND/OR EXISTING STRUCTURAL ELEMENTS AS REQUIRED FOR ERECTION AND OTHER CONTRACTOR'S MEANS AND METHODS OF CONSTRUCTION (UNO). OBSERVATION VISITS TO THE SITE BY THE STRUCTURAL ENGINEER SHALL NOT INCLUDE INSPECTION OF THE ABOVE ITEMS OR CONCERN CONSTRUCTION MEANS AND METHODS OR CONSTRUCTION
- 9. BACKFILL SHALL NOT BE PLACED BEHIND EXTERIOR AND INTERIOR RETAINING WALLS UNTIL THE CONCRETE / CMU HAS ACHIEVED FULL DESIGN STRENGTH. FOR BRACED WALLS SUPPORTED BY STRUCTURAL DIAPHRAGMS. BACKFILL SHALL NOT BE PLACED BEHIND THE WALL UNTIL THE DIAPHRAGM HAS BEEN INSTALLED , AND FOR CONCRETE DIAPHRAGMS, HAS ACHIEVED FULL DESIGN STRENGTH.
- 10. THE CONTRACT STRUCTURAL DRAWINGS SHOW THE BUILDING IN ITS FINAL INTENDED POSITION, CONTRACTOR SHALL MAKE PROVISIONS IN THE LAYOUT OF THE BUILDING TO TAKE INTO ACCOUNTS SHRINKAGE, CREEP,
- 11. OPENINGS, POCKETS, ETC., LARGER THAN 6" SHALL NOT BE PLACED IN CONCRETE SLABS, DECKS, WALLS, UNLESS SPECIALLY DETAILED ON THE STRUCTURAL DRAWINGS. NOTIFY THE STRUCTURAL ENGINEER WHEN Drawings by Others show openings, pockets, etc., larger than 6" not shown on the structural DRAWINGS, BUT WHICH ARE LOCATED IN STRUCTURAL MEMBERS.
- 12. ASTM SPECIFICATIONS ON THE DRAWINGS SHALL BE THE VERSION REFERENCED IN CHAPTER 35 OF THE CODE OR AS REFERENCED IN THE APPLICABLE DESIGN STANDARD.
- 13. CONTRACTOR SHALL INVESTIGATE SITE DURING CLEARING AND EARTHWORK OPERATIONS FOR FILLED EXCAVATIONS OR BURIED STRUCTURES, SUCH AS CESSPOOLS, CISTERNS, FOUNDATIONS, ETC. IF ANY SUCH STRUCTURES ARE FOUND, THE STRUCTURAL ENGINEER AND GEOTECHNICAL ENGINEER SHALL BE NOTIFIED
- 14. CONSTRUCTION MATERIAL SHALL BE SPREAD OUT IF PLACED ON FRAMED ROOF OR FLOOR. LOAD SHALL NOT EXCEED THE DESIGN LIVE LOAD PER SQUARE FOOT. THE CONTRACTOR TO DESIGN AND PROVIDE ADEQUATE SHORING AND/OR BRACING WHERE STRUCTURE HAS NOT ATTAINED DESIGN STRENGTH.
- 15. CONTRACTOR SHALL COORDINATE SHORING WITH DRAWINGS OF RECORD TO INSURE PROVISIONS FOR POCKETS, BLOCKOUTS, OFFSETS, STEPPED FOOTINGS AND ANY OTHER ITEMS AFFECTED BY THE SHORING. SHORING IS NOT THE RESPONSIBILITY OF THE SEOR. CONTRACTOR TO SUBMIT ANY SHORING DESIGN AND DRAWINGS FOR REVIEW AND APPROVAL PRIOR TO INSTALLATION.
- 16. AN UNDERGROUND SERVICE ALERT INQUIRY IDENTIFICATION NUMBER MUST BE OBTAINED AT LEAST TWO WORKING DAYS BEFORE STARTING WORK WITH THIS PERMIT. A. FOR PROJECTS IN SOUTHERN CALIFORNIA TELEPHONE NO. 1-800-422-4133.
- B. FOR PROJECTS IN NORTHERN CALIFORNIA TELEPHONE NO. 1-800-227-2600. 17. EDGE OF SLAB DIMENSIONS TO BE COORDINATED AND VERIFIED BY THE GENERAL CONTRACTOR PRIOR TO FABRICATION.
- 18. THE CONTRACTOR SHALL ALLOW SUFFICIENT TIME FOR THE ENGINEER OF RECORD TO THOROUGHLY REVIEW SUBMITTAL PACKAGE (10 WORKING DAYS, MINIMUM) AND REQUESTS FOR INFORMATION (7 WORKING DAYS MINIMUM)

DIMENSIONS

1. DIMENSIONS SHALL BE DEFINED TO INCLUDE BOTH HORIZONTAL DIMENSIONS AND VERTICAL DIMENSIONS (ELEVATIONS).

- 2. WRITTEN DIMENSIONS SHALL TAKE PRECEDENCE, DRAWINGS SHALL NOT BE SCALED.
- 3. SEE ARCHITECTURAL DRAWINGS FOR DIMENSION NOT NOTED ON STRUCTURAL DRAWINGS.
- 4. SEE ARCHITECTURAL AND/OR CIVIL DRAWINGS FOR FINISH FLOOR ELEVATIONS.
- 5. SEE ARCHITECTURAL DRAWINGS FOR ALL TOP OF SHEATHING AND/OR ROOF ELEVATIONS.
- 6. THE CONTRACTOR SHALL REVIEW AND VERIFY ALL DIMENSIONS PRIOR TO STARTING CONSTRUCTION. THE ARCHITECT SHALL BE NOTIFIED IMMEDIATELY OF ANY DISCREPANCIES OR INCONSISTENCIES.



THESE PLANS ARE PROVIDED BY THE CITY OF CATHEDRAL CITY AS PART OF THE PRE-APPROVED ADU PROGRAM AND ARE PUBLIC DOMAIN. THERE CANNOT BE A CHARGE TO PROVIDE THESE PLANS. NO ALTERATIONS TO THESE PLANS ARE ALLOWED. ALL ALTERATIONS MUST BE DONE UNDER A SEPARATE PERMIT ONCE THE BUILDING PERMIT FOR THE ADU HAS BEEN ISSUED AND FINAL INSPECTION COMPLETED. IF YOU DO NOT HAVE THE CONSTRUCTION KNOWLEDGE AND EXPERIENCE TO CONTRUCT THESE PLANS WITHOUT FURTHER DETAILS, IT IS RECOMMENDED YOU HIRE A CONTRACTOR TO DO THE CONSTRUCTION. THE CITY WILL NOT PROVIDE FURTHER INFORMATION OR DETAILS AND BUILDING INSPECTORS WILL NOT PROVIDE STEP BY STEP INSTRUCTIONS IN THE FIELD.

U

Ш

I

08/08/24

SHEET

S

PUBL

REQUIRED VERIFICATION AND INSPECTIONS

CONCRETE CON CODE TABLE			ON	
SPECIAL INSPECTION OR TEST	CONTINUOUS	PERIODIC	referenced Standard	CBC REFERENCE
3. INSPECT ANCHORS CAST IN CONCRETE		Х	ACI 318: 26.7	
4. INSPECT ANCHORS POST-INSTALLED IN HARDENED CONCRETE MEMBERS (b) (a) ADHESIVE ANCHORS INSTALLED IN HORIZONTALLY OR UPWARDLY INCLINED ORIENTATIONS TO RESIST SUSTAINED TENSION LOADS (b) MECHANICAL ANCHORS AND ADHESIVE ANCHORS NOT DEFINED IN 4.a.	Х	Х	ACI 318: 26.7.1 ACI 318: 26.7.1	_

REQUIRED VERIFICATION AND INSPECTIONS

WOOD CODE CHAPTER 17 AND REFERENCED 2018 NDS AND AWC SDPWS-2021					
SPECIAL INSPECTION OR TEST	CONTINUOUS	PERIODIC	CBC REFERENCE		
3. WOOD LATERAL FORCE-RESISTING SYSTEM WITH FASTENER SPACING OF THE SHEATHING LESS THAN OR EQUAL TO 4" OC. - WOOD SHEAR WALLS - WOOD DIPHRAGMS - DRAG STRUTS - SHEAR PANELS - HOLD-DOWNS		X	1705.12.2 1705.13.2		
4. WOOD LATERAL FORCE-RESISTING SYSTEM WITH FASTENER SPACING OF THE SHEATHING GREATER THAN 4" OC (NOT REQUIRED) - WOOD SHEAR WALLS - WOOD DIAPHRAGMS - DRAG STRUTS - SHEAR PANELS - HOLD-DOWNS			1705.12.2 1705.13.2		

REQUIRED VERIFICATION AND INSPECTIONS

SOILS CODE TABLE 1705.6		
SPECIAL INSPECTION OR TEST	CONTINUOUS	PERIODIC
1. VERIFY MATERIALS BELOW SHALLOW FOUNDATIONS ARE ADEQUATE TO ACHIEVE THE DESIGN BEARING CAPACITY		χ
2. VERIFY EXCAVATIONS ARE EXTENDED TO PROPER DEPTH AND HAVE REACHED PROPER MATERIAL.		Х
3. PERFORM CLASSIFICATION AND TESTING OF COMPACTED FILL MATERIALS		χ
4. VERIFY USE OF PROPER MATERIALS, DENSITIES, AND LIFT THICKNESSES DURING PLACEMENT AND COMPACTION OF COMPACTED FILL.	Х	
5. PRIOR TO PLACEMENT OF COMPACTED FILL, INSPECT SUBGRADE AND VERIFY THAT SITE HAS BEEN PREPARED PROPERLY.		Х

STATEMENT OF SPECIAL INSPECTIONS

THIS STATEMENT OF SPECIAL INSPECTIONS HAS BEEN PREPARED PURSUANT TO SECTION 1704.3 OF THE CODE THIS SECTION DETAILS BOTH REQUIRED SPECIAL INSPECTIONS AND TESTS INCLUDING TESTING PER SECTION 1705 OF THE CODE. THE FOLLOWING SHALL BE OBSERVED DURING THEIR IMPLEMENTATION:

a. Structural verifications, inspections and tests shall be performed in accordance

B. OWNER REQUIREMENTS:

a. THE OWNER OR OWNER'S AGENT SHALL EMPLOY ONE OR MORE APPROVED AGENCIES TO PERFORM INSPECTIONS DURING CONSTRUCTION ON THE TYPES OF WORK LISTED IN SECTION 1705 OF THE CODE AND IN THIS STATEMENT OF INSPECTIONS.

WITH CHAPTER 17 OF THE CODE AND/OR THE APPLICABLE REFERENCE STANDARD.

C. SPECIAL INSPECTOR QUALIFICATIONS: a. THE SPECIAL INSPECTIONS SHALL PROVIDE WRITTEN DOCUMENTATION TO THE BUILDING OFFICIAL DEMONSTRATING HIS OR HER COMPETENCE AND RELEVANT EXPERIENCE OR TRAINING. THE EXPERIENCE OR TRAINING SHALL BE CONSIDERED RELEVANT WHEN THE DOCUMENTED EXPERIENCE OR TRAINING IS RELATED IN COMPLEXITY TO THE SAME TYPE OF SPECIAL INSPECTION ACTIVITIES FOR PROJECTS OF SIMILAR COMPLEXITY AND MATERIAL QUANTITIES.

D. CONTRACTOR REQUIREMENTS:

- a. SPECIAL INSPECTION IS IN ADDITION TO THE CONTRACTOR'S QUALITY CONTROL INSPECTIONS AND TESTING. THE CONTRACTOR'S QUALITY CONTROL INSPECTIONS AND TESTING SHALL OCCUR PRIOR TO SPECIAL INSPECTION AND REPORTS SHALL BE AVAILABLE TO THE SPECIAL
- b. THE CONTRACTOR SHALL ENSURE THAT THE WORK FOR WHICH SPECIAL INSPECTION IS REQUIRED REMAINS ACCESSIBLE AND EXPOSED FOR SPECIAL INSPECTION PURPOSES UNTIL COMPLETION OF THE REQUIRED SPECIAL INSPECTION.
- C. ANY CONTRACTOR RESPONSIBLE FOR THE CONSTRUCTION OF THE MAIN WIND OR SEISMIC FORCE RESISTING SYSTEM SHALL SUBMIT A WRITTEN STATEMENT OF RESPONSIBILITY TO THE BUILDING OFFICIAL AND OWNER PRIOR TO COMMENCEMENT OF WORK ON THE SYSTEM OR COMPONENT. THE STATEMENT OF RESPONSIBILITY SHALL CONTAIN ACKNOWLEDGEMENT OF AWARENESS OF THE SPECIAL INSPECTION REQUIREMENTS CONTAINED IN THE STATEMENT OF SPECIAL INSPECTIONS.

E. SPECIAL INSPECTOR REPORT REQUIREMENTS:

COMPLETION OF THAT PHASE OF WORK.

- a. THE SPECIAL INSPECTOR SHALL KEEP RECORD OF INSPECTIONS
- b. THE SPECIAL INSPECTOR SHALL FURNISH INSPECTION REPORTS TO THE BUILDING OFFICIAL AND TO THE ARCHITECT AND STRUCTURAL ENGINEER OF RECORD.
- C. REPORTS SHALL INDICATE THAT WORK INSPECTED WAS OR WAS NOT COMPLETED IN CONFORMANCE TO APPROVED CONSTRUCTION DOCUMENTS.
- d. DISCREPANCIES SHALL BE BROUGHT TO THE IMMEDIATE ATTENTION OF THE CONTRACTOR FOR
- e. IF NOT CORRECTED DISCREPANCIES SHALL BE BROUGHT TO THE ATTENTION OF THE BUILDING OFFICIAL AND THE ARCHITECT AND STRUCTURAL ENGINEER OF RECORD PRIOR TO THE
- f. A FINAL REPORT DOCUMENTING SPECIAL INSPECTIONS AND CORRECTION OF ANY DISCREPANCIES NOTED SHALL BE SUBMITTED TO THE BUILDING OFFICIAL.

SHOP FABRICATION

- 1. SHOP FABRICATION REQUIRES SPECIAL INSPECTION IN ACCORDANCE WITH CODE SECTION 1704.2.5. EXCEPTION: SHOP SPECIAL INSPECTIONS ARE NOT REQUIRED WHEN WORK IS DONE ON THE PREMISES OF FABRICATOR REGISTERED AND APPROVED TO PERFORM SUCH WORK IN ACCORDANCE WITH CODE SECTION 1704.2.5.1. THE FOLLOWING ACCREDITATIONS MEET THE REQUIREMENTS OF THIS EXCEPTION:
- A. STEEL BUILDINGS (OR STEEL ELEMENTS IN OTHER BUILDINGS) a. FOR GENERAL STEEL BUILDINGS OR ELEMENTS THE FABRICATOR SHALL BE AN AISC CERTIFIED FABRICATOR IN ACCORDANCE WITH THE AISC CERTIFICATION PROGRAM FOR STRUCTURAL STEEL FABRICATORS (AISC 201-06).
- b. OTHER ACCREDITATION DEEMED ACCEPTABLE BY THE AUTHORITY HAVING JURISDICTION.
- c. IF FABRICATION IS PERFORMED BY AN APPROVED FABRICATOR A CERTIFICATE OF COMPLIANCE MUST BE PROVIDED TO THE BUILDING INSPECTOR THAT THE MATERIALS SUPPLIED AND WORK PERFORMED BY THE FABRICATOR ARE IN CONFORMANCE WITH THE CONSTRUCTION
- d. IF FABRICATION IS NOT PERFORMED BY AN APPROVED FABRICATOR WELDING INSPECTION REPORTS MUST BE SUBMITTED TO THE BUILDING OFFICIAL BY AN APPROVED TESTING AGENCY.

THE QA AGENCY SHALL REVIEW THE FABRICATOR'S NDT REPORTS.

d.a. NONDESTRUCTIVE TESTING (NDT) MAY BE PERFORMED BY THE FABRICATOR, HOWEVER

B. WOOD BUILDINGS

- a. PREFABRICATED WOOD TRUSSES
- b. STRUCTURAL GLUED LAMINATED TIMBER

PRE-FABRICATED WOOD TRUSS NOTES

- 1. THE DESIGN OF METAL PLATE CONNECTED WOOD TRUSSES SHALL BE IN ACCORDANCE WITH THE FOLLOWING A. CODES AND STANDARDS:
 - a. THE GOVERNING CODE LISTED IN THE PROJECT GENERAL NOTES
 - b. MINIMUM DESIGN LOADS FOR BUILDINGS AND OTHER STRUCTURES (ASCE 7-16)
 - c. NATIONAL DESIGN STANDARD FOR WOOD CONSTRUCTION AND SUPPLEMENT (ANSI/AWC NDS-2018)
 - d. SPECIAL DESIGN PROVISIONS FOR WIND & SEISMIC (AWC SDPWS-2021)
 - e. THE NATIONAL DESIGN STANDARD FOR METAL PLATE CONNECTED WOOD TRUSS CONSTRUCTION (ANSI/TPI 1-2014)

a. TRUSSES SHALL BE DESIGNED FOR THE FOLLOWING MINIMUM VERTICAL LOADS AND OTHER LOADS INDICATED ON THE CONSTRUCTION DOCUMENTS (ATTIC MECHANICAL UNITS, ETC.)

CLAY TILE: TOP-CHORD DEAD LOAD: 21.3 PSF * (19.9 PSF SUPERIMPOSED) BOT CHORD DEAD LOAD: 7.0 PSF (5.7 PSF SUPERIMPOSED) ROOF - LIVE LOAD: 20 PSF

ROOF TRUSS LOADING AT PORCH: CLAY TILE:

TOP-CHORD DEAD LOAD: 21.3 PSF * (19.9 PSF SUPERIMPOSED) BOT CHORD DEAD LOAD: 13.3 PSF (12.0 PSF SUPERIMPOSED) ROOF - LIVE LOAD: 20 PSF

DEFLECTION CRITERIA:

ROOF TRUSS LOADING:

L/240 DEAD + LIVE LOAD LIVE LOAD ONLY L/360

*INCLUDES 4 PSF ALLOWANCE FOR PV PANELS

b. (#-) EQUALS DRAG FORCE IN LBS. DRAG FORCE IS AT A FACTORED LEVEL (0.7E). DRAG FORCES CALCULATED IN ACCORDANCE WITH ASCE 7-16 12.10.1.1. IN STRUCTURES ENTIRELY BRACED BY LIGHT FRAME SHEAR WALLS, OR PORTIONS THEREOF, DRAG MEMBERS SHALL BE DESIGNED TO RESIST FORCES USING THE LOAD COMBINATIONS OF ASCE 7-16 SECTION 12.4.2.3. IN ALL OTHER STRUCTURES DRAGS SHALL INCLUDE THE EFFECT OF OVER STRENGTH PER ASCE 7-16 12.4.3.2. THE TRUSS DESIGNER SHALL DESIGN FOR THE TRUSSES FOR THE INDICATED HORIZONTAL LOAD ACTING IN BOTH THE TOP AND BOTTOM TRUSS CHORDS AND FOR THE TRANSFER OF THE FORCE TO THE CHORDS THROUGH THE WEB.

2. CONTRACTOR REQUIREMENTS:

- A. THE CONTRACTOR SHALL MEET ALL THE REQUIREMENTS LISTED IN SECTION 2.3.4 OF ANSI/TPI 1-2014 INCLUDING THE FOLLOWING:
 - a. MEANS AND METHODS: THE CONTRACTOR IS RESPONSIBLE FOR ALL MEANS AND METHODS, TECHNIQUES, SEQUENCES, PROCEDURES, PROGRAMS AND SAFETY IN CONNECTION WITH THE RECEIPT, STORAGE, HANDLING, INSTALLATION, RESTRAINING, AND BRACING OF THE TRUSSES. REFER TO THE GUIDE TO GOOD PRACTICE FOR HANDLING, INSTALLING, RESTRAINING & BRACING OF METAL PLATE CONNECTED WOOD TRUSSES (BCSI-B1)
- b. TRUSS INSTALLATION SHALL COMPLY WITH INSTALLATION TOLERANCES SHOWN IN BCSI-B1
- C. TEMPORARY INSTALLATION RESTRAINT/BRACING FOR THE TRUSS SYSTEM AND THE PERMANENT
- TRUSS SYSTEM SHALL BE INSTALLED IN ACCORDANCE WITH BCSI-B2. d. CONSTRUCTION LOADING ON TRUSSES SHALL BE DONE IN ACCORDANCE WITH BCSI-B4.
- e. TRUSS DAMAGE, JOBSITE MODIFICATIONS & INSTALLATION ERRORS SHALL BE BROUGHT TO THE IMMEDIATE ATTENTION OF THE EOR AND THE TRUSS DESIGNER, REFERENCE BCSI-B5.
- f. SUBMIT THE DRAWINGS FROM THE TRUSS DESIGNER/MANUFACTURER TO THE BUILDING DEPARTMENT PRIOR TO FABRICATION FOR APPROVAL. A COPY OF THIS SUBMITTAL SHALL BE PROVIDED TO TEH ENGINEER OF RECORD FOR REVIEW OF GENERAL CONFORMANCE TO THE DESIGN INTENT. THE CONTRACTOR SHALL INCORPORATE THE TIME REQUIRED FOR THE SUBMITTAL TO BE REVIEWED, STAMPED AND APPROVED BY ALL PARTIES AND SHALL HAVE THE APPROVED

TRUSS PLANS ON THE JOB SITE PRIOR TO FOUNDATION INSPECTION. 3. TRUSS DESIGNER REQUIREMENTS

- A. THE TRUSS DESIGNER SHALL MEET ALL THE REQUIREMENTS LISTED IN SECTION 2.3.5 OF ANSI/TPI 1-2014
- INCLUDING THE FOLLOWING: TRUSS DESIGNER SHALL SUPERVISE THE PREPARATION OF THE TRUSS DESIGN DRAWINGS WHICH SHALL CONTAIN THE INFORMATION LISTED IN SECTION 2.3.5.5 OF ANSI/TPI 1-2014. THIS INCLUDES ALL TRUSS TO TRUSS CONNECTIONS, AND DETAILS FOR THE "CALIFORNIA FILL" AREAS.
- TRUSS DESIGNER SHALL COMPLY WITH THE REFERENCED CODE AND DESIGN CRITERIA ABOVE.
- C. TRUSS DESIGNER SHALL SHOW ALL HANGERS, BRACING AND RESTRAINTS AS WELL AS METHOD OF RESTRAINT/BRACING ON THE TRUSS PLANS TO MEET ANY SEISMIC AND WIND REQUIREMENTS OF THE CODE.
- d. SUBMIT TRUSS DESIGN DRAWINGS INCLUDING ALL RELEVANT DETAILS FOR THE FABRICATION OF THE TRUSSES AND PREPARE CALCULATIONS. ALL PLANS, DETAILS AND CALCULATIONS FOR THE TRUSSES SHALL BE STAMPED AND SIGNED BY A LICENSED PROFESSIONAL ENGINEER (CIVIL OR STRUCTURAL), LICENSED TO PRACTICE IN THE STATE OF CALIFORNIA.

WOOD STRUCTURAL PANELS (SHEATHING)

WOOD STRUCTURAL PANELS SHALL MEET THE FOLLOWING MINIMUM STANDARDS EXCEPT WHERE OTHERWISE NOTED:

	WOOD STRUCTURAL PANEL PROPERTIES						
USE	PLY	BOND CLASSIFICATION ^C	SHEATHING GRADE	PERFORMANCE RATING	SPAN RATING	RATING ^B	REFERENCE ^A
ROOF	5	EXPOSURE 1	refer to tyl	PICAL DIAPHRAGM	APA	2022 CBC	
FLOOR	5	EXPOSURE 1				APA	2303.1.5 (DOC PS 1-19 OR PS 2-18)
WALL D	5	EXPOSURE 1	REFER TO TY	PICAL SHEAR WALL S	SCHEDULE	APA	

- A. WOOD STRUCTURAL PANELS SHALL CONFORM TO THE REQUIREMENTS FOR THEIR TYPE IN ACCORDANCE WITH THE FOLLOWING VOLUNTARY STANDARDS BY THE ENGINEERED WOOD ASSOCIATION (APA):
- a. VOLUNTARY PRODUCT STANDARD, STRUCTURAL PLYWOOD, PS 1-09
- b. VOLUNTARY PRODUCT STANDARD, PERFORMANCE STANDARD FOR WOOD-BASED STRUCTURAL-USE PANELS, PS 2-10
- B. WOOD STRUCTURAL PANELS SHALL BE IDENTIFIED BY THE APA TRADEMARK INDICATING CONFORMANCE TO THE APPLICABLE VOLUNTARY STANDARD
- C. WHERE PANELS ARE EXPOSED TO REPEATED WETTING AND REDRYING, LONG-TERM EXPOSURE TO WEATHER, OR CONDTIONS OF SIMILAR SEVERITY, "EXTERIOR" APA RATED PLYWOOD SHEATHING SHALL BE USED. C-D "EXPOSURE 1" APA RATED PLYWOOD SHEATHING (CDX) SHALL NOT BE USED FOR CONDITIONS INVOLVING LONG-TERM EXPOSURE TO WEATHER.
 - a. EXCEPTION: WOOD STRUCTURAL PANEL ROOF SHEATHING EXPOSED TO THE OUTDOORS ON THE UNDERSIDE IS PERMITTED TO BE "EXPOSURE 1" TYPE.
- b. WOOD STRUCTURAL PANELS TO BE USED AS SIDING SHALL COMPLY WITH ANSI/APA PRP-210.
- D. ORIENTED STRAND BOARD (OSB) WITH EQUIVALENT CLASSIFICATION AND RATINGS MAY BE USED IN LIEU OF PLYWOOD FOR WOOD STRUCTURAL PANEL WALL SHEATHING.

2. TRANSPORTATION, STORAGE, AND HANDLING:

a. IN TRANSPORTING PANELS ON OPEN TRUCK BEDS, COVER THE BUNDLES WITH A TARP.

B. STORAGE

- a. ALWAYS STORE THE PANELS UNDER COVER WHENEVER POSSIBLE
- b. WHEN STORING PANELS OUTSIDE STACK THEM ON A LEVEL SURFACE ON TOP OF STRINGERS OR OTHER BLOCKING, THREE STRINGERS MINIMUM.
- NEVER LEAVE PANELS IN CONTACT WITH THE GROUND
- d. COVER THE STACK WITH A PLASTIC TARP, ENSURING THAT THE BUNDLE IS WELL VENTILATED TO PREVENT MILDEW.
- e. IF MOISTURE ABSORPTION IS EXPECTED, CUT THE STEEL BAND TO PREVENT DAMAGE
- KEEP SANDED OR OTHER APPEARANCE GRADE PANELS AWAY FROM HIGH TRAFFIC AREAS

- a. ALWAYS PROTECT ENDS AND EDGES, ESPECIALLY TONGUE AND GROOVE PRODUCTS, FROM PHYSICAL DAMAGE.
- b. ACCLIMATIZE THE PANELS FOR 24 HOURS MINIMUM BEFORE INSTALLATION BY STANDING THE PANELS ON EDGE WITH A GAP BETWEEN EACH TO ALLOW FOR AIR CIRCULATION OR PER MANUFACTURER'S RECOMMENDATIONS.

PLYWOOD ORIENTATION

- A. ROOF AND FLOOR SHEATHING SHALL BE LAID WITH THE GRAIN OF THE OUTER PILES PERPENDICULAR TO THE FRAMING MEMBERS, SHALL BE CONTINUOUS OVER 2 JOIST BAYS MINIMUM AND END JOINTS SHALL BE JOINED OVER FRAMING AND STAGGERED, LEAVE A X" GAP BETWEEN PANELS TO ALLOW FOR PANEL EXPANSION UNLESS RECOMMENDED OTHERWISE BY THE PANEL MANUF, REFER TO SPECIFIC DETAILS IN THE DRAWINGS FOR FURTHER PARAMETERS.
- B. PLYWOOD OR OSB WALL SHEATHING MAY BE APPLIED VERTICALLY OR HORIZONTALLY, ALL END JOINTS

BLOCKING:

- A. ROOF: ALL ROOF SHEATHING SHALL BE BLOCKED UNLESS SPECIFICALLY ALLOWED ON PLANS, WHERE PERMITTED TO BE UNBLOCKED, ALL UNBLOCKED EDGES SHALL BE TONGUE AND GROOVE.
- B. ALL FLOOR SHEATHING SHALL BE BLOCKED UNLESS SPECIFICALLY ALLOWED ON PLANS. WHERE PERMITTED TO BE UNBLOCKED, ALL UNBLOCKED EDGES SHALL BE TONGUE AND GROOVE.
- C. WALLS: ALL SHEAR WALLS SHALL BE FULLY BLOCKED AT PLYWOOD EDGES.

BE JOINED OVER FRAMING AND STAGGERED.

FASTENERS

- A. USE SHEATHING NAILS SAME GAUGE AS COMMON WIRE NAILS WITH LENGTHS AT LEAST EQUAL TO SHEATHING THICKNESS PLUS REQUIRED PENETRATION PER AWS SDPWS TABLE 4.2A OR 4.3A (AS REQUIRED).
- B. EQUIVALENT PNEUMATIC DRIVE NAILS MAY BE USED IF FASTENER MANUFACTURER HAS RECEIVED ICC OR IAPMO APPROVAL FOR THE INTENDED US. FASTENERS TO BE SUBSTITUTED SHALL BE EQUIVALENT IN LATERAL AND WITHDRAWAL STRENGTH TO THE SIZE OF COMMON NAIL SPECIFIED.
- C. USE OF MACHINE NAILING IS SUBJECT TO A SATISFACTORY JOB SITE DEMONSTRATION FOR EACH PROJECT AND THE APPROVAL BY THE PROJECT ARCHITECT OR STRUCTURAL ENGINEER. THE APPROVAL IS SUBJECT TO CONTINUED SATISFACTORY PERFORMANCE. MACHINE NAILING WILL NOT BE APPROVED IN 5/16" PLYWOOD OR OSB SHEATHING. IF NAIL HEADS PENETRATE THE OUTER PLY MORE T HAN WOULD BE NORMAL FOR A HAND HAMMER OR IF MINIMUM ALLOWABLE EDGE DISTANCES ARE NOT MAINTAINED, THE PERFORMANCE WILL BE DEEMED UNSATISFACTORY.
- D. TYPICAL NAILING SHALL BE 10d AT 6" O.C. AT ALL SUPPORTED EDGES AND OVER SHEAR WALLS, AND 10D AT 12" O.C. AT ALL INTERMEDIATE SUPPORTS, UNLESS OTHERWISE NOTED, SEE PLANS AND REFER TO SHEAR WALL SCHEDULE.

SAWN LUMBER

FRAMING LUMBER SHALL MEET THE FOLLOWING MINIMUM STANDARDS EXCEPT WHERE OTHERWISE NOTED:

SAWN LUMBER PROPERTIES

USE	SIZE	SPECIES	GRADE	REFERENCE	
	2x4	D.F.	STANDARD OR BETTER PRESSURE TREATED		
MUDSILLS	2x6 AND LARGER	D.F.	NO. 2 OR BETTER PRESSURE TREATED	2022 CBC 2303.1.9	
	2x	REDWOOD	FOUNDATION GRADE		
	<u>HORIZONTAL</u> FRA	MING LUMBE	R	•	
ROOF JOISTS AND RAFTERS	2x	D.F.	NO. 2		
FLOOR JOISTS	2x	D.F.	NO. 2	WCLIB & WWPA	
HEADERS AND BEAMS	4x	D.F.	NO. 2		
ANN OTHER HORIZONIAN	4x4 AND SMALLER	D.F.	NO. 2	1,,,,,,	
ANY OTHER HORIZONTAL	6x6 AND LARGER	D.F.	NO. 1	1	
	<u>VERTICAL</u> FRAM	ING LUMBER			
TOP PLATES	2x	D.F.	NO. 2		
STUDS	2x4 & 3x4	D.F.	STUD	WCI ID 0	
310D3	2x6 & 2x8	D.F.	NO. 2	WCLIB & WWPA	
POSTS	4x4 & 4x6 POSTS	D.F.	NO. 2]'''''	
	6x6 & LARGER POSTS	D.F.	NO. 1		
	ALL OTHER FRAM	AING LUMBER			
ALL OTHER FRAMING LUMBER, UNO	ALL SIZES	D.F.	STANDARD & BETTER	WCLIB & WWPA	

- 2. FLOOR JOISTS SHALL BE GRADE STAMPED "S-DRY" WHICH INDICATES A MOISTURE CONTENT NOT EXCEEDING
- ALL SOLE PLATES AND TOP PLATES SHALL BE GRADE STAMPED "KD" WHICH INDICATES KILN DRIED WITH A MOISTURE CONTENT NOT EXCEEDING 15 PERCENT AT BUILDINGS WITH 4 OR MORE STORIES.
- STUD WALLS SHOWN ON PLANS ARE NONBEARING PARTITIONS WALLS, BEARING WALLS OR SHEAR WALLS BELOW THE FRAMING LEVEL, UNLESS NOTED OTHERWISE. STUDS SHALL BE SIZE AND SPACING AS NOTED IN THE DRAWINGS, SEE PLANS AND ARCHITECTURAL DRAWINGS. UNLESS OTHERWISE NOTED.
- MINIMUM FRAMING NAILING SHALL CONFORM TO CBC TABLE 2304.10.2. ALL NAILS SHALL BE COMMON WIRE NAILS. PREDRILL NAIL HOLES TO 70% OF NAIL SHANK DIAMETER WHERE NAILING TENDS TO SPILT WOOD.
- UNLESS OTHERWISE NOTED, ALL WOOD SILL PLATES UNDER BEARING, EXTERIOR, OR SHEAR WALLS IN CONTACT WITH CONCRETE OR MASONRY SHALL BE BOLTED TO THE CONCRETE OR MASONRY WITH 5/8" Ø X 12" BOLTS W/ 0.229" X 3" X 3" PLATE WASHER (GALV) AT 4'-O" O.C. BEGINNING AT 9" O.C. MAXIMUM FROM EACH END OF THE PLATES. THE BOLTS SHALL EXTEND A MINIMUM OF 7" INTO THE CONCRETE OR MASONRY. (POWDER DRIVEN PINS AT 1/3 OF THE BOLT SPACING OR 24" O.C. MAXIMUM MAY BE SUBSTITUTED FOR THE ANCHOR BOLTS AT INTERIOR NON-SHEAR WALLS ONLY).

7. PRESERVATIVE TREATMENT:

- A. WOOD MEMBERS SHALL BE PRESERVATIVE TREATED IN ACCORDANCE WITH AITC 109-07, STANDARD FOR PRESERVATIVE TREATMENT, BASED ON THE SERVICE CONDITION PER THE USE CATEGORIES (UC#) SPECIFIED IN AWPA U1-20.
- a. UC1 INTERIOR CONSTRUCTION, ABOVE GROUND, DRY NO PRESERVATIVE TREATMENT REQUIRED. b. UC2 - INTERIOR CONSTRUCTION, ABOVE GROUND, WET - PRESERVATIVE TREATMENT REQUIRED IF
- THE HUMIDITY OR MOISTURE CONDENSATION IS 20% OR GREATER. c. UC3 - EXTERIOR CONSTRUCTION ABOVE GROUND - PRESERVATIVE TREATMENT REQUIRED.
- B. FOR ALL TREATED WOOD MEMBERS, ALL CUTS, HOLES OR INJURIES SUCH AS ABRASIONS OR HOLES FROM REMOVAL NAILS AND SPIKES WHICH MAY PENETRATE THE TREATED ZONE SHALL BE FIELD TREATED IN
- ACCORDANCE WITH AWPA M4-15. THE FOLLOWING FILED TREATMENTS SHALL BE USED: a. BORED HOLES: HOLES FOR CONNECTORS OR BOLTS MAY BE TREATED BY PUMPING COAL TAR ROOFING CEMENT MEETING ASTM D5643 INTO HOLES USING A GREASE GUN OR SIMILAR DEVICE.
- b. EXTERIOR: COPPER NAPHTHENATE. c. Interior: Inorganic Boron Preservatives Limited to USE in Applications not in Contact WITH GROUND AND CONTINUOUSLY PROTECTED FROM LIQUID WATER.
- C. ALL LUMBER IN CONTACT WITH CONCRETE SHALL BE PRESSURE TREATED LUMBER WITH AWPA TREATMENT C2 USING EITHER ALKALINE QUAT (ACQ TYPE B AND D), COPPER AZOLE (CBA-A, CA-B), OR SODIUM BORATES (SBX), ANCHOR BOLTS, FASTENERS, AND METAL FRAMING CONNECTORS IN CONTACT WITH PRESSURE TREATED LUMBER SHALL BE HOT-DIPPED GALVANIZED TO A RATING OF G-185 PER ASTM A653.
- 8. PROVIDE 2 STUDS UNDER ALL 4 X 10 AND LARGER BEAMS OR HEADERS AT SPANS 6 FEET OR LONGER, UNLESS OTHERWISE NOTED. WHERE POSTS OR MULTIPLE STUDS UNDER BEAMS OR HEADERS ARE CALLED FOR ON DRAWINGS THOSE POSTS OR MULTIPLE STUDS SHALL BE CARRIED TO THE FOUNDATION/PODIUM LEVEL.
- 9. PROVIDE THE FOLLOWING BLOCKING AS A MINIMUM, UNLESS SHOWN OTHERWISE:

SHOWN OTHERWISE. NAIL DOUBLED JOISTS WITH 16d AT 12" O.C., STAGGERED.

2x FULL DEPTH SOLID BLOCKING BETWEEN JOISTS OVER SUPPORT.

- 2x FULL DEPTH SOLID BLOCKING BETWEEN JOISTS OVER AND BELOW PARTITION WALLS. 10. DOUBLE JOISTS UNDER PARTITIONS RUNNING PARALLEL TO JOISTS, UNLESS SUPPORTED BY A WALL BELOW OR
- 11. BRIDGING SHALL BE 2 X SOLID BLOCKS, INSTALLED AS FOLLOWS: ROOF JOISTS MORE THAN 10" DEPTH, 8'-O" O.C. MAXIMUM, NOT MORE THAN 8'-0' FROM SUPPORT.

FLOOR JOISTS MORE THAN 10" DEPTH, 8'-O" O.C. MAXIMUM, NOT MORE THAN 8'-0' FROM SUPPORT.

- 12. JOIST HANGERS AND OTHER METAL FRAMING ACCESSORIES ARE REFERRED TO ON PLANS BY PARTICULAR TYPE AS MANUFACTURED BY SIMPSON STRONG-TIE COMPANY, STOCKTON, CALIFORNIA. ACCESSORIES OF OTHER MANUFACTURES WITH EQUIVALENT LOAD CARRYING CHARACTERISTICS MAY BE USED WITH APPROVAL
- 13. FIRE STOPPING, BACKING FOR INTERIOR FINISHES, NONBEARING WALLS, AND OTHER NON-STRUCTURAL FRAMING ARE NOT NECESSARILY SHOWN ON STRUCTURAL DRAWINGS. REFER TO ARCHITECTURAL DRAWINGS.

HARDWARE AND CONNECTORS


USE ALL SPECIFIED FASTENERS AS SPECIFIED ON PLANS. IF NOT INDICATED ON PLANS PROVIDE FASTENERS PER MFR'S APPROVED ICC-ESR REPORT OR PRODUCT LITERATURE

- 1. DO NOT OVER TIGHTEN NUTS ON TIE-DOWN ANCHOR RODS OR BOLTS. TIGHTEN ANCHOR ROD NUTS ONE-THIRD TO ONE HALF TURN BEYOND FINGER TIGHT 2. INSTALL ALL HOLDOWNS TIGHT TO END STUDS/POST, DO NOT USE FILLER BLOCKS. FOR MISALIGNED ANCHOR
- BOLTS, EXTEND THE ANCHOR ROD AT A 1:6 (HORIZ/VERT) USING A COUPLER WITH EQUIVALENT ANCHOR ROD AND INSTALL THE HOLDOWN HIGHER ON END STUD / POST 3. FOR HOLDOWNS THAT BOLT TO END POSTS, INSTALL THE HEAD OF THE BOLT TO THE BRACKET SIDE, AND ON

- TIE DOWN AND COLLECTOR STRAPS SHALL BE INSTALLED STRAIGHT AND TRUE. DO NOT FOLD, BEND, KINK OR
- OTHERWISE ALTER CONNECTOR STRAPS 2. INSTALL TIE DOWN STRAPS DIRECT TO POST IN LIEU OF OVER SHEATHING. STRAPS MAY BE INSTALLED ON THE UNSHEATHED SIDE OF THE END STUDS / POSTS

THE SIDE OPPOSITE THE BRACKET, INSTALL A WASHER BETWEEN THE NUT AND THE STUD / POSTS

FASTENER INFORMATION

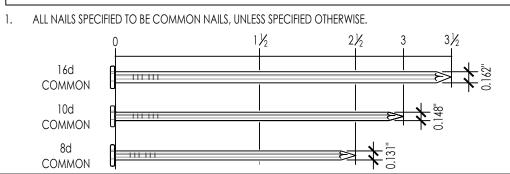



THESE PLANS ARE PROVIDED BY THE CITY OF CATHEDRAL CITY AS PART OF THE PRE-APPROVED ADU PROGRAM AND ARE PUBLIC DOMAIN. THERE CANNOT BE A CHARGE TO PROVIDE THESE PLANS. NO ALTERATIONS TO THESE PLANS ARE ALLOWED. ALL ALTERATIONS MUST BE DONE UNDER A SEPARATE PERMIT ONCE THE BUILDING PERMIT FOR THE ADU HAS BEEN ISSUED AND FINAL INSPECTION COMPLETED. IF YOU DO NOT HAVE THE CONSTRUCTION KNOWLEDGE AND EXPERIENCE TO CONTRUCT THESE PLANS WITHOUT FURTHER DETAILS, IT IS RECOMMENDED YOU HIRE A CONTRACTOR TO DO THE CONSTRUCTION. THE CITY WILL NOT PROVIDE FURTHER INFORMATION OR DETAILS AND BUILDING INSPECTORS WILL NOT PROVIDE STEP BY STEP INSTRUCTIONS IN THE FIELD.

S &

4

CH

Ш


I

08/08/24

S

UBL

SHEET

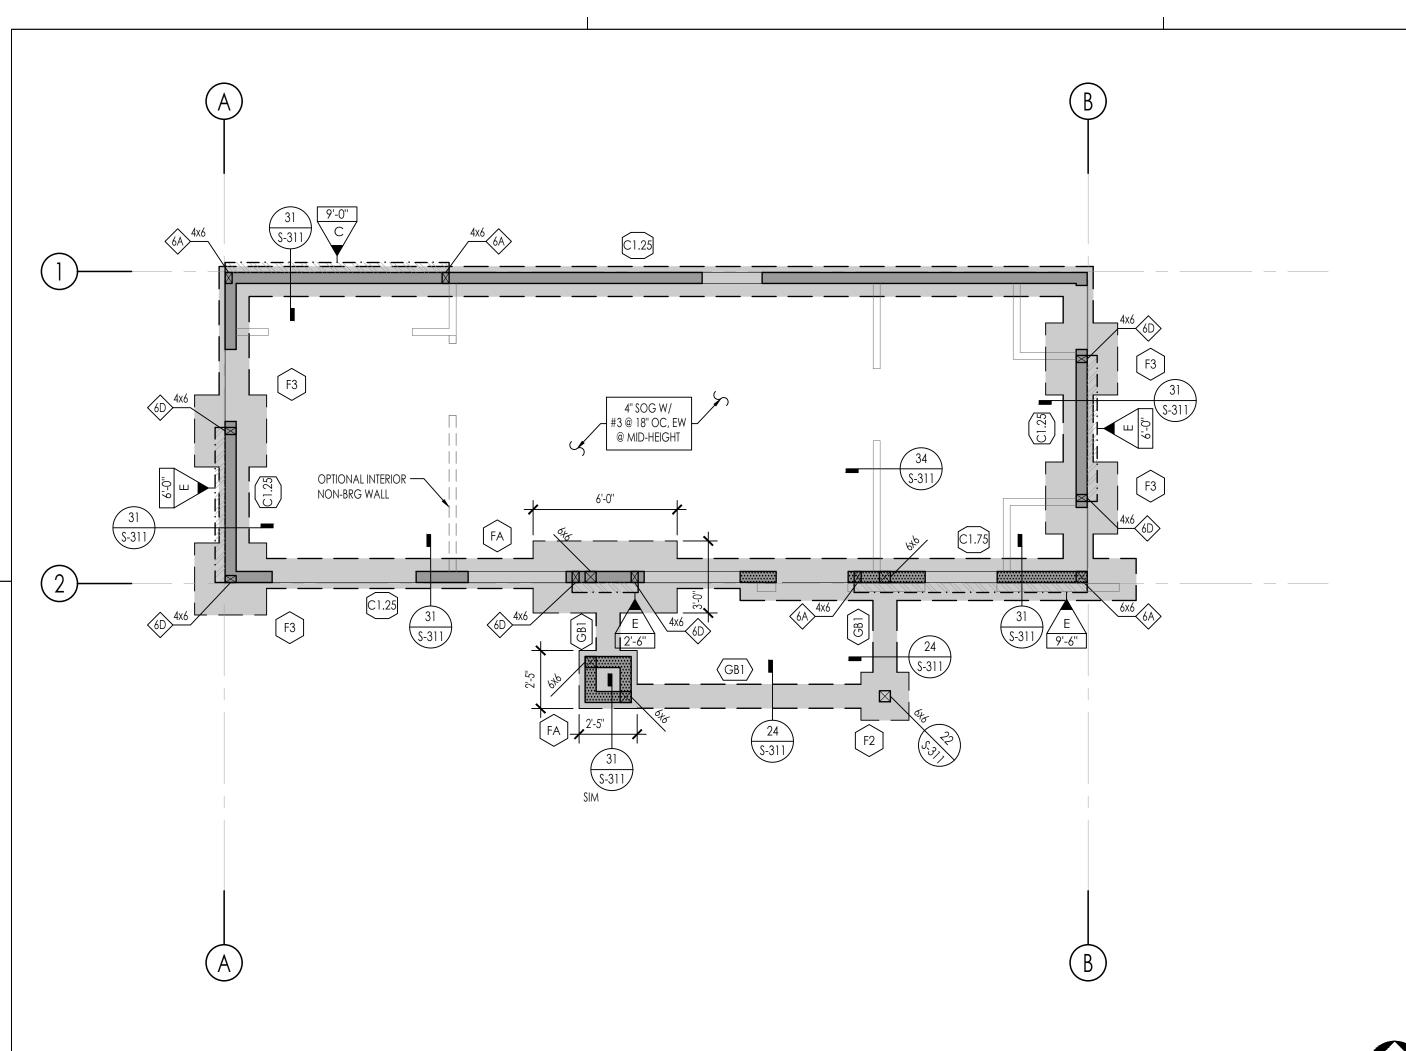

12'-0" DIAPH TYPE 'B' IN HATCHED AREA OPTIONAL PREFAB — AWNING BY OTHERS, REFER TO 33/A-922 HATCHED AREA

Cathedral City

THESE PLANS ARE PROVIDED BY THE CITY OF CATHEDRAL CITY AS PART OF THE PRE-APPROVED ADU PROGRAM AND ARE PUBLIC DOMAIN. THERE CANNOT BE A CHARGE TO PROVIDE THESE PLANS. NO ALTERATIONS TO THESE PLANS ARE ALLOWED. ALI COMPLETED. IF YOU DO NOT HAVE THE CONSTRUCTION KNOWLEDGE AND EXPERIENCE TO CONTRUCT THESE PLANS WITHOUT FURTHER DETAILS, IT IS RECOMMENDED YOU HIRE A CONTRACTOR TO DO THE CONSTRUCTION. THE CITY WILL NOT PROVIDE FURTHER INFORMATION OR DETAILS AND BUILDING INSPECTORS WILL NOT PROVIDE STEP BY STEP INSTRUCTIONS IN THE FIELD.

TOUNDATION PLAN - DESERT MODERN

SCALE: 1/4" = 1'-0"

PLAN NORTH

ROOF FRAMING PLAN - DESERT MODERN

SCALE: 1/4" = 1'-0"

1. SEE THE FOLLOWING SHEETS FOR GENERAL NOTES AND TYPICAL DETAILS.

Symbols and abbreviations S-101 STRUCTURAL GENERAL NOTES S-102 - S-103 TESTING AND INSPECTION TYPICAL CONCRETE DETAILS TYPICAL WOOD DETAILS S-401 - S-403

2. SEE ARCHITECTURAL DRAWINGS FOR FINISHED FLOOR ELEVATIONS. REFERENCE FINISHED FLOOR ELEVATION = 0'-0" CORRESPONDS TO FINISHED FLOOR ELEVATION.

3. SEE ARCHITECTURAL DRAWINGS FOR ALL EXTERIOR CONCRETE PAVING, SLABS, BASES, CURBS, ETC.

- 4. FOR ANY DIMENSIONAL INFORMATION NOT SHOWN, SEE ARCHITECTURAL DRAWINGS.
- 5. ALL DIMENSIONS SHOWN ARE FACE OF SHEATHING, OR CENTERLINE OF COLUMN. UNLESS NOTED OTHERWISE, ALL COLUMNS ARE CENTERED IN STUD WALLS.
- 6. SEE ARCHITECTURAL DRAWINGS FOR SIZE AND LOCATION OF ALL DOOR AND WINDOW OPENINGS IN BEARING AND NON-BEARING WALLS.
- 7. SEE ARCHITECTURAL DRAWINGS FOR LOCATION OF INTERIOR NON-BEARING PARTITIONS.
- 8. ALL POSTS IN 6" WALLS SHALL BE 6x6, UNLESS NOTED OTHERWISE.

9. SEE PLANS AND ARCHITECTURAL DRAWINGS FOR DEPRESSIONS AND/OR SLOPES IN CONCRETE SLABS.

- 10. SEE ARCHITECTURAL DRAWINGS FOR ADDITIONAL EMBEDDED ITEMS AND SLAB PENETRATIONS.
- 11. FOR TYPICAL SLAB-ON-GRADE REQUIREMENTS, INCLUDING SLAB JOINTS, SEE DETAIL 31/S-301
- 12. PLATE WASHERS ARE REQUIRED FOR ALL SILL PLATE ANCHOR BOLTS
- 13. ALL HOLDOWN ANCHOR NUTS SHALL BE TIGHTENED TO FINGER TIGHT PLUS ONE-HALF WRENCH TURN JUST PRIOR TO COVERING
- 14. ALL BOLT HOLES, IN WOOD MEMBERS, SHALL BE DRILLED A MAXIMUM OF 1/16" OVERSIZED. INSPECTOR TO VERIFY

GENERAL PLAN NOTES 15. THE BUILDING PAD SHALL BE PREPARED AS OUTLINED IN DETAIL 53/S-301. THE BUILDING OFFICIAL SHALL REQUIRE PAD CERTIFICATION BY A GEOTECHNICAL ENGINEER AT THEIR DISCRETION.

16. BOTTOM OF FOOTING SHALL BE, UNLESS DEEPER FOUNDATIONS ARE REQUIRED BY THE BUILDING OFFICIAL: . 18" BELOW PAD OR ADJACENT GRADE AT PERIMETER, WHICHEVER IS DEEPER, UNO B. 18" BELOW PAD OR ADJACENT GRADE AT INTERIOR GRADE BEAMS, WHICHEVER IS DEEPER, UNO

NOTE: FOOTING MUST BE DEEPENED LOCALLY PER DETAIL 32/S-301 TO ACCOMMODATE ANCHOR **BOLT HOLDOWN EMBED DEPTHS**

17. SEE ARCHITECTURAL DRAWINGS FOR ALL TOP OF SHEATHING AND TOP OF WALL ELEVATIONS.

- 18. ALL LINES OR MEMBERS INDICATED AS "STRUT" SHALL RECEIVE (2) ROWS OF BOUNDARY NAILING (BN), STAGGERED.
- 19. ALL INTERIOR WALLS NOT SHOWN ON THE STRUCTURAL FRAMING PLANS BUT SHOWN ON THE ARCHITECTURAL DRAWINGS SHALL BE CONSTRUCTED PER NON-BEARING PARTITION WALL DETAIL 43/S-401, UNO.
- 20. PLYWOOD SHEATHED DIAPHRAGM TYPES:
- ALL ROOF DIAPHRAGMS SHALL BE TYPE A, UNO REFER TO 12/S-403
- 21. TRUSS MEMBERS AND COMPONENTS SHALL NOT BE CUT, NOTCHED, DRILLED OR OTHERWISE ALTERED IN ANY WAY WITHOUT WRITTEN CONCURRENCE AND APPROVAL OF A REGISTERED DESIGN PROFESSIONAL.
- 22. ALTERATIONS RESULTING IN THE ADDITION OF LOADS TO ANY MEMBER (E.G. HVAC EQUIPMENT, WATER HEATER) SHALL NOT BE PERMITTED WITHOUT VERIFICATION THAT THE TRUSS IS CAPABLE OF SUPPORTING SUCH ADDITIONAL LOADING.

INDICATES SHEAR WALL TYPE AND LENGTH, PER SCHEDULE ON DETAIL 13/S-402

INDICATES BLOCKING & STRAPPING ABOVE & BELOW WINDOW OPENINGS PER DETAIL 44/S-402 INDICATES HEADER @ OPENING. REFER TO 32/S-401 FOR HEADER SIZE, UNLESS NOTED OTHERWISE

SYMBOL LEGEND INDICATES TOP PLATE SPLICE NAILING PER DETAILS 31/S-403. NAILING APPLIES TO ENTIRE LENGTH OF TOP PLATE. PROVIDE TYPE (C) SPLICE, ULESS NOTED OTHERWISE

INDICATES STRAP PER 52/S-403 OR 54/S-403, UNO

FOUNDATION SCHEDULES

			PAI	O FOOTING SCHEE	DULE		
TYPE	WIDTH	LENGTH	THICKNESS	MIN EMBED BELOW LOWEST PAD GRADE	TOP REINF	BOT REINF	DETAIL UNO
FA	PER PLAN	PER PLAN	1'-6"	SEE NOTE 16	#5, @ 8" OC, EW	#5, @ 8" OC, EW	
F2	2'-0"	2'-0"	1'-6"	SEE NOTE 16	(3) #5, EW	(3) #5, EW	44/S-311
F3	3'-0"	3'-0"	1'-6"	SEE NOTE 16	(4) #5, EW	(4) #5, EW	44/3-311
F4	4'-0"	4'-0"	1'-6"	SEE NOTE 16	(6) #5, EW	(6) #5, EW	

NOTE: FOOTING MUST BE DEEPENED LOCALLY PER DETAIL 32/S-301 TO ACCOMMODATE AB HOLDOWN EMBED DEPTHS

STUD WALL SCHEDULE						
WALL HATCH	STUD SIZE	STUD SPACING	HDR SIZE, UNO			
	2x6 DF No. 2 STUDS	12" OC				
	2x6 DF No. 2 STUDS	16" OC	32/S-401			
	2x4 DF No. 2 STUDS	16" OC	32/3-401			
	NON BRG WALLS	16" OC				

		SHEARWALL HO	LDOWN SCHEDUI	LE	
	ECIFIES HOLI RAP DETAIL	\ /	IDICATES HOLDO'	WN/	
6	sx>	INDICATES SIMPSO	N HOLDOWN W/ CONCRETE FOUN		
<	×		ON HOLDOWN W		
		CONTINUOUS FO	OOTING SCHEDUI	LE	
.,		MIN EMBED BELOW			

CONTINUOUS FOOTING SCHEDULE						
MARK	WIDTH	MIN EMBED BELOW LOWEST PAD GRADE	LONG REINF	TRANS REINF	DETAIL	
C1.25	1'-3"	SEE NOTE 16	(2) #5 T&B	#3 @ 12" OC, BOT	31/S-311	
C1.75	1'-9"	SEE NOTE 16	(3) #5 T&B	#3 @ 12" OC, BOT	31/\$-311	
			-			

12/\$-311

14/S-311

			GRADE BEA	M SCHEDULE		
TYPE	WIDTH	THICKNESS	MIN EMBED BELOW LOWEST PAD GRADE	LONG REINF	TRANS REINF	DETAIL
(GB1)	1'-0"	1'-0"	SEE NOTE 16	(2) #4 @ TOP (2) #4 @ BOT	#3 @ 24" OC	24/\$-311

ROOF FRAMING SCHEDULES

	ROOF BEAM SCHEDULE	
MARK	SIZE	REMARKS
B1	6x6	
B2	6x8	
В3	6x10	
В4	6x12	

	RAFTER SCHEDULE	
MARK	SIZE	REMARKS
Jl	2x6 @ 24" OC	
	HEADER SCHEDULE	

SIZE

1. FOR PREFABRICATED ROOF TRUSS NOTES SEE NOTES ON SHEET S-103 ROOF TRUSS SCHEDULE

PREFABRICATED ROOF TRUSS


	KOOI IKOSS SCHEDOLL			
MARK	DESCRIPTION	REMARKS		
RT	ROOF TRUSS (COMMON)	24" OC MAX		
SGT	STRUCTURAL GABLE TRUSS			
MT	MONO PITCH TRUSS	24" OC MAX		
JT	JACK TRUSS	24" OC MAX		
VJT	VALLEY JACK TRUSS	24" OC MAX		
CJT	CORNER JACK TRUSS			
GT	GIRDER TRUSS			
MGT	MONO PITCH GIRDER TRUSS			
DT (#*)	DRAG TRUSS			
CGT	CALIFORNIA GIRDER TRUSS			
HR	HIP RAFTER / JACK RAFTER			
CHT	CALIFORNIA HIP TRUSS	24" OC MAX		
SCT	SCISSOR TRUSS	24" OC MAX, CEILING SLOPE PER ARCH		

(#*) - EQUALS DRAG FORCE IN LBS, DRAG FORCE IS AT A FACTORED LEVEL (0.7E) DRAG FORCES CALCULATED IN ACCORDANCE WITH ASCE 7-16 12.10.1.1. IN STRUCTURES ENTIRELY BRACED BY LIGHT FRAME SHEAR WALLS, OR PORTIONS THEREOF, DRAG MEMBERS SHALL BE DESIGNED TO RESIST FORCES USING THE LOAD COMBINATIONS OF ASCE 7-16 SECTION 12.4.2.3 IN ALL OTHER STRUCTURES DRAGS SHALL INCLUDE THE EFFECT OF OVER STRENGTH PER ASCE 7-16

S

08/08/24

ATHEDR,

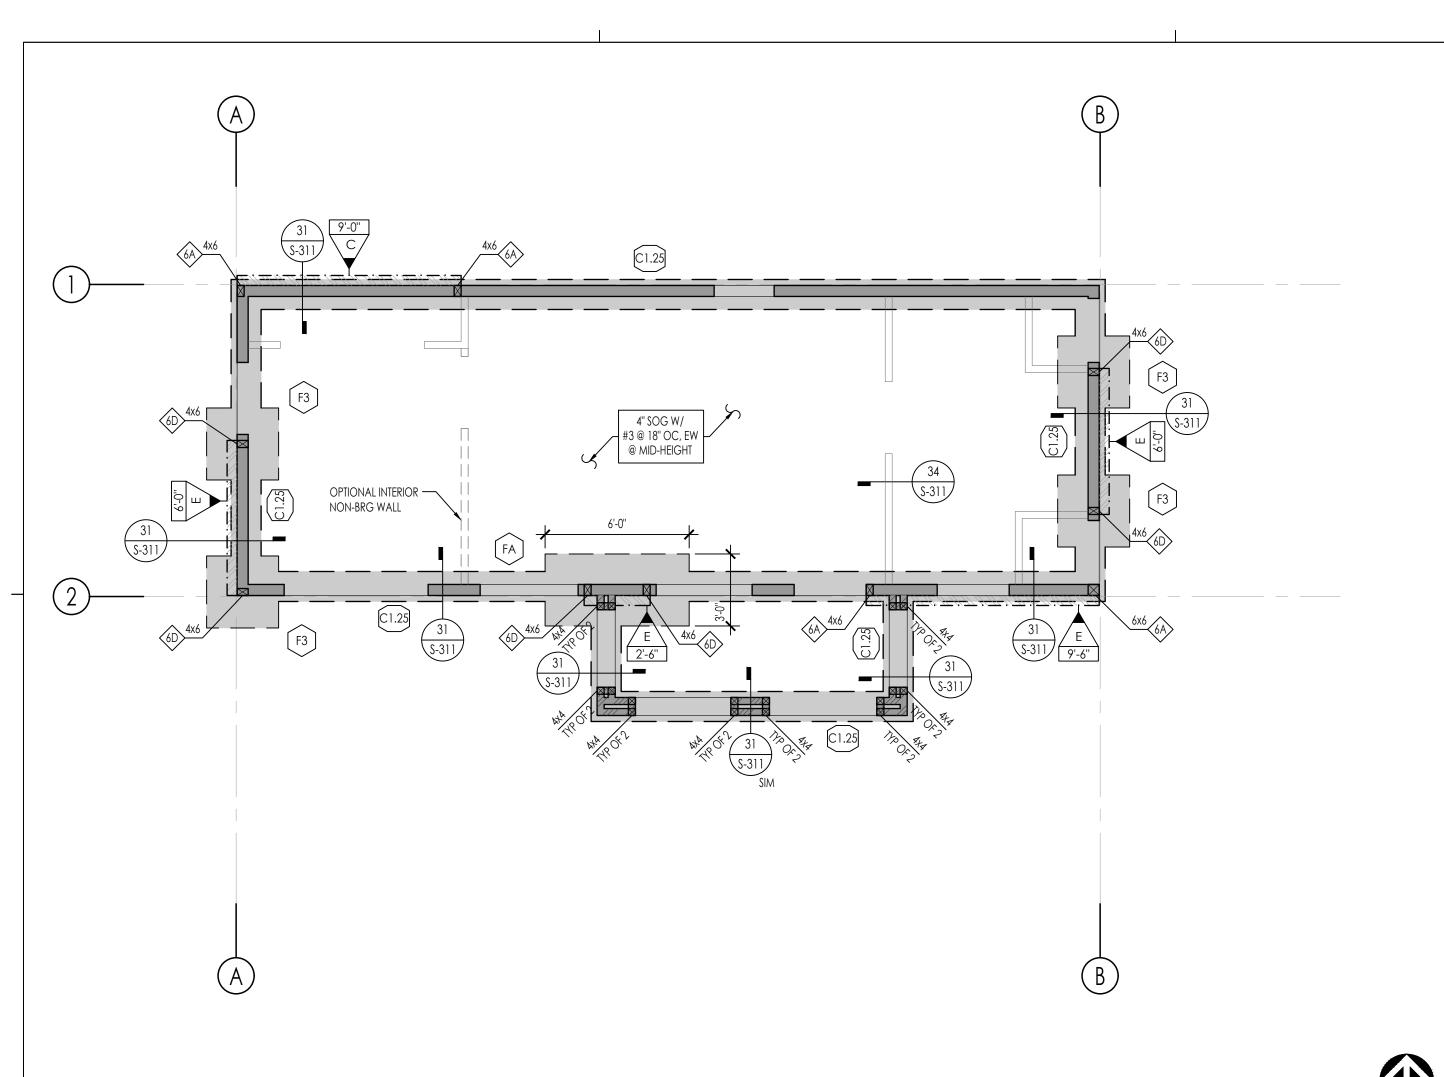

The state of the s

Cathedral City

THESE PLANS ARE PROVIDED BY THE CITY OF CATHEDRAL CITY AS PART OF THE PRE-APPROVED ADU PROGRAM AND ARE PUBLIC DOMAIN. THERE CANNOT BE A CHARGE TO PROVIDE THESE PLANS. NO ALTERATIONS TO THESE PLANS ARE ALLOWED. ALL ALTERATIONS MUST BE DONE UNDER A SEPARATE PERMIT ONCE THE BUILDING PERMIT FOR THE ADU HAS BEEN ISSUED AND FINAL INSPECTION COMPLETED. IF YOU DO NOT HAVE THE CONSTRUCTION KNOWLEDGE AND EXPERIENCE TO CONTRUCT THESE PLANS WITHOUT FURTHER DETAILS, IT IS RECOMMENDED YOU HIRE A CONTRACTOR TO DO THE CONSTRUCTION. THE CITY WILL NOT PROVIDE FURTHER INFORMATION OR DETAILS AND BUILDING INSPECTORS WILL NOT PROVIDE STEP BY STEP INSTRUCTIONS IN THE FIELD.

PLAN NOR

FOUNDATION PLAN - MEDITERRANEAN

SCALE: 1/4" = 1'-0"

PLAN NORTH

ROOF FRAMING PLAN - MEDITERRANEAN

SCALE: 1/4" = 1'-0"

GENERAL PLAN NOTES

GENERAL

1. SEE THE FOLLOWING SHEETS FOR GENERAL NOTES AND TYPICAL DETAILS.

SYMBOLS AND ABBREVIATIONS S-101

STRUCTURAL GENERAL NOTES S-102 - S-103

TESTING AND INSPECTION S-103

TYPICAL CONCRETE DETAILS S-301

TYPICAL WOOD DETAILS S-401 - S-403

 SEE ARCHITECTURAL DRAWINGS FOR FINISHED FLOOR ELEVATIONS. REFERENCE FINISHED FLOOR ELEVATION = 0'-0" CORRESPONDS TO FINISHED FLOOR ELEVATION.

3. SEE ARCHITECTURAL DRAWINGS FOR ALL EXTERIOR CONCRETE PAVING, SLABS, BASES, CURBS, ETC.

4. FOR ANY DIMENSIONAL INFORMATION NOT SHOWN, SEE ARCHITECTURAL DRAWINGS.

5. ALL DIMENSIONS SHOWN ARE FACE OF SHEATHING, OR CENTERLINE OF COLUMN. UNLESS NOTED OTHERWISE, ALL COLUMNS ARE CENTERED IN STUD WALLS.

6. SEE ARCHITECTURAL DRAWINGS FOR SIZE AND LOCATION OF ALL DOOR AND WINDOW OPENINGS IN BEARING AND NON-BEARING WALLS.

7. SEE ARCHITECTURAL DRAWINGS FOR LOCATION OF INTERIOR NON-BEARING PARTITIONS.

8. ALL POSTS IN 6" WALLS SHALL BE 6x6, UNLESS NOTED OTHERWISE.

FOUNDATION

9. SEE PLANS AND ARCHITECTURAL DRAWINGS FOR DEPRESSIONS AND/OR SLOPES IN CONCRETE SLABS.

10. SEE ARCHITECTURAL DRAWINGS FOR ADDITIONAL EMBEDDED ITEMS AND SLAB PENETRATIONS.

11. FOR TYPICAL SLAB-ON-GRADE REQUIREMENTS, INCLUDING SLAB JOINTS, SEE DETAIL 31/S-301

12. PLATE WASHERS ARE REQUIRED FOR ALL SILL PLATE ANCHOR BOLTS

13. ALL HOLDOWN ANCHOR NUTS SHALL BE TIGHTENED TO FINGER TIGHT PLUS ONE-HALF WRENCH TURN JUST PRIOR TO COVERING

14. ALL BOLT HOLES, IN WOOD MEMBERS, SHALL BE DRILLED A MAXIMUM OF 1/16" OVERSIZED. INSPECTOR TO VERIFY

15. THE BUILDING PAD SHALL BE PREPARED AS OUTLINED IN DETAIL 53/S-301. THE BUILDING OFFICIAL SHALL REQUIRE PAD CERTIFICATION BY A GEOTECHNICAL ENGINEER AT THEIR DISCRETION.

16. BOTTOM OF FOOTING SHALL BE, UNLESS DEEPER FOUNDATIONS ARE REQUIRED BY THE BUILDING OFFICIAL:
A. 18" BELOW PAD OR ADJACENT GRADE AT PERIMETER, WHICHEVER IS DEEPER, UNO
B. 18" BELOW PAD OR ADJACENT GRADE AT INTERIOR GRADE BEAMS, WHICHEVER IS DEEPER, UNO
NOTE: FOOTING MUST BE DEEPENED LOCALLY PER DETAIL 32/S-301 TO ACCOMMODATE ANCHOR

FRAMING

17. SEE ARCHITECTURAL DRAWINGS FOR ALL TOP OF SHEATHING AND TOP OF WALL ELEVATIONS.

18. ALL LINES OR MEMBERS INDICATED AS "STRUT" SHALL RECEIVE (2) ROWS OF BOUNDARY NAILING (BN), STAGGERED.

19. ALL INTERIOR WALLS NOT SHOWN ON THE STRUCTURAL FRAMING PLANS BUT SHOWN ON THE ARCHITECTURAL DRAWINGS SHALL BE CONSTRUCTED PER NON-BEARING PARTITION WALL DETAIL 43/S-401, UNO.

20. PLYWOOD SHEATHED DIAPHRAGM TYPES:

ALL ROOF DIAPHRAGMS SHALL BE TYPE A, UNO
REFER TO 12/S-403

BOLT HOLDOWN EMBED DEPTHS

21. TRUSS MEMBERS AND COMPONENTS SHALL NOT BE CUT, NOTCHED, DRILLED OR OTHERWISE ALTERED IN ANY WAY WITHOUT WRITTEN CONCURRENCE AND APPROVAL OF A REGISTERED DESIGN PROFESSIONAL.

22. ALTERATIONS RESULTING IN THE ADDITION OF LOADS TO ANY MEMBER (E.G. HVAC EQUIPMENT, WATER HEATER) SHALL NOT BE PERMITTED WITHOUT VERIFICATION THAT THE TRUSS IS CAPABLE OF SUPPORTING

XX'-X"

INDICATES SHEAR WALL TYPE AND LENGTH,

PER SCHEDULE ON DETAIL 13/S-402

INDICATES BLOCKING & STRAPPING ABOVE & BELOW WINDOW OPENINGS PER DETAIL 44/S-402

INDICATES HEADER @ OPENING, REFER TO 32/S-401 FOR HEADER SIZE, UNLESS NOTED OTHERWISE

SYMBOL LEGEND INDICATES TOP PLATE SPLICE NAILING PER DETAILS 31/S-403. NAILING APPLIES TO ENTIRE LENGTH OF TOP PLATE. PROVIDE TYPE SPLICE, ULESS NOTED OTHERWISE CS_

INDICATES STRAP PER 52/S-403 OR 54/S-403, UNO

FOUNDATION SCHEDULES

	PAD FOOTING SCHEDULE						
TYPE	WIDTH	LENGTH	THICKNESS	MIN EMBED BELOW LOWEST PAD GRADE	TOP REINF	BOT REINF	DETAIL UNO
FA	PER PLAN	PER PLAN	1'-6"	SEE NOTE 16	#5, @ 8" OC, EW	#5, @ 8" OC, EW	
F2	2'-0"	2'-0"	1'-6"	SEE NOTE 16	(3) #5, EW	(3) #5, EW	44/S-311
F3	3'-0"	3'-0"	1'-6"	SEE NOTE 16	(4) #5, EW	(4) #5, EW	44/3-311
F4	4'-0"	4'-0"	1'-6"	SEE NOTE 16	(6) #5, EW	(6) #5, EW	

NOTE: FOOTING MUST BE DEEPENED LOCALLY PER DETAIL 32/S-301 TO ACCOMMODATE AB HOLDOWN EMBED DEPTHS

STUD WALL SCHEDULE						
VALL HATCH	HDR SIZE, UNO					
	2x6 DF No. 2 STUDS	12" OC				
	2x6 DF No. 2 STUDS	16" OC	32/\$-401			
	2x4 DF No. 2 STUDS	16" OC	32/3-401			
	NON BRG WALLS	16" OC				

OUNDATION SCHEDULES

	SHEARWALL HOLDOWN SCHEDULE	
SPECIFIES HOLI STRAP DETAIL	DOWN/ — 1x INDICATES HOLDOWN/ STRAP TYPE	DETAIL
√6x>	INDICATES SIMPSON HOLDOWN W/ SSTB TO: CONCRETE FOUNDATION:	12/S-311
√7x	INDICATES SIMPSON HOLDOWN W/ SB TO: CONCRETE FOUNDATION:	14/S-311
	CONTINUOUS FOOTING SCHEDULE	

	CONTINUOUS FOOTING SCHEDULE				
MARK	WIDTH	MIN EMBED BELOW LOWEST PAD GRADE	LONG REINF	TRANS REINF	DETAIL
C1.25	1'-3"	SEE NOTE 16	(2) #5 T&B	#3 @ 12" OC, BOT	31/S-311
C1.75	1'-9"	SEE NOTE 16	(3) #5 T&B	#3 @ 12" OC, BOT	31/S-311

	GRADE BEAM SCHEDULE						
TYPE	WIDTH	THICKNESS	MIN EMBED BELOW LOWEST PAD GRADE	LONG REINF	TRANS REINF	DETAIL	
(GB1)	1'-0"	1'-0"	SEE NOTE 16	(2) #4 @ TOP (2) #4 @ BOT	#3 @ 24" OC	24/S-311	

ROOF FRAMING SCHEDULES

 ROOF BEAM SCHEDULE

 MARK
 SIZE
 REMARKS

 B1
 6x6
 6x8

 B2
 6x8
 6x10

 B3
 6x10
 6x12

	RAFTER SCHEDULE	
MARK	SIZE	REMARKS
Jl	2x6 @ 24" OC	
	HEADER SCHEDULE	

SIZE

1. FOR PREFABRICATED ROOF TRUSS NOTES SEE NOTES ON SHEET S-103

PREFABRICATED ROOF TRUSS

	ROOF TRUSS SCHEDU	LE
MARK	DESCRIPTION	REMARKS
RT	ROOF TRUSS (COMMON)	24" OC MAX
SGT	STRUCTURAL GABLE TRUSS	
MT	MONO PITCH TRUSS	24" OC MAX
JT	JACK TRUSS	24" OC MAX
TLV	VALLEY JACK TRUSS	24" OC MAX
CJT	CORNER JACK TRUSS	
GT	GIRDER TRUSS	
MGT	MONO PITCH GIRDER TRUSS	
DT (#*)	DRAG TRUSS	
CGT	CALIFORNIA GIRDER TRUSS	
HR	HIP RAFTER / JACK RAFTER	
CHT	CALIFORNIA HIP TRUSS	24" OC MAX
SCT	SCISSOR TRUSS	24" OC MAX, CEILING SLOPE PER ARCH

(#*) - EQUALS DRAG FORCE IN LBS, DRAG FORCE IS AT A FACTORED LEVEL (0.7E) DRAG FORCES CALCULATED IN ACCORDANCE WITH ASCE 7-16 12.10.1.1. IN STRUCTURES ENTIRELY BRACED BY LIGHT FRAME SHEAR WALLS, OR PORTIONS THEREOF, DRAG MEMBERS SHALL BE DESIGNED TO RESIST FORCES USING THE LOAD COMBINATIONS OF ASCE 7-16 SECTION 12.4.2.3 IN ALL OTHER STRUCTURES DRAGS SHALL INCLUDE THE EFFECT OF OVER STRENGTH PER ASCE 7-16 12.4.3.2


SLIC SET

08/08/24 SHEET

CH


ATHEDRA


S-211

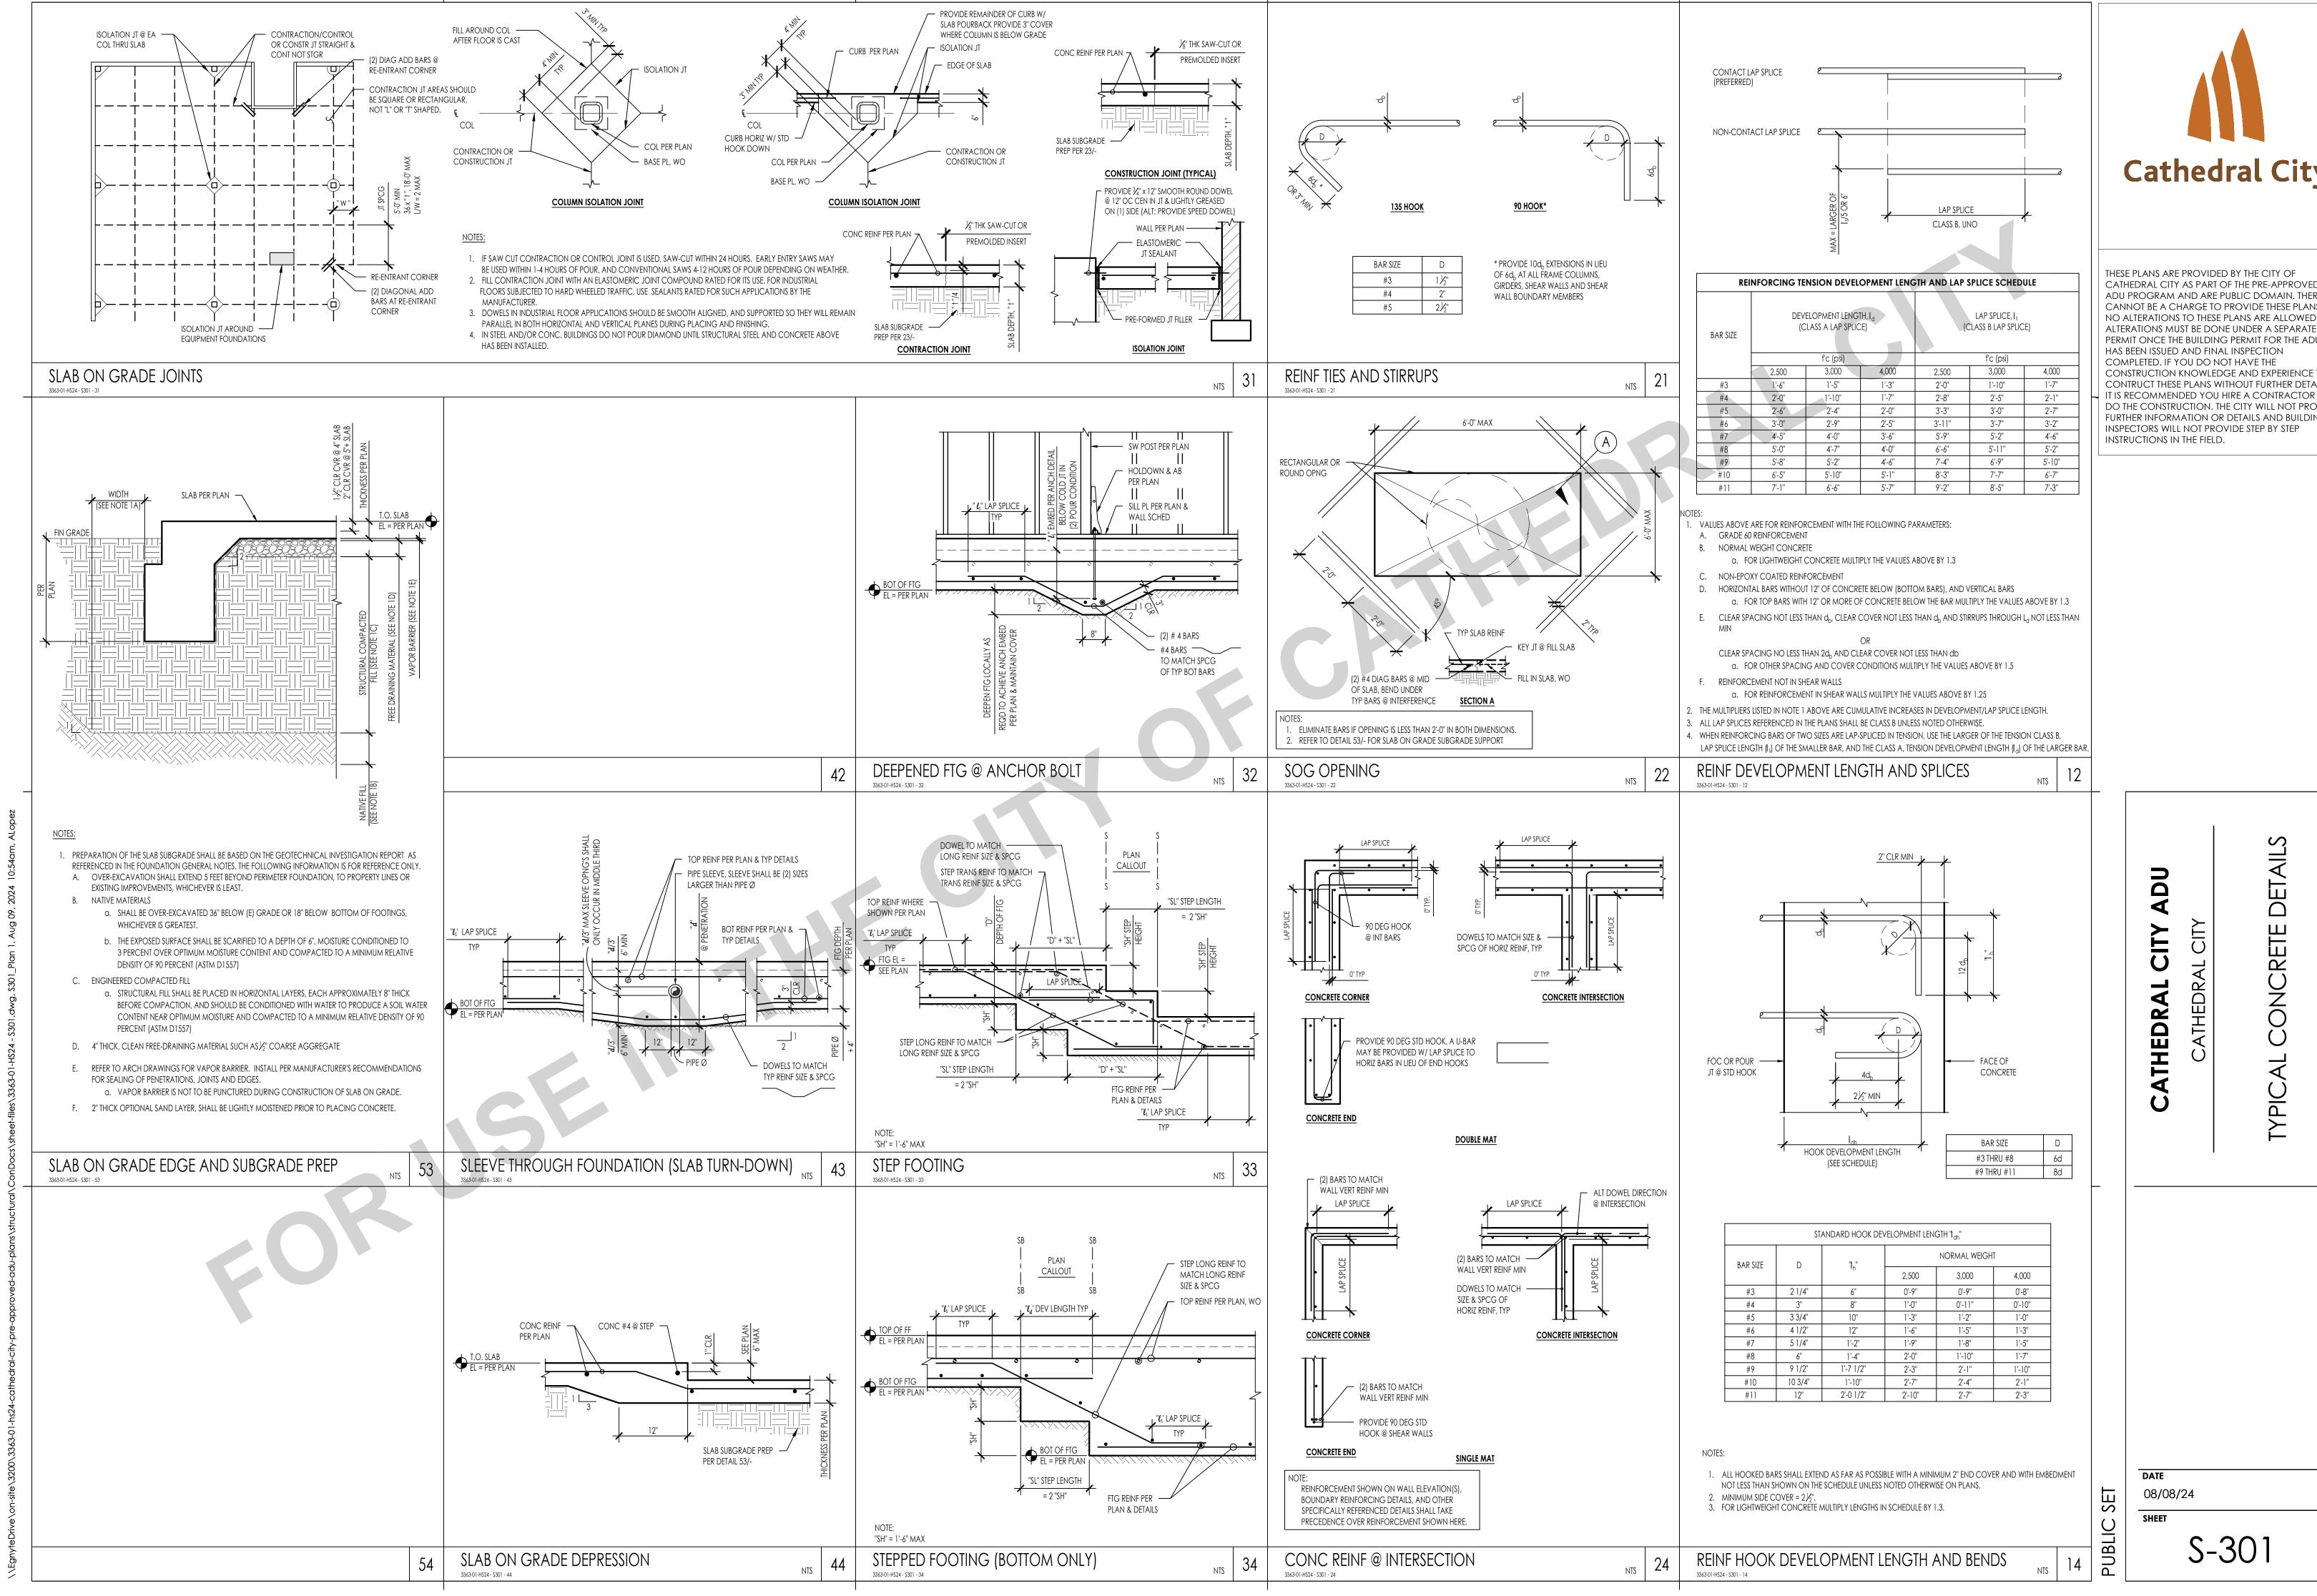


Cathedral City

CATHEDRAL CITY AS PART OF THE PRE-APPROVED ADU PROGRAM AND ARE PUBLIC DOMAIN. THERE CANNOT BE A CHARGE TO PROVIDE THESE PLANS. NO ALTERATIONS TO THESE PLANS ARE ALLOWED. ALL ALTERATIONS MUST BE DONE UNDER A SEPARATE PERMIT ONCE THE BUILDING PERMIT FOR THE ADU CONSTRUCTION KNOWLEDGE AND EXPERIENCE TO CONTRUCT THESE PLANS WITHOUT FURTHER DETAILS, IT IS RECOMMENDED YOU HIRE A CONTRACTOR TO DO THE CONSTRUCTION. THE CITY WILL NOT PROVIDE FURTHER INFORMATION OR DETAILS AND BUILDING

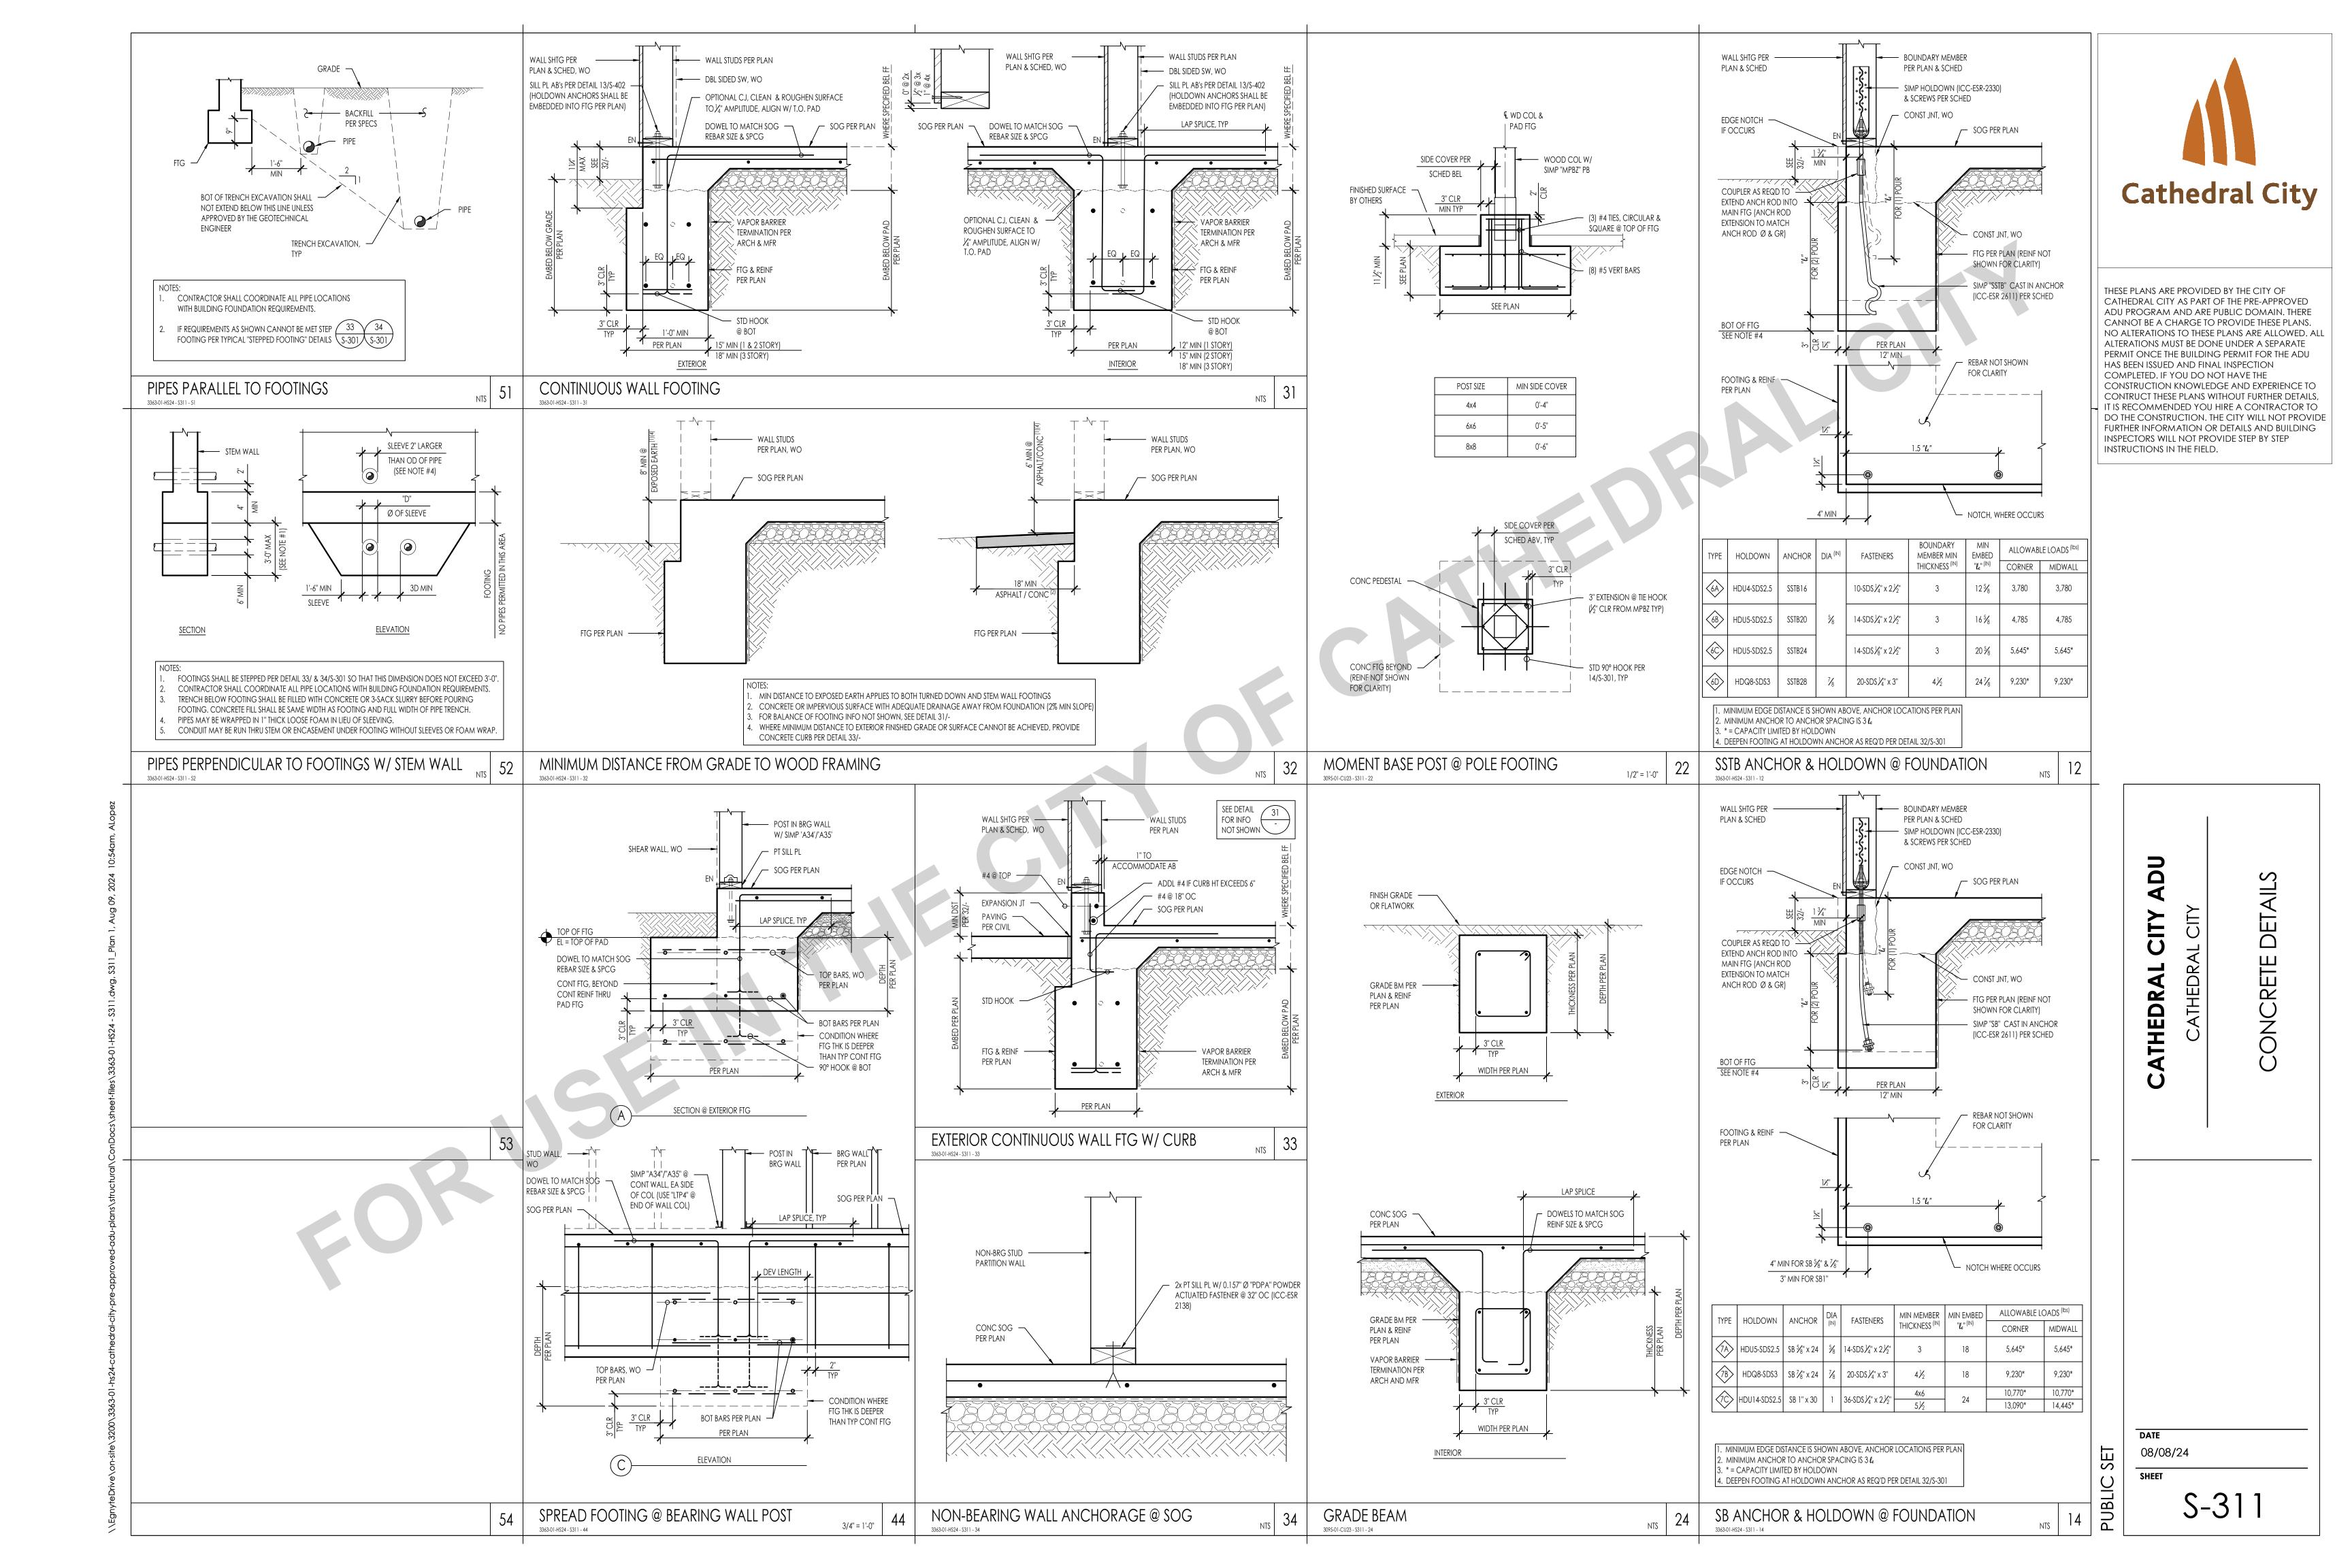

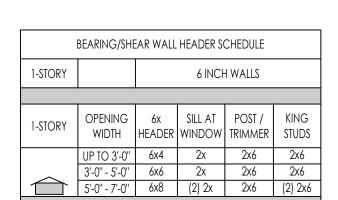

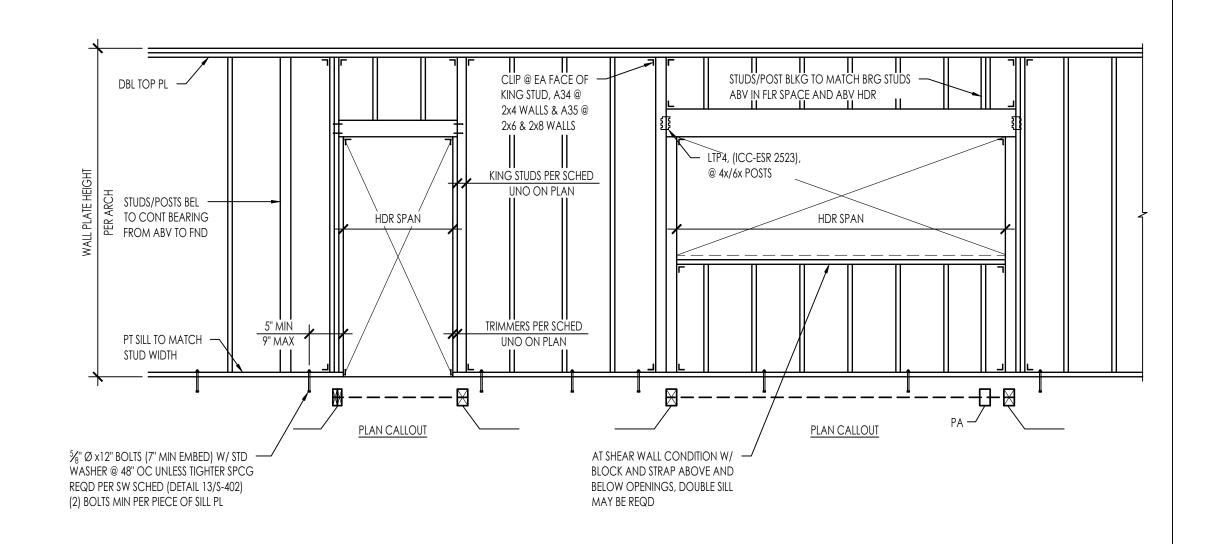

PER 2022 CBC	C 2304.10.1	
CONNECTION	FASTENING	LOCATION
1. BLOCKING BETWEEN CEILING JOISTS, RAFTERS OR TRUSSES TO TOP PLATE OR OTHER FRAMING BELOW	3-8d COMMON	EACH END, TOENAIL
	2-8d COMMON	EACH END, TOENAIL
2. BLOCKING BETWEEN RAFTERS OR TRUSS NOT AT THE WALL TO TOP PLATE, TO RAFTER OR TRUSS	2-16d COMMON	END NAIL
3. FLAT BLOCKING TO TRUSS AND WEB FILLER	16d COMMON @ 6" OC	FACE NAIL
4. CEILING JOIST TO TOP PLATE	3-8d COMMON	EACH JOIST, TOENAIL
5. CEILING JOIST NOT ATTACHED TO PARALLEL RAFTER, LAPS OVER PARTITIONS	3-16d COMMON	FACE NAIL
6. CEILING JOIST ATTACHED TO PARALLEL RAFTER (HEEL JOINT)	3-16d COMMON	FACE NAIL
7. COLLAR TIE TO RAFTER	3-10d COMMON	FACE NAIL
8. RAFTER OR ROOF TRUSS TO PLATE	3-10d COMMON	TOENAIL ^b
O DOOF DAFTED TO DIDGE VALLEY OR HID DAFTED. OR DOOF DAFTED TO O INCH DIDGE DEAM	2-16d COMMON	END NAIL
9. ROOF RAFTER TO RIDGE VALLEY OR HIP RAFTER; OR ROOF RAFTER TO 2-INCH RIDGE BEAM	3-10d COMMON	TOENAIL
10. STUD TO STUD AND ABUTTING STUDS AT INTERSECTING WALL CORNERS	16d COMMON	16" OC FACE NAIL
11. BUILT-UP HEADER (2" TO 2" HEADER)	16d COMMON	16" OC EACH EDGE, FACE NAIL
12. CONTINUOUS HEADER TO STUD	4-10d COMMON	TOENAIL
13. TOP PLATE TO TOP PLATE	16d COMMON	16" OC FACE NAIL
14. TOP PLATE TO TOP PLATE, AT END JOINTS	8-16d COMMON	EACH SIDE OF END JOINT, FACE NAIL (MINIMUM 24" LAP SPLICE LENGTH EACH SID OF END JOINT)
15. BOTTOM PLATE TO JOIST, RIM JOIST, BAND JOIST OR BLOCKING	2-16d COMMON	16" OC FACE NAIL
ALCONING TO TOP OR POTTOM PLATE	4-8d COMMON	TOENAIL
16. STUD TO TOP OR BOTTOM PLATE	2-16d COMMON	END NAIL
17. TOP PLATES, LAPS AT CORNERS AND INTERSECTIONS	2-16d COMMON	FACE NAIL
18. JOIST TO SILL, TOP PLATE, OR GIRDER	3-8d COMMON	TOENAIL
20. RIM JOIST, BAND JOIST, OR BLOCKING TO TOP PLATE, SILL OR OTHER FRAMING BELOW	8d COMMON	6" OC, TOENAIL
21. 1"x6" SUBFLOOR OR LESS TO EACH JOIST	2-8d COMMON	FACE NAIL
22. 2" SUBFLOOR TO JOIST OR GIRDER	2-16d COMMON	FACE NAIL
23. BUILT-UP GIRDER AND BEAMS, 2" LUMBER LAYERS	20d COMMON (4" x 0.192")	32" OC FACE NAIL AT TOP AND BOTTOM STAGGERED ON APPOSITE SIDE
24. LEDGER STRIP SUPPORTING JOIST OR RAFTERS	3-16d COMMON	EACH JOIST OR RAFTER, FACE NAIL
26. JOIST TO BAND JOIST OR RIM JOIST	3-16d COMMON	END NAIL
27. BRIDGING OR BLOCKING TO JOIST, RAFTER OR TRUSS	2-8d COMMON	EACH END, TOENAIL

Cathedral City

THESE PLANS ARE PROVIDED BY THE CITY OF CATHEDRAL CITY AS PART OF THE PRE-APPROVED ADU PROGRAM AND ARE PUBLIC DOMAIN. THERE CANNOT BE A CHARGE TO PROVIDE THESE PLANS. NO ALTERATIONS TO THESE PLANS ARE ALLOWED. ALL ALTERATIONS MUST BE DONE UNDER A SEPARATE PERMIT ONCE THE BUILDING PERMIT FOR THE ADU HAS BEEN ISSUED AND FINAL INSPECTION COMPLETED. IF YOU DO NOT HAVE THE CONSTRUCTION KNOWLEDGE AND EXPERIENCE TO CONTRUCT THESE PLANS WITHOUT FURTHER DETAILS, IT IS RECOMMENDED YOU HIRE A CONTRACTOR TO DO THE CONSTRUCTION. THE CITY WILL NOT PROVIDE FURTHER INFORMATION OR DETAILS AND BUILDING INSPECTORS WILL NOT PROVIDE STEP BY STEP INSTRUCTIONS IN THE FIELD.

THIS DETAIL APPLIES AT ALL EXT WALLS AND INT LOAD BEARING WALLS AND ALSO APPLIES TO SHEAR WALL FRAMING A. FOR SHEAR WALLS SEE 13/S-402 FOR ADD'L REQUIREMENTS. B. FOR INTERIOR NON-BEARING PARTITIONS SEE DETAIL 43/-

HEADERS, KING STUDS AND OTHER REFERENCES ON PLAN GOVERN OVER THIS TYPICAL SCHED/DETAILS

PROVIDE A34 @ 4" WALLS & A35 @ 6" OR GREATER WALLS (ICC-ESR 2353)

THIS NAILING SCHEDULE SHALL ONLY BE USED IF CONDITION IS NOT OTHERWISE DETAILED OR SPECIFIED ON THE CONSTRUCTION DOCUMENTS. COMMON NAILS SHALL BE USED EXCEPT WHERE OTHERWISE STATED

WHERE A RAFTER IS FASTENED TO AN ADJACENT PARALLEL CEILING JOIST IN ACCORDANCE WITH THIS SCHEDULE AND THE CEILING JOIST IS FASTENED TO THE TOP PLATE IN ACCORDANCE WITH THIS SCHEDULE, THE NUMBER OF TOENAILS IN THE RAFTER SHALL BE PERMITTED TO BE REDUCED BY ONE NAIL

LEDGER PER PLAN

- FASTENERS TO BE STGR IN TWO ROWS

LAG SCREW, THROUGH BOLT OR ANCHOR W/WASHER

ANCHOR BOLT AT WOOD STUD

THE TIP OF THE LAG SCREW SHALL FULLY EXTEND BEYOND THE INSIDE FACE OF THE BAND OR RIM JOIST

LEDGER DETAIL

3363-01-HS24 - S401 - 44

